REBUILD FLORIDA - HURRICANE HOUSING REPAIR AND REPLACEMENT

ADDRESS, CITY COUNTY, FLORIDA

FL-HI22-XXXXXXXX

2 BEDROOM / 2 BATH WIDE SLAB

PROJECT MANAGER

Dewberry Engineers Inc.
877 North County Hwy 393
Santa Rosa Beach, FL 32459
850.267.0759

ARCHITECTURAL

Dewberry Architects Inc.


STRUCTURAL

Hunter Baumgardner, PE Southeastern Consulting Engineers, Inc.







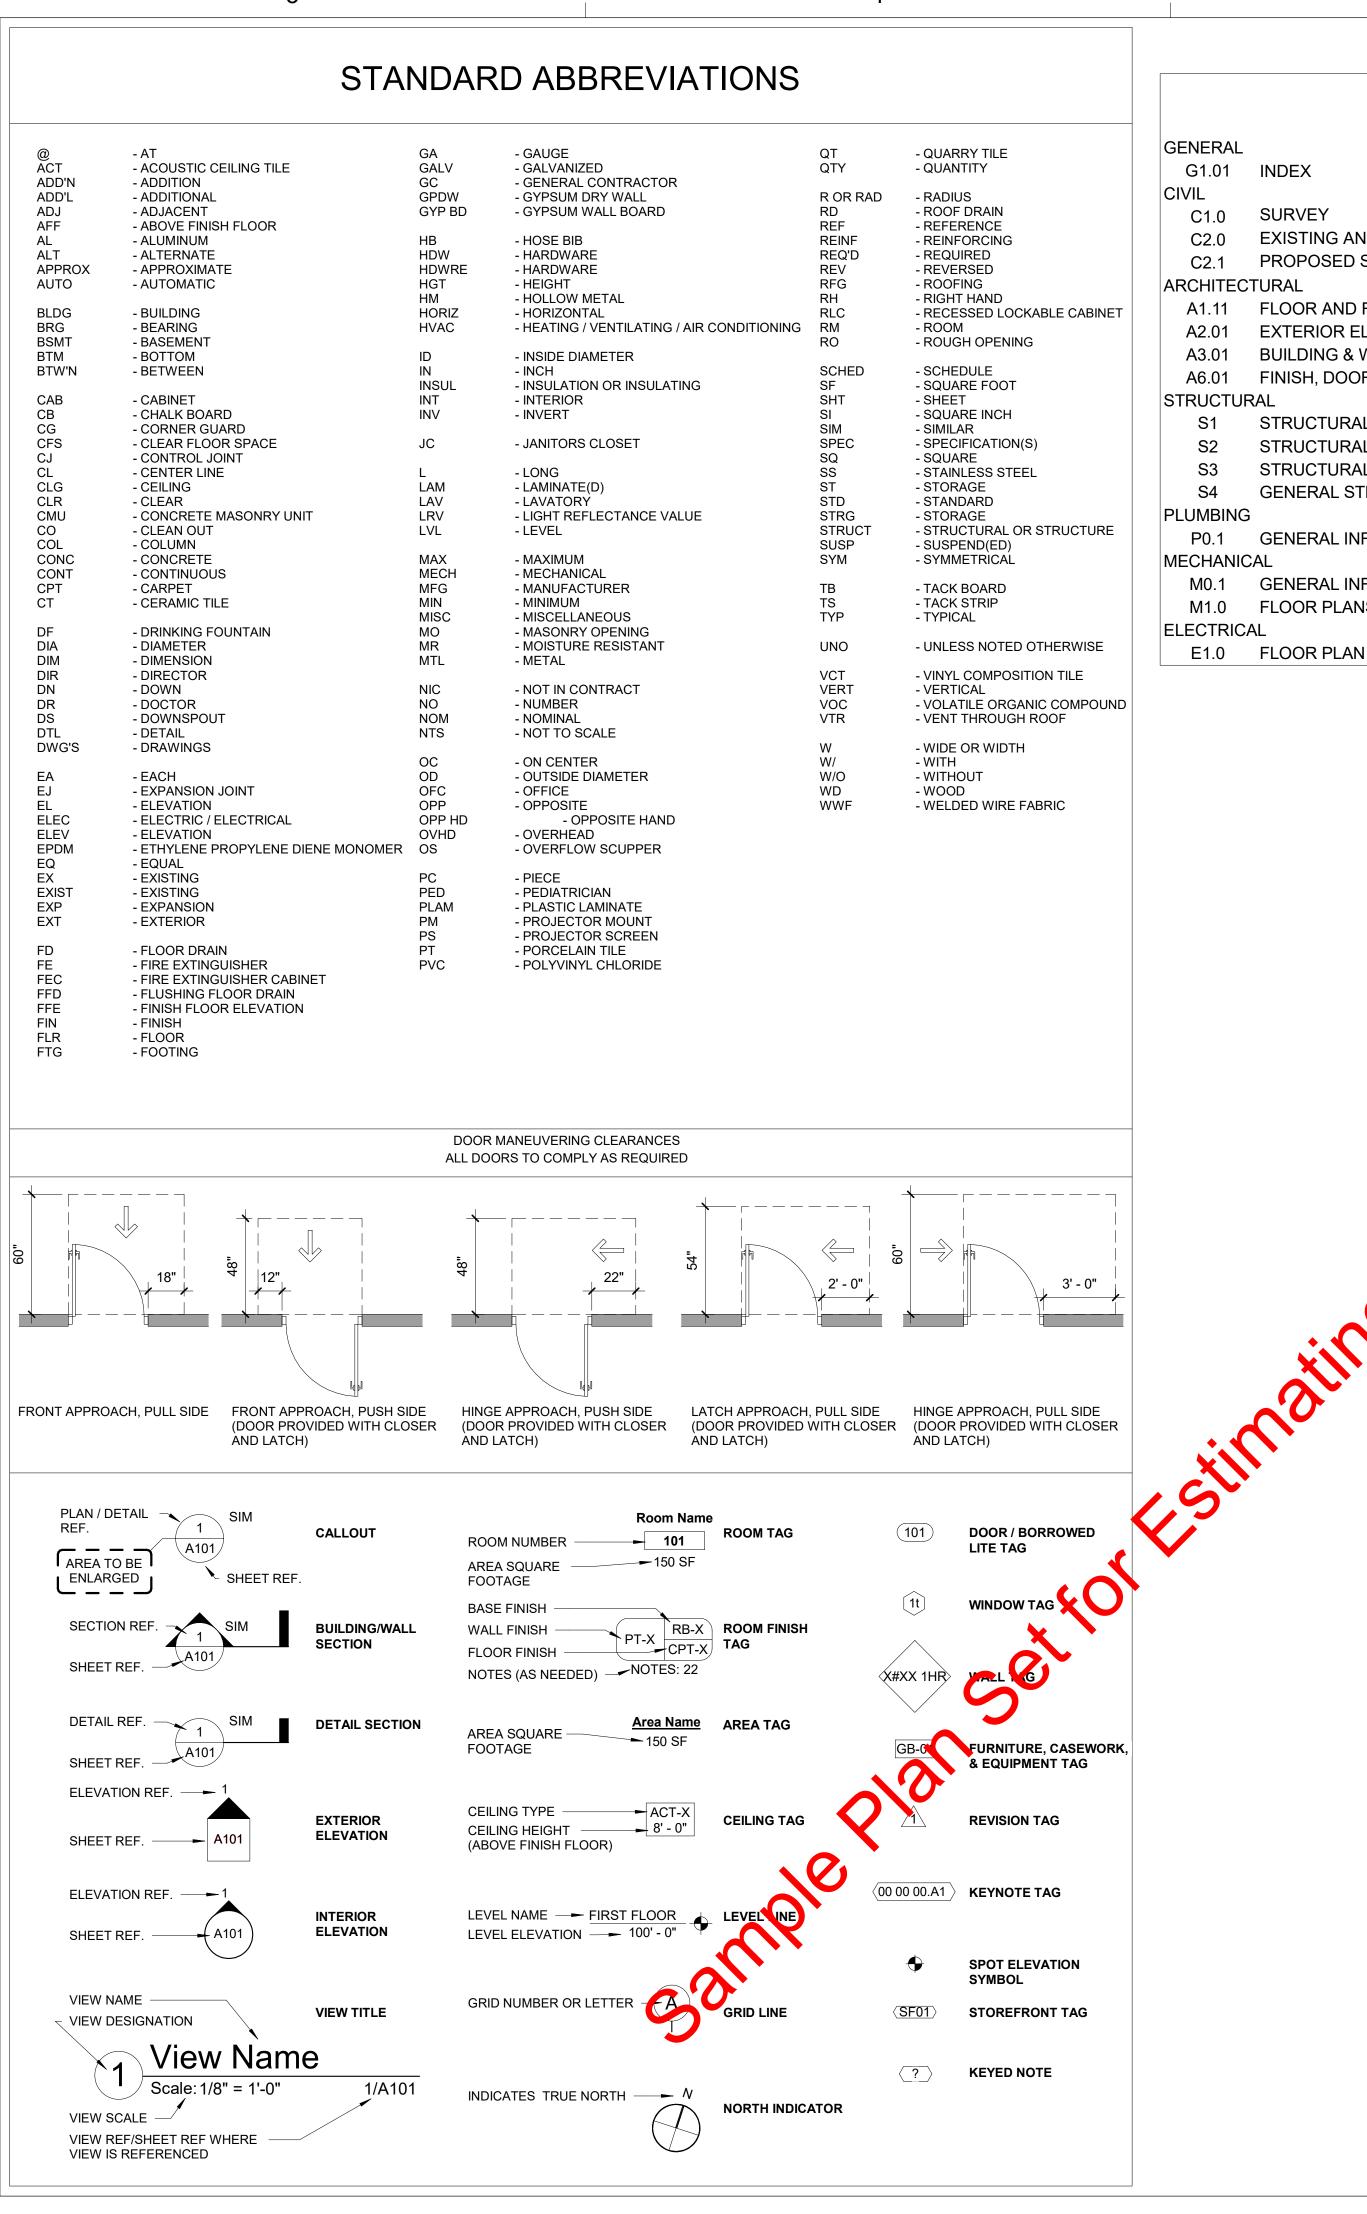

SHEET INDEX SURVEY EXISTING AND PROPOSED SITE OVERLAY PROPOSED SITE AND DRAINAGE PLAN FLOOR AND ROOF PLANS **EXTERIOR ELEVATIONS BUILDING & WALL SECTIONS AND INTERIOR ELEVATIONS** FINISH, DOOR, & WINDOW SCHEDULES STRUCTURAL PLAN VIEWS STRUCTURAL DETAILS STRUCTURAL DETAILS GENERAL STRUCTURAL NOTES

A. BUILDING DATA

SEISMIC DESIGN CATEGORY : TBD (FIGURE R301.2.2(2))

B. ENERGY SUMMARY

: 1,092 SF

: 115 SF : 1,207 SF

NEW CONSTRUCTION

: SINGLE FAMILY RESIDENTIAL

: 17'-2" (+ HEIGHT OF PIERS IF APPLICABLE)

REQUIRED

R-38

R-13

R-13

R-0

0.4

0.25

/ PROVIDED

/ R-19

/ R-19

/ R-0

/ R-38 BLOWN

OR / (2) R-19 BLANKET

TYPE OF WORK

FIRE ALARM

SPRINKLERS

STANDPIPES

FIRE DISTRICT

RISK CATEGORY

BUILDING HEIGHT

CLIMATE ZONE

CEILING

FLOOR

SHGC

SLAB

IECC REQUIREMENTS:

TABLE R402.1.2 THERMAL ENVELOPE

MAXIUMUM U-FACTOR

NEW BUILDING AREA

GROSS

CONSTRUCTION TYPE

FLOOD HAZARD AREA

FIRE/SMOKE RATED WALLS

CONDITIONED

UNCONDITIONED

WALLS ABOVE GRADE (WOOD FRAMED)

FENESTRATION REQUIREMENTS

GENERAL INFORMATION

GENERAL INFORMATION

FLOOR PLANS

GENERAL CONSTRUCTION NOTES

THE CONTRACTOR SHALL VISIT THE JOB SITE TO REVIEW THE SCOPE OF WORK AND CONFIRM THAT THE WORK MAY BE ACCOMPLISHED AS SHOWN.

PLANS ARE NOT TO BE SCALED AND ARE INTENDED TO BE A DIAGRAMMATIC OUTLINE, UNLESS OTHERWISE NOTED.

FURNISH ALL MATERIALS, EQUIPMENT, AND LABOR NECESSARY TO 15. AFFECT ALL INSTALLATIONS INDICATED ON THE DRAWINGS. INCLUDING DETAILS AND LABOR NECESSARY FOR SUCCESSFUL INSTALLATION OF THE WORK.

INSTALL ALL EQUIPMENT AND MATERIALS IN STRICT ACCORDANCE WITH MANUFACTURERS' RECOMMENDATIONS UNLESS SPECIFICALLY INDICATED OTHERWISE OR WHERE LOCAL CODES OR REGULATIONS TAKE PRECEDENCE.

DETAILS ARE INTENDED TO SHOW END RESULT OF DESIGN MINOR MODIFICATIONS MAY BE REQUIRED TO SUIT JOB DIMENSIONS OR

WORK SHOWN OR REFERRED TO ON ANY DRAWING SMALL BE

EVERY EFFORT HAS BEEN MADE TO PROVIDE THE COMPLETE SCOPE OF WORK. MINOR OMISSION 3 AND DESCREPANCIES IN THE DRAWINGS SHALL NOT DIMINISH THE EXPLICTATION OF A COMPLETED FACILITY AND IMPROVENED IN ACCORDANCE WITH THE INTENT OF THESE DOCUMENTS. IN THE EVENT OF DISCREPANCIES, PRICE THE MERE EXPENSIVE OR EXTENSIVE

GENERAL CONTRACTOR SHALL PROVIDE AT THE JOB SITE A FULL SET OF CONSTRUCTION DECUMENTS ANNOTATED WITH THE LATEST REVISIONS ND CLARIFICATIONS FOR THE USE BY ALL.

GENERAL CONTRACTOR SHALL COORDINATE, APPLY, AND PAY FOR 24.
ALL PERMITS UNSTECTIONS, AND/OR CERTIFICATES FROM THE APPROPRINTE ACENCIES. IT IS THE CONTRACTOR'S RESPONSIBLITY TO CALL FOR LOCAL INSPECTIONS AND OBTAIN APPROVAL FROM THE STATE FIRE MARSHAL IF REQUIRED.

TRACTOR SHALL VERIFY THE MINIMUM FINISH FLOOR VATION WITH THE CITY/PARISH FEMA BASE FLOOD ELEVATION ND BENCHMARK CERTIFICATE.

THE CONTRACTOR SHALL HAVE THE WORK SITE CLEANED ON A DAILY BASIS. THE DISPOSAL OF ANY WASTE SHALL BE OFF SITE AND IN A MANNER PRESCRIBED UNDER THE LAW.

COORDINATE WITH UTILITY PROVIDERS TO LOCATE, CAP, AND/OR DISCONNECT UTILITIES AS REQUIRED.

13. IT IS THE RESPONSIBILITY OF THE CONTRACTOR TO VERIFY AND COMPLY WITH ALL BUILDING CODE, MUNICIPAL CODE AND HOME

REQUIRED.

OWNER ASSOCIATION (HOA) REQUIREMENTS. RAZE EXISTING STRUCTURE AS REQUIRED, PROPERLY DISPOSING

OF DEBRIS WITH A LEGAL DUMPSTER ON SITE. MOVE SIDEWALKS, DRIVEWAYS, AND OTHER FLATWORK ON SITE

MOVE EXISTING SHRUBS, TREE ROOTS, ETC WHERE NEW ATWORK, DRAINLINES, AND HOUSE SLABS WILL BE LOCATED AS

COORDINATE TREE REMOVAL WITH MUNICPALITY. PROTECT TREES

FILL HOLES CAUSED BY REMOVAL OF EXISTING OBSTRUCTIONS WITH SOIL SIMILAR TO EXISTING ADJACENT SOILS.

SLOPE ALL CONCRETE PAVING AWAY FROM BUILDING AT MINIMUM

SLOPE ALL CONCRETE WALKS AWAY FROM BUILDING AT MINIMUM

SLOPE ALL FINAL GRADING AWAY FROM BUILDING TO ENSURE POSITIVE DRAINAGE TO AREA DRAINS OR CULVERTS, NOT TO ADJACENT PROPERTIES.

ALL DRIVEWAY AND SIDEWALKS SHALL MEET LOCAL DEPARTMENT OF PUBLIC WORKS STANDARD DETAILS IF APPLICABLE.

THE CONTRACTOR SHALL COORDINATE ALL UTILITIES INSTALLATION AND CONNECTION WITH LOCAL UTILITY COMPANY.

CONTRACTOR SHALL PROVIDE CLEAN OUT LOCATIONS, TIE-IN LOCATIONS, AND WATER AND SEWER LINE LOCATIONS ON SITE TO

LAY NEW SOD AROUND PERIMETER OF FOUNDATION A MINIMUM OF 8 FEET. STABILIZE OTHER DISTURBED SOILS BY OTHER APPROPRIATE METHODS.

PERMIT DEPARTMENT FOR REVIEW.

CONTRACTOR SHALL PROVIDE ALL PLUMBING FIXTURES, ELECTRICAL FIXTURE, DOOR HARDWARE, BATHROOM HARDWARE, AND BATHROOM ACCESSORIES IN A CONSISTENT MATERIAL FINISH.

APPLIANCES SHALL BE ENERGY STAR CERTIFIED - CLOTHES WASHER, CLOTHES DRYER, RANGE HOOD, DISHWASHER, REFRIGERATOR. SUPPLY HOSES TO WATER USING FIXTURES AND APPLIANCES MUST BE ARMORED PEX OR METAL (NOT COPPER).

ALL EXTERIOR PAINT TO MEET LIGHT REFLECTANCE VALUE (LRV) OF

PER FBC APPENDIX F, PASSIVE RADON-RESISTANT CONSTRUCTION: PROVIDE 6 MIL VAPOR BARRIER UNDER SLAB ON GRADE.

2" PRESSURE-SENSITIVE VINYL TAPE ALL JOINTS. SEAL AND CAULK ALL SLAB PENETRATIONS WITH MASTIC OR

SLABS AND FOUNDATIONS SHALL BE CONSTRUCTED USING A SLAB EDGE DETAIL THAT ELIMINATES CRACKS THAT COULD CONNECT THE HOUSE INTERIOR TO SUBSLAB SOIL. MONOLITHIC SLAB CONSTRUCTION USED WHERE POSSIBLE.

ALL CONTRACTION JOINTS SHALL BE CLEANED AND SEALED AGAINST SOIL-GAS ENTRY BY USE OF AN APPROVED SEALANT.

WORK SPACES FORMED INTO A SLAB SHALL BE SEALED GAS-TIGHT, EXPOSED SOIL SHALL BE COMPACTED AND FULLY COVERED WITH A SOLVENT-BASED PLASTIC ROOF CEMENT OR OTHER APPROVED ELASTOMERIC MATERIAL TO

A MIN. DEPTH OF 1". WHERE PENETRATING PIPES ARE SLEEVED, THEY SHALL BE SEALED BY JOINT SEALANT OR APPROVED ALTERNATIVE

VAPOR BARRIER NOT REQUIRED FOR PIER CONSTRUCTION WHEN BOTTOM OF FLOOR JOISTS ARE GREATER THAN 18" FROM GRADE.

C. BUILDING CODE SUPPORTING DATA

APPLICABLE CODE

:2023 FLORIDA BUILDING CODE. RESIDENTIAL 2023 FLORIDA BUILDING CODE, ENERGY CONSERVATION 2018 WOOD FRAME CONSTRUCTION MANUAL **AMERICANS WITH DISABILITIES ACT GUIDELINES**

ENCLOSED SPACE UNDER STAIRS THAT IS ACCESSED BY A DOOR OR ACCESS PANEL SHALL HAVE WALLS. UNDER-STAIR SURFACE AND ANY SOFFITS PROTECTED ON THE ENCLOSED SIDE WITH 1/2-INCH GYPSUM BOARD

BOTH VERTICAL AND HORIZONTAL CONCEALED DRAFT OPENINGS AND TO FORM AN EFFECTIVE FIRE BARRIER BETWEEN STORIES, AND BETWEEN A TOP STORY AND THE

IN COMBUSTIBLE CONSTRUCTION, FIREBLOCKING SHALL BE PROVIDED TO CUT OFF

HABITABLE ROOMS SHALL HAVE AN AGGREGATE GLAZING AREA OF NOT LESS THAN 8 PERCENT OF THE FLOOR AREA OF SUCH ROOMS

HABITABLE ROOMS SHALL HAVE A ROOM AREA OF NOT LESS THAN 70 SQUARE FEET EXCEPTION: KITCHENS

R304.2 HABITABLE ROOMS SHALL BE NOT LESS THAN 7 FEET IN ANY HORIZONTAL DIMENSION **EXCEPTION: KITCHENS** BASEMENTS, HABITABLE ATTICS, AND EVERY SLEEPING ROOM SHALL HAVE NOT LESS

THAN ONE OPERABLE EMERGENCY ESCAPE AND RESCUE OPENING EMERGENCY ESCAPE AND RESCUE OPENINGS SHALL HAVE A NET CLEAR OPENING OF

NOT LESS THAN 5.7 SQUARE FEET NOT LESS THAN ONE EGRESS DOOR SHALL BE PROVIDED FOR EACH DWELLING UNIT, AND SHALL PROVIDE A CLEAR WIDTH OF NOT LESS THAN 32 INCHES.

THERE SHALL BE A LANDING OR FLOOR ON EACH SIDE OF EACH EXTERIOR DOOR. THE WIDTH OF THE LANDING SHALL BE NOT LESS THAN THE DOOR SERVED. LANDINGS SHALL HAVE A DIMENSION OF NOT LESS THAN 36 INCHES MEASURED IN THE

DIRECTION OF TRAVEL THE WIDTH OF A HALLWAY SHALL BE NOT LESS THAN 3 FEET

A FLIGHT OF STAIRS SHALL NOT HAVE A VERTICAL RISE LARGER THAN 12 FEET 7 INCHES BETWEEN FLOOR LEVELS OR LANDINGS

 
THE MAXIMUM RISER HEIGHT SHALL BE 7 3/4 INCHES

THE TREAD DEPTH SHALL BE NOT LESS THAN 10 INCHES

SMOKE ALARMS SHALL BE INSTALLED IN EACH SLEEPING ROOM, OUTSIDE EACH SEPARATE SLEEPING AREA IN THE IMMEDIATE VICINITY OF THE BEDROOMS. NOT LESS THAN 3 FEET HORIZONTALLY FROM THE DOOR OR OPENING OF A BATHROOM THAT CONTAINS A BATHTUB OR SHOWER, AND ON EACH ADDITIONAL STORY.

BUILDINGS SHALL BE PROVIDED WITH APPROVED ADDRESS IDENTIFICATION. THE ADDRESS IDENTIFICATION SHALL BE LEGIBLE AND PLACED IN A POSITION THAT IS VISIBLE FROM THE STREET OR ROAD FRONTING THE PROPERTY. EACH CHARACTER SHALL BE NOT LESS THAN 4 INCHES IN HEIGHT

THE UNDER-FLOOR SPACE BETWEEN THE BOTTOM OF THE FLOOR JOISTS AND THE EARTH UNDER ANY BUILDING SHALL HAVE VENTILATION OPENINGS THROUGH FOUNDATION WALLS OR EXTERIOR WALLS. THE MINIMUM NET AREA OF VENTILATION OPENINGS SHALL BE NOT LESS THAN 1 SQUARE FOOT FOR EACH 150 SQUARE FEET OF UNDER-FLOOR SPACE AREA. ONE SUCH VENTILATING OPENING SHALL BE WITHIN 3 FEET OF EACH CORNER OF THE BUILDING



SCALE

SEAL

As indicated

Dewberry


877 North County Hwy 393

850.267.0759 Phone

850.557.0076 Fax

www.dewberry.com

Santa Rosa Beach, FL 32459

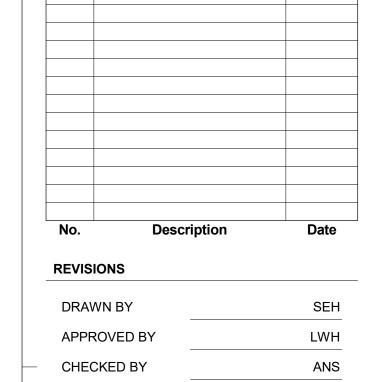

INDEX


50171913

PROJECT NO.

SHEET NO.


DATE


TITLE

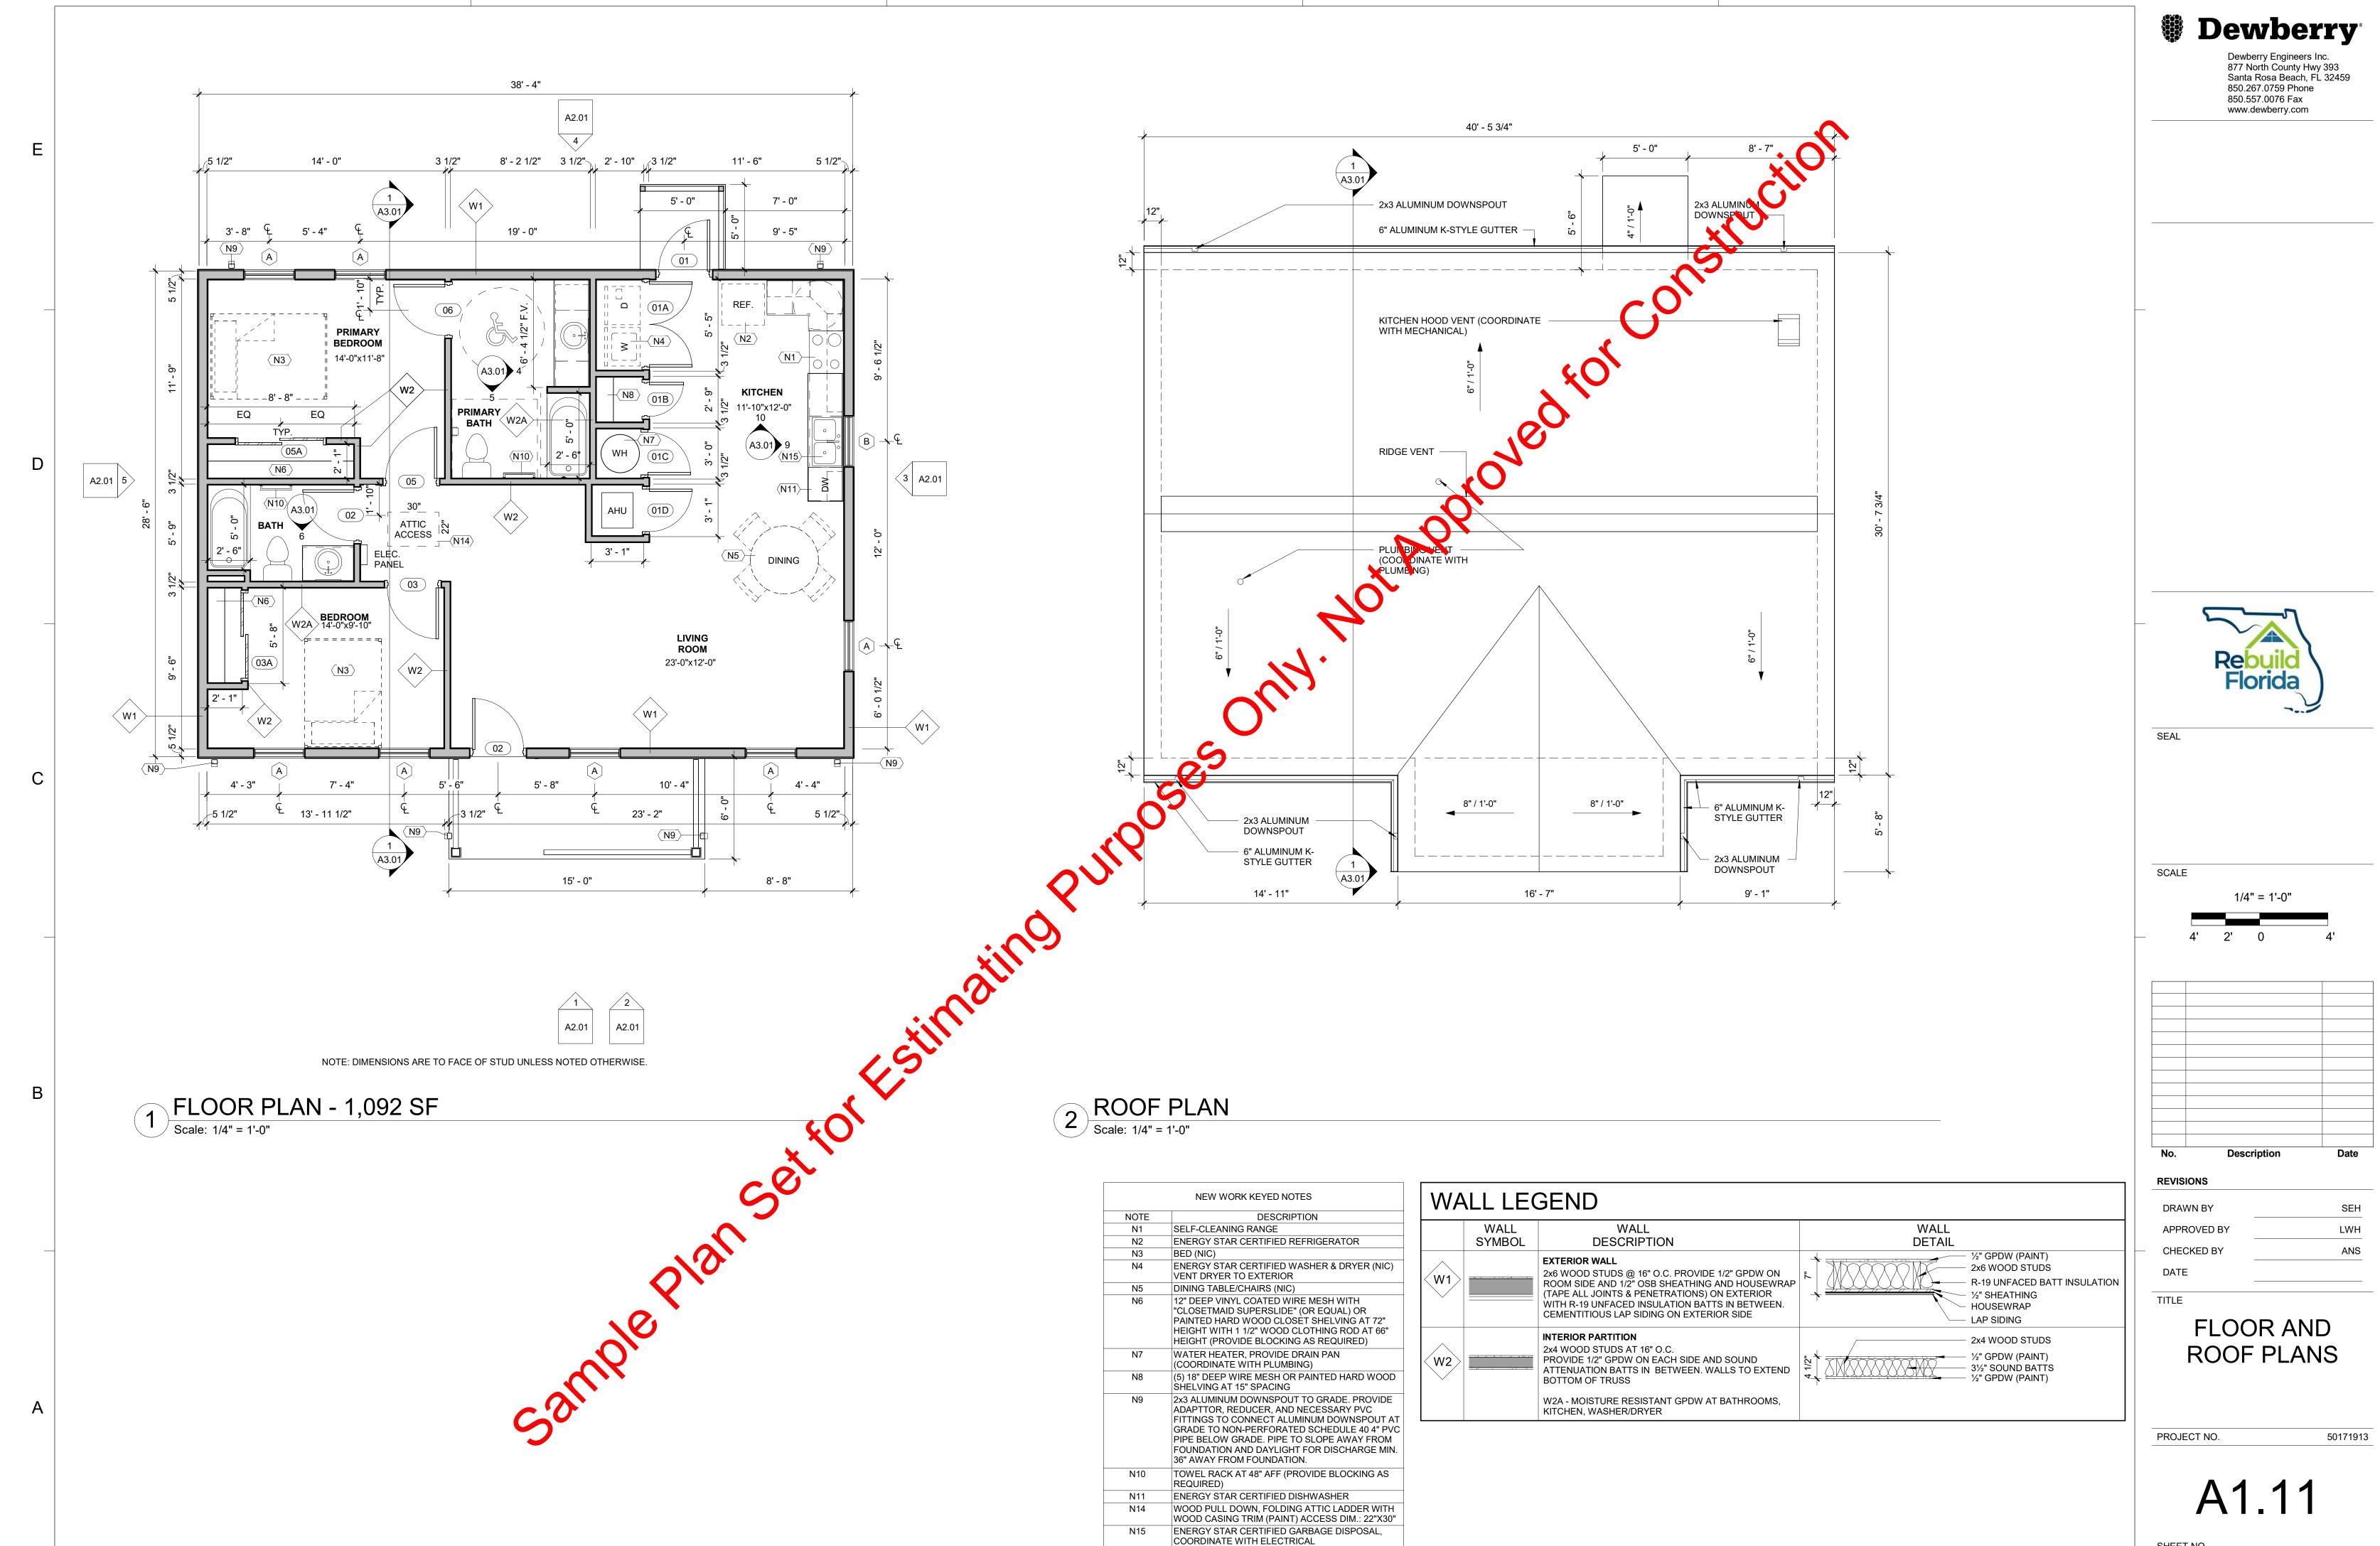



9/18/2024 4:56:14 P

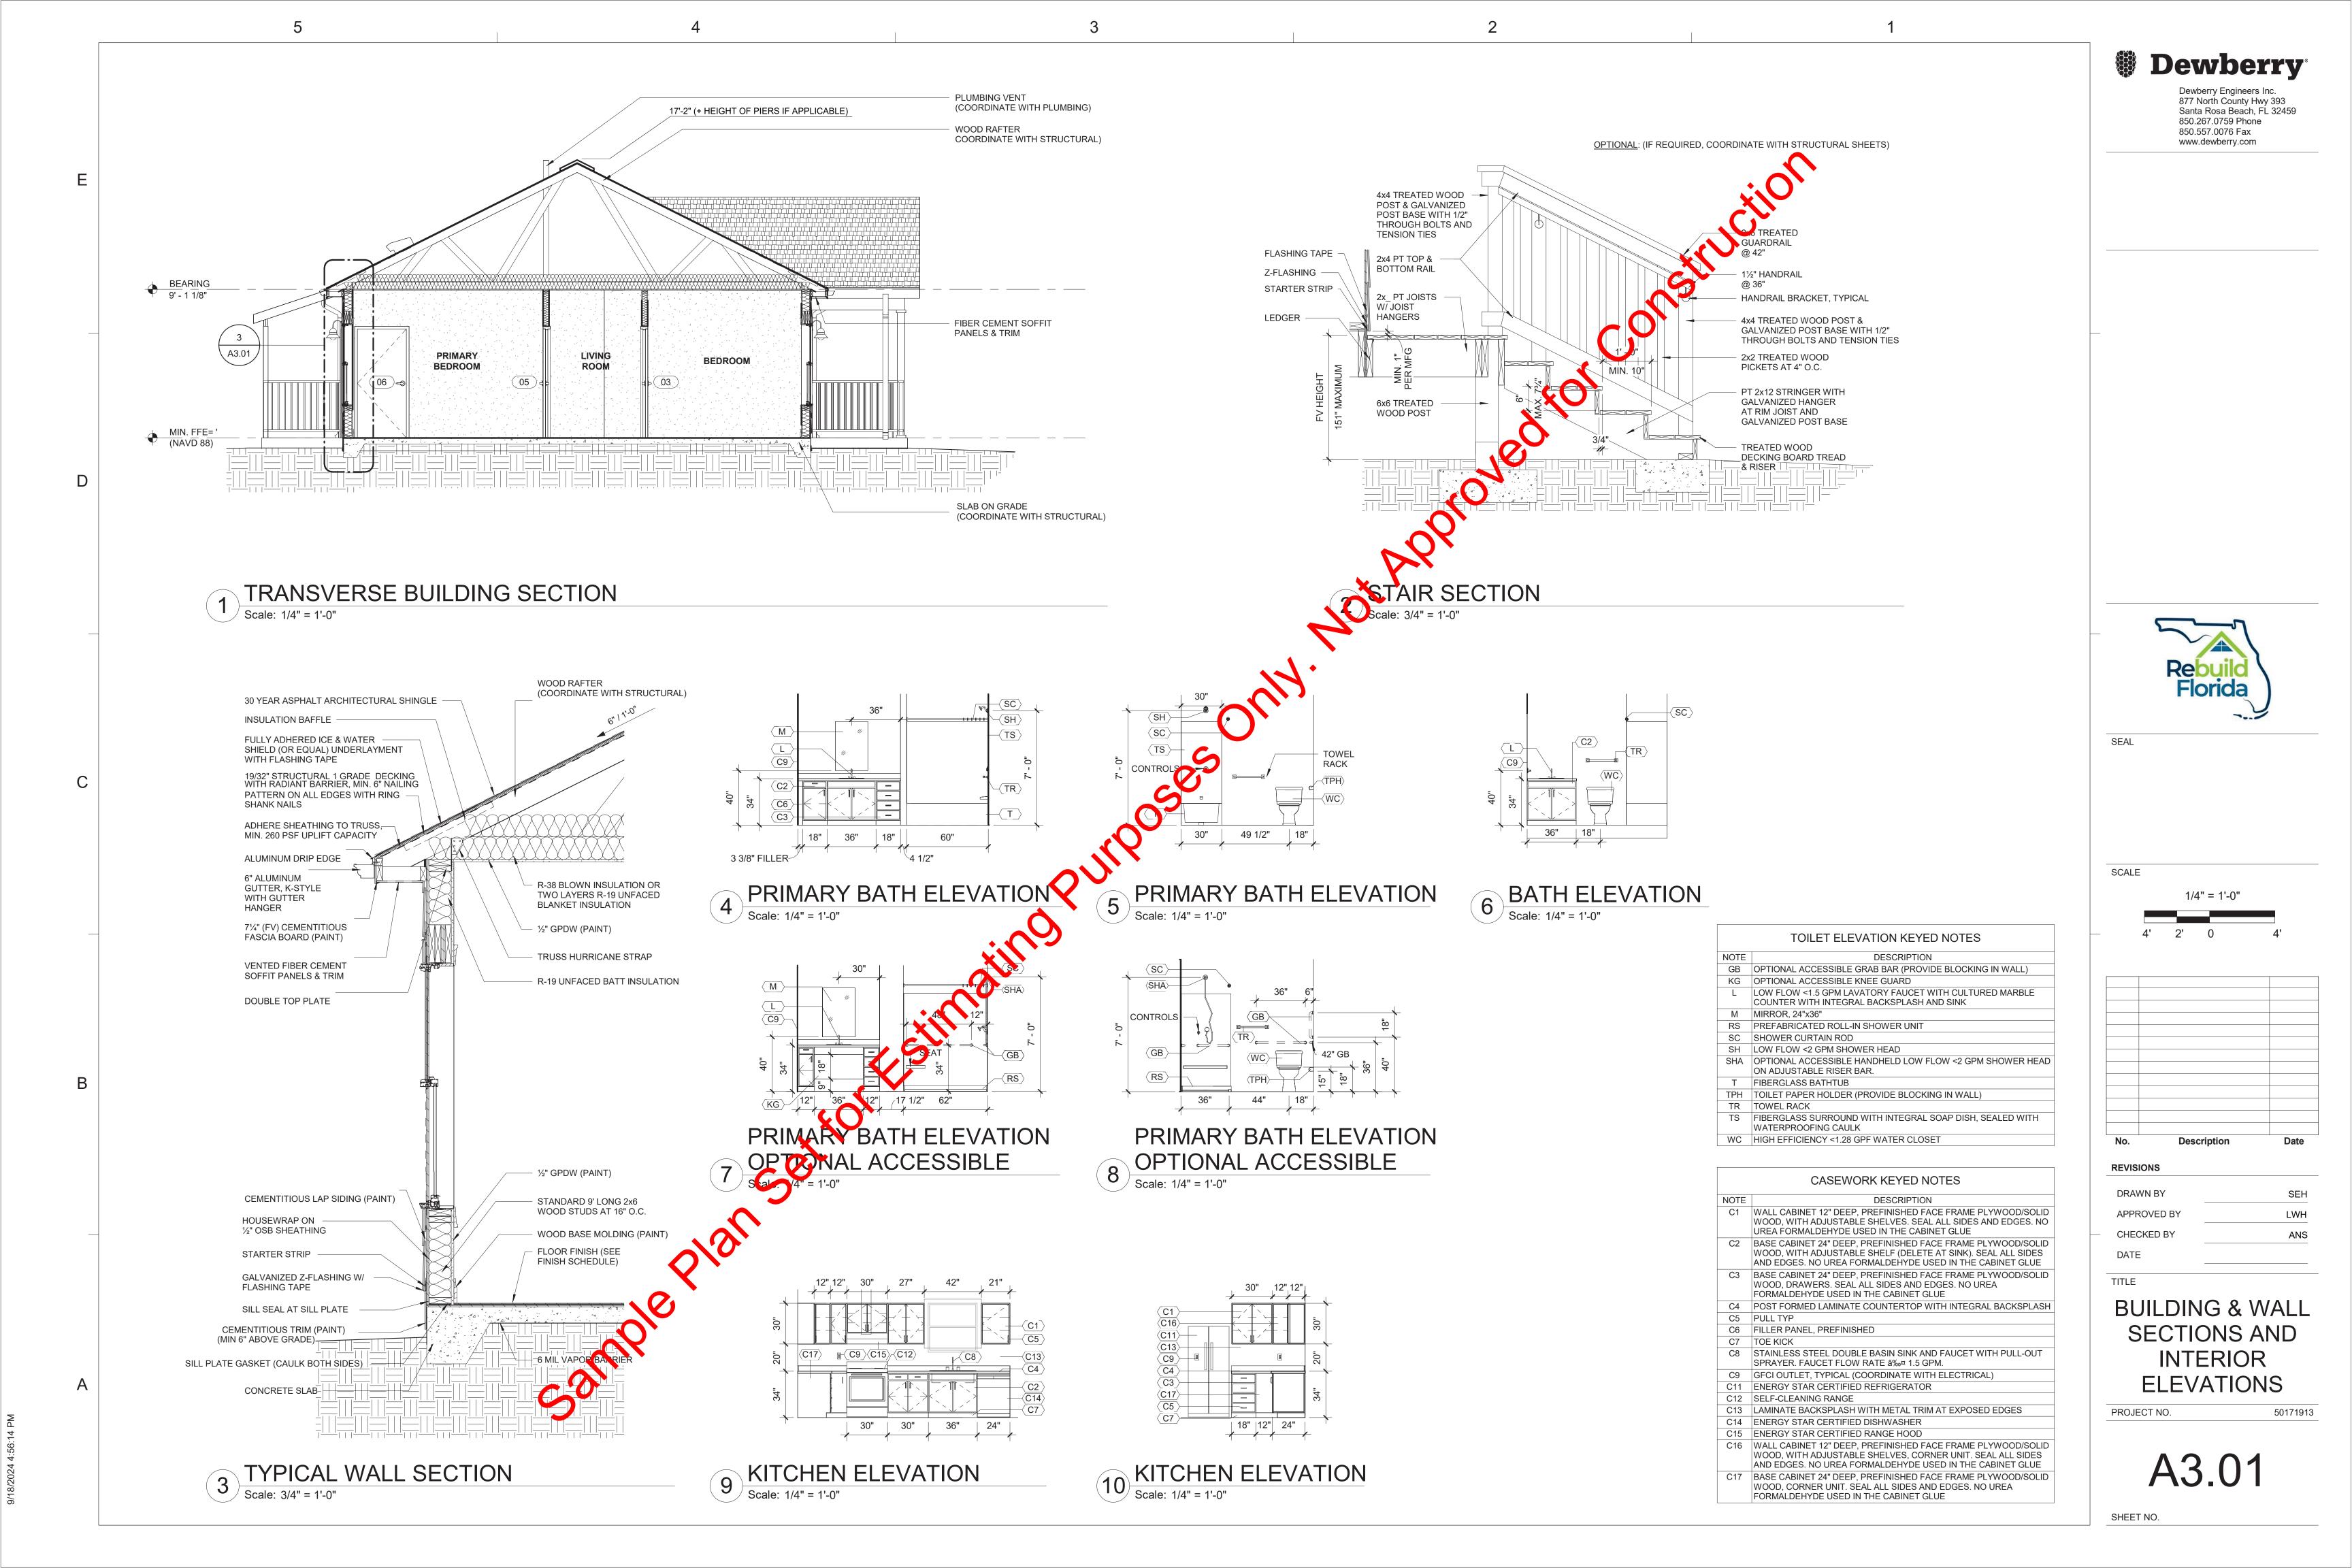

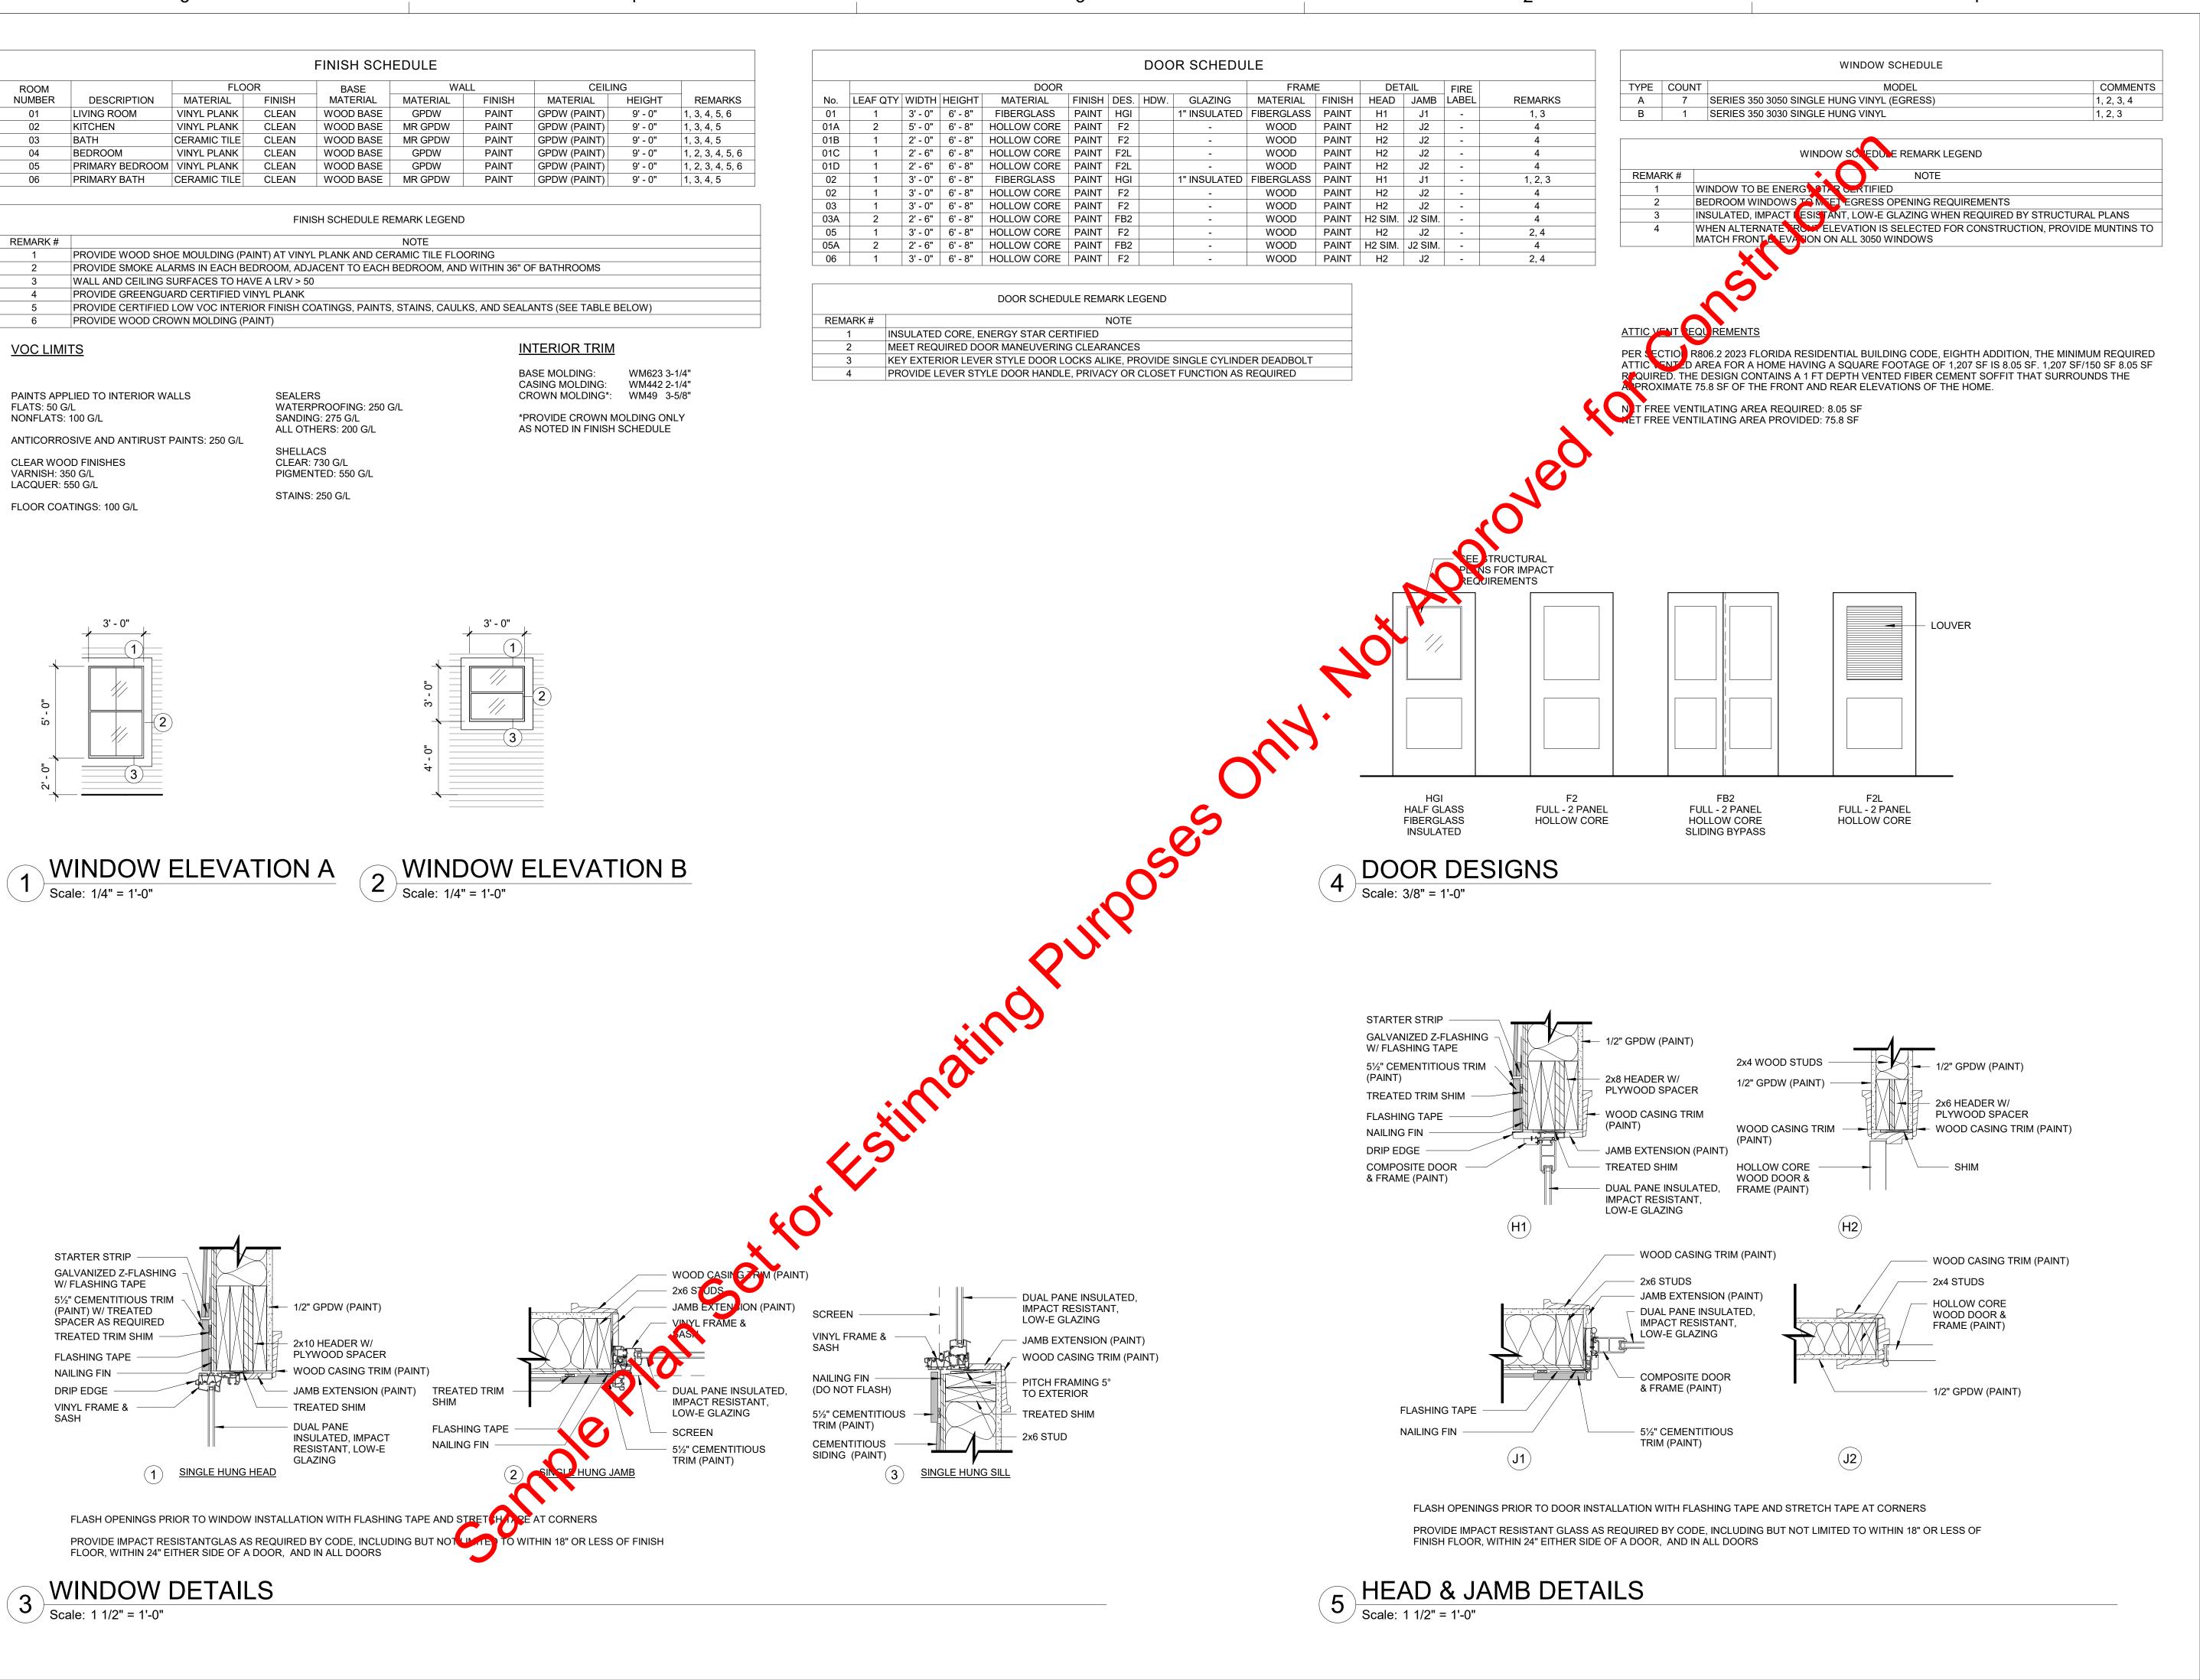

Dewberry Engineers Inc. 877 North County Hwy 393 Santa Rosa Beach, FL 32459 850.267.0759 Phone 850.557.0076 Fax www.dewberry.com

Rebuild Florida

SCALE

SEAL

As indicated

No. Description Date

REVISIONS


DRAWN BY SEH
APPROVED BY LWH
CHECKED BY ANS
DATE

TITLE

FINISH, DOOR, & WINDOW SCHEDULES

PROJECT NO. 50171913

A6.01

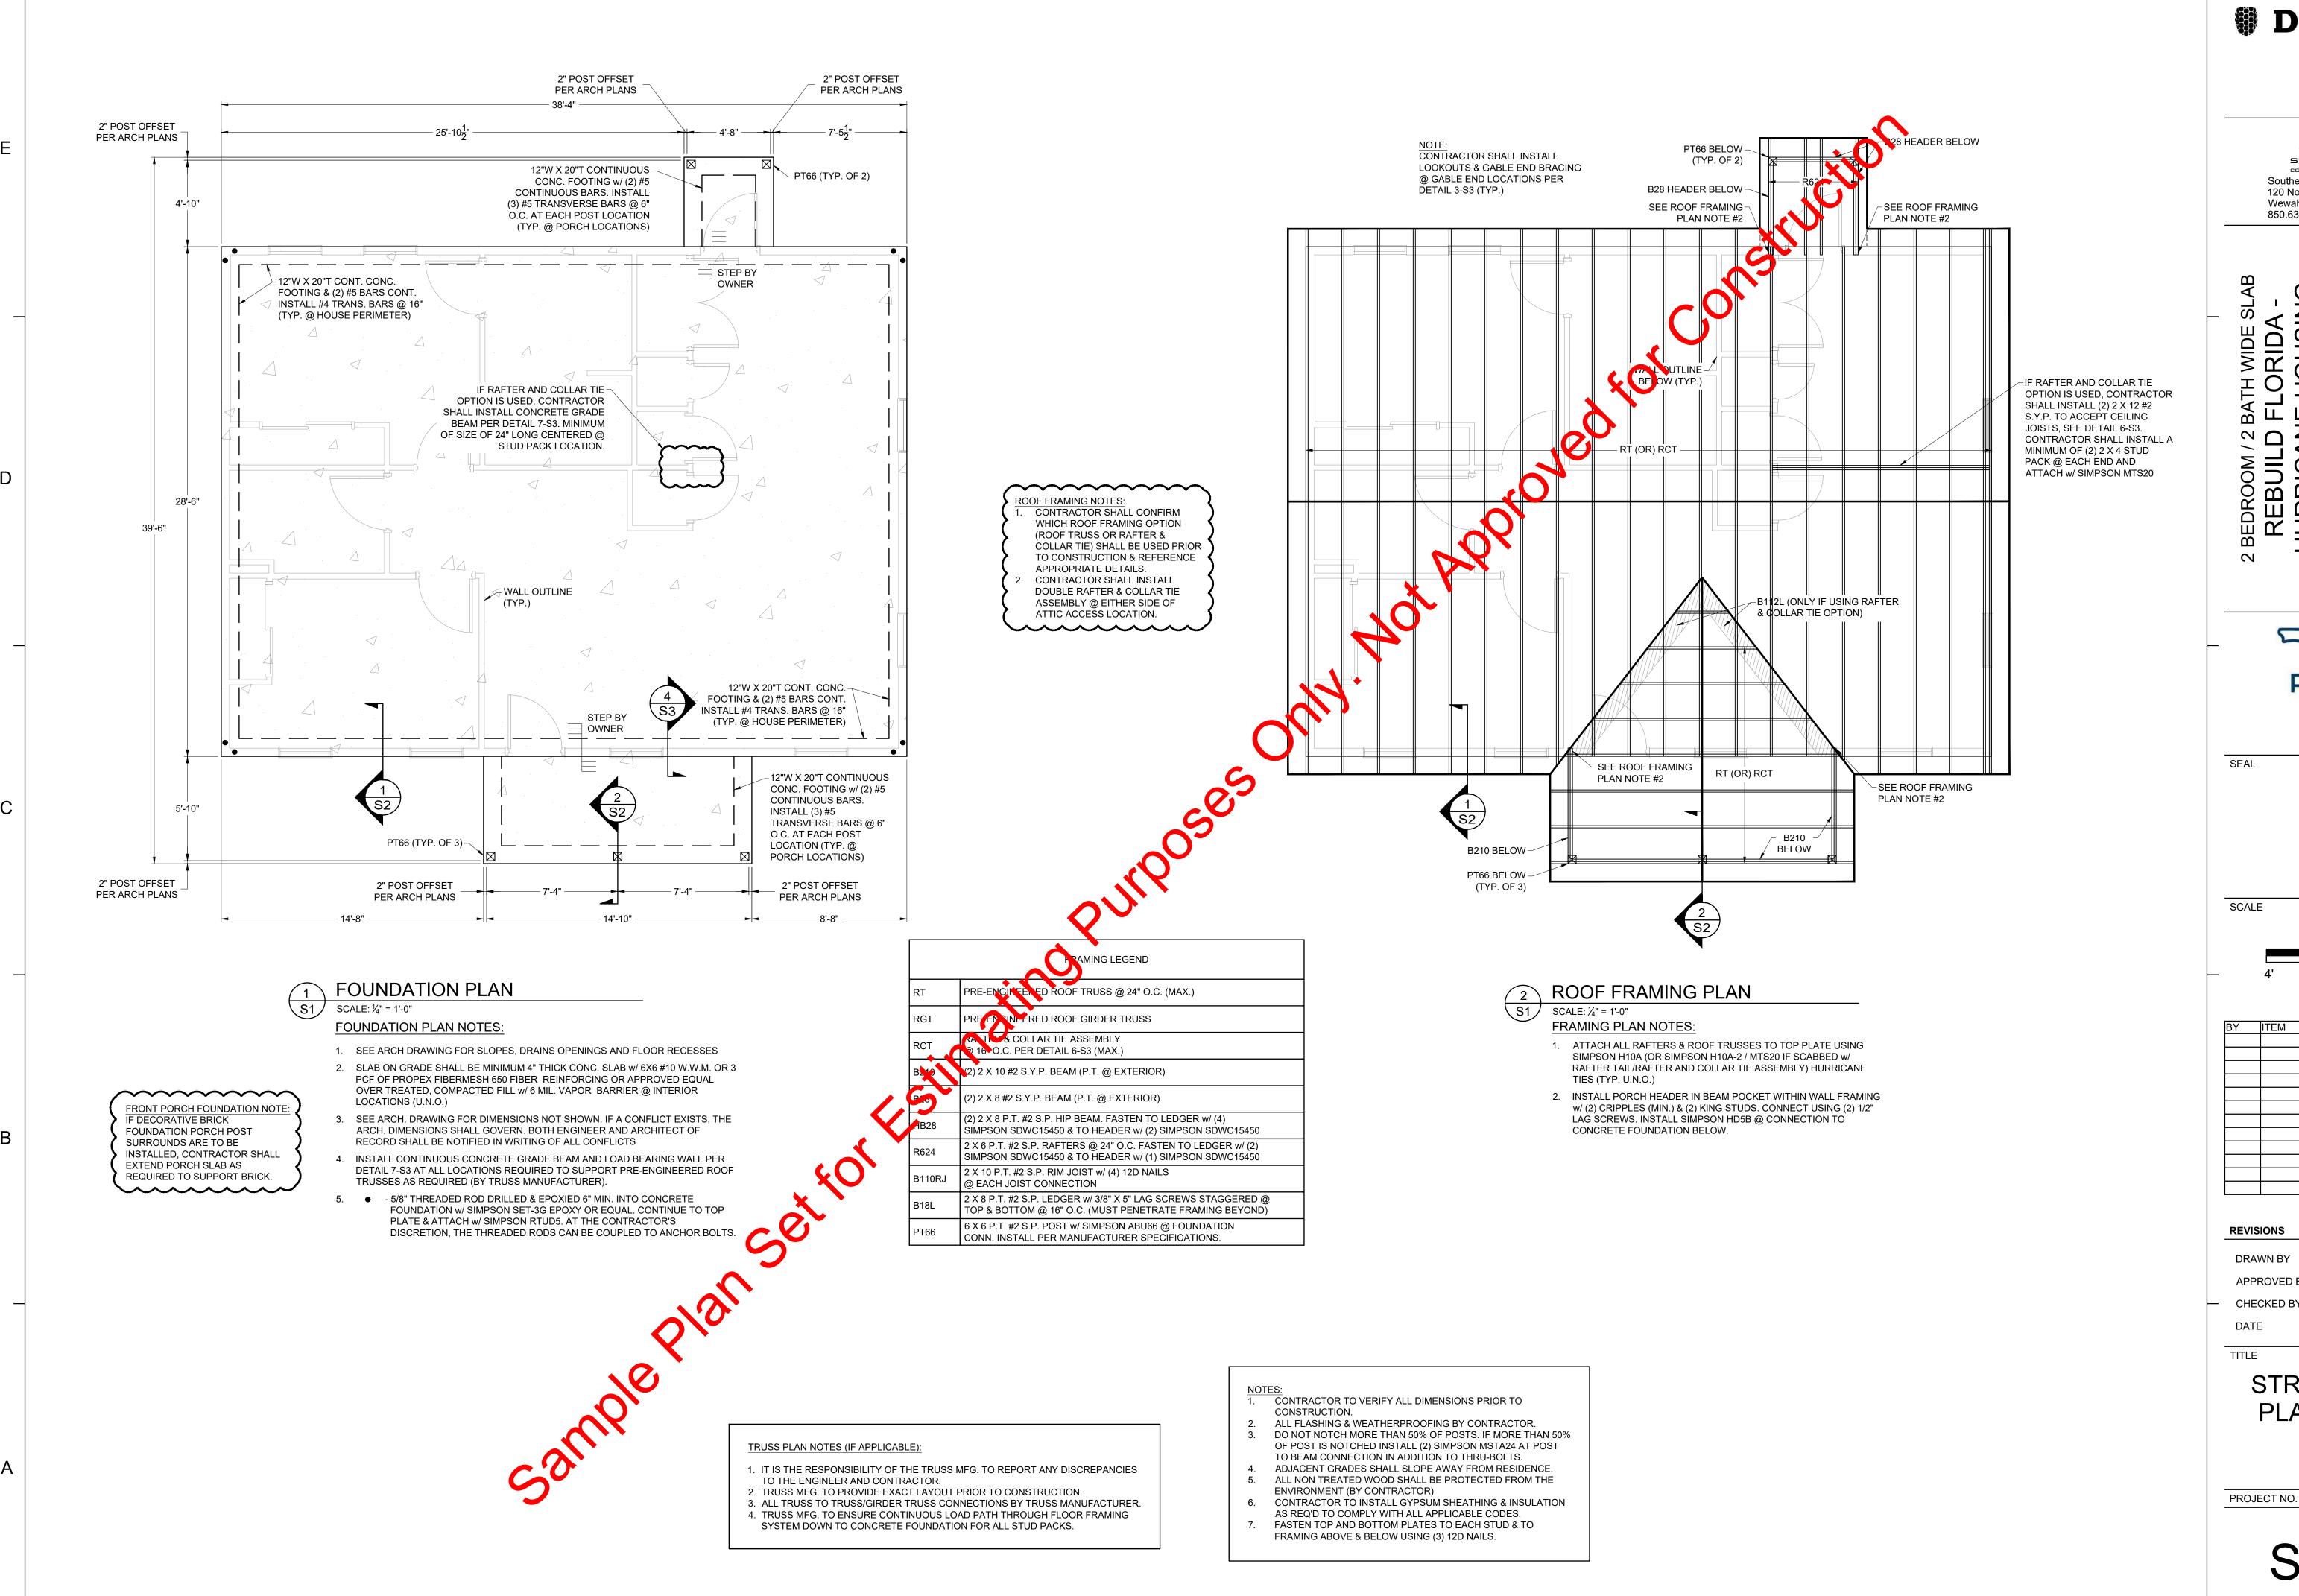

Dewberry Engineers Inc. 877 North County Hwy 393 Santa Rosa Beach, FL 32459 850.267.0759 Phone 850.557.0076 Fax www.dewberry.com

SOUTHEASTERN CONSULTING ENGINEERS, INC. Southeastern Consulting Engineers, Inc. 120 North Highway 71 Wewahitchka, FL 32465 850.639.3860




BY	ITEM	DATE

REVISIONS

APPROVED B CHECKED BY

STRUCTURAL **PLAN VIEWS**

50171913

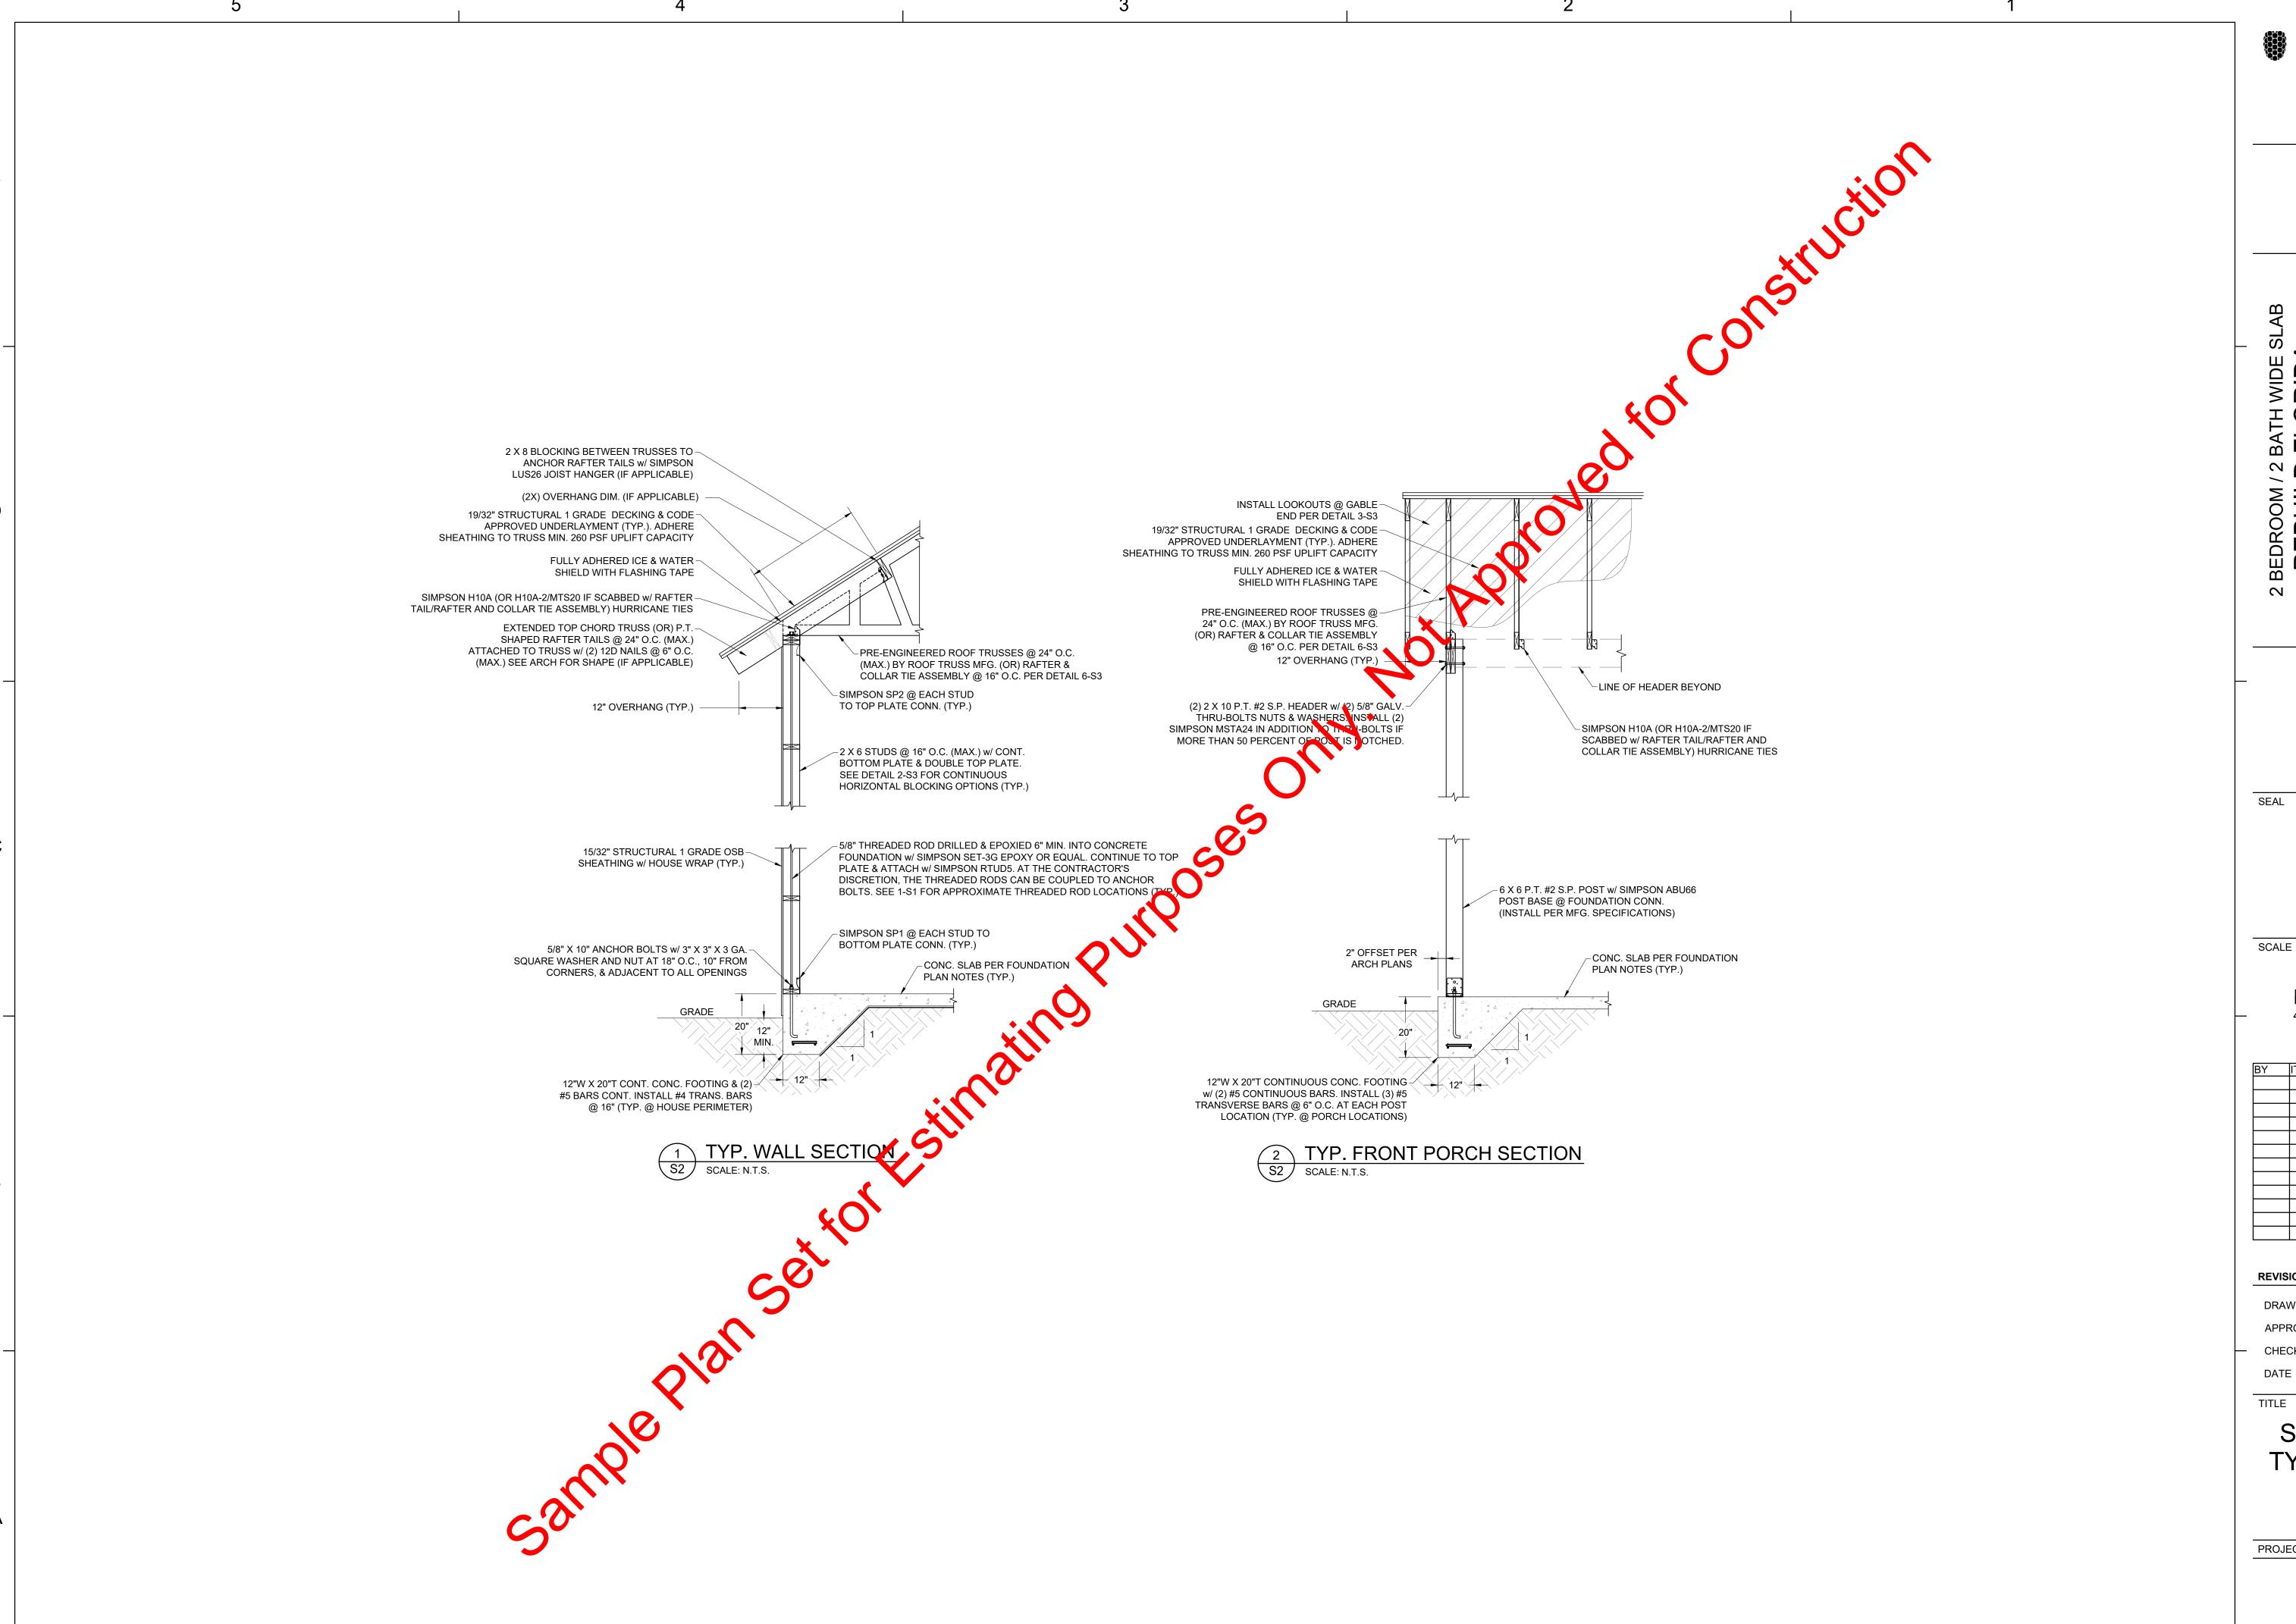

Dewberry Engineers Inc. 877 North County Hwy 393 Santa Rosa Beach, FL 32459 850.267.0759 Phone 850.557.0076 Fax www.dewberry.com

SOUTHEASTERN Southeastern Consulting Engineers, Inc. 120 North Highway 71 Wewahitchka, FL 32465 850.639.3860



SCALE

	BY	ITEM	DATE
l '			


REVISIONS

DRAWN BY APPROVED B CHECKED B

TITLE

STRUCTURAL TYP. SECTIONS

PROJECT NO. 50171913

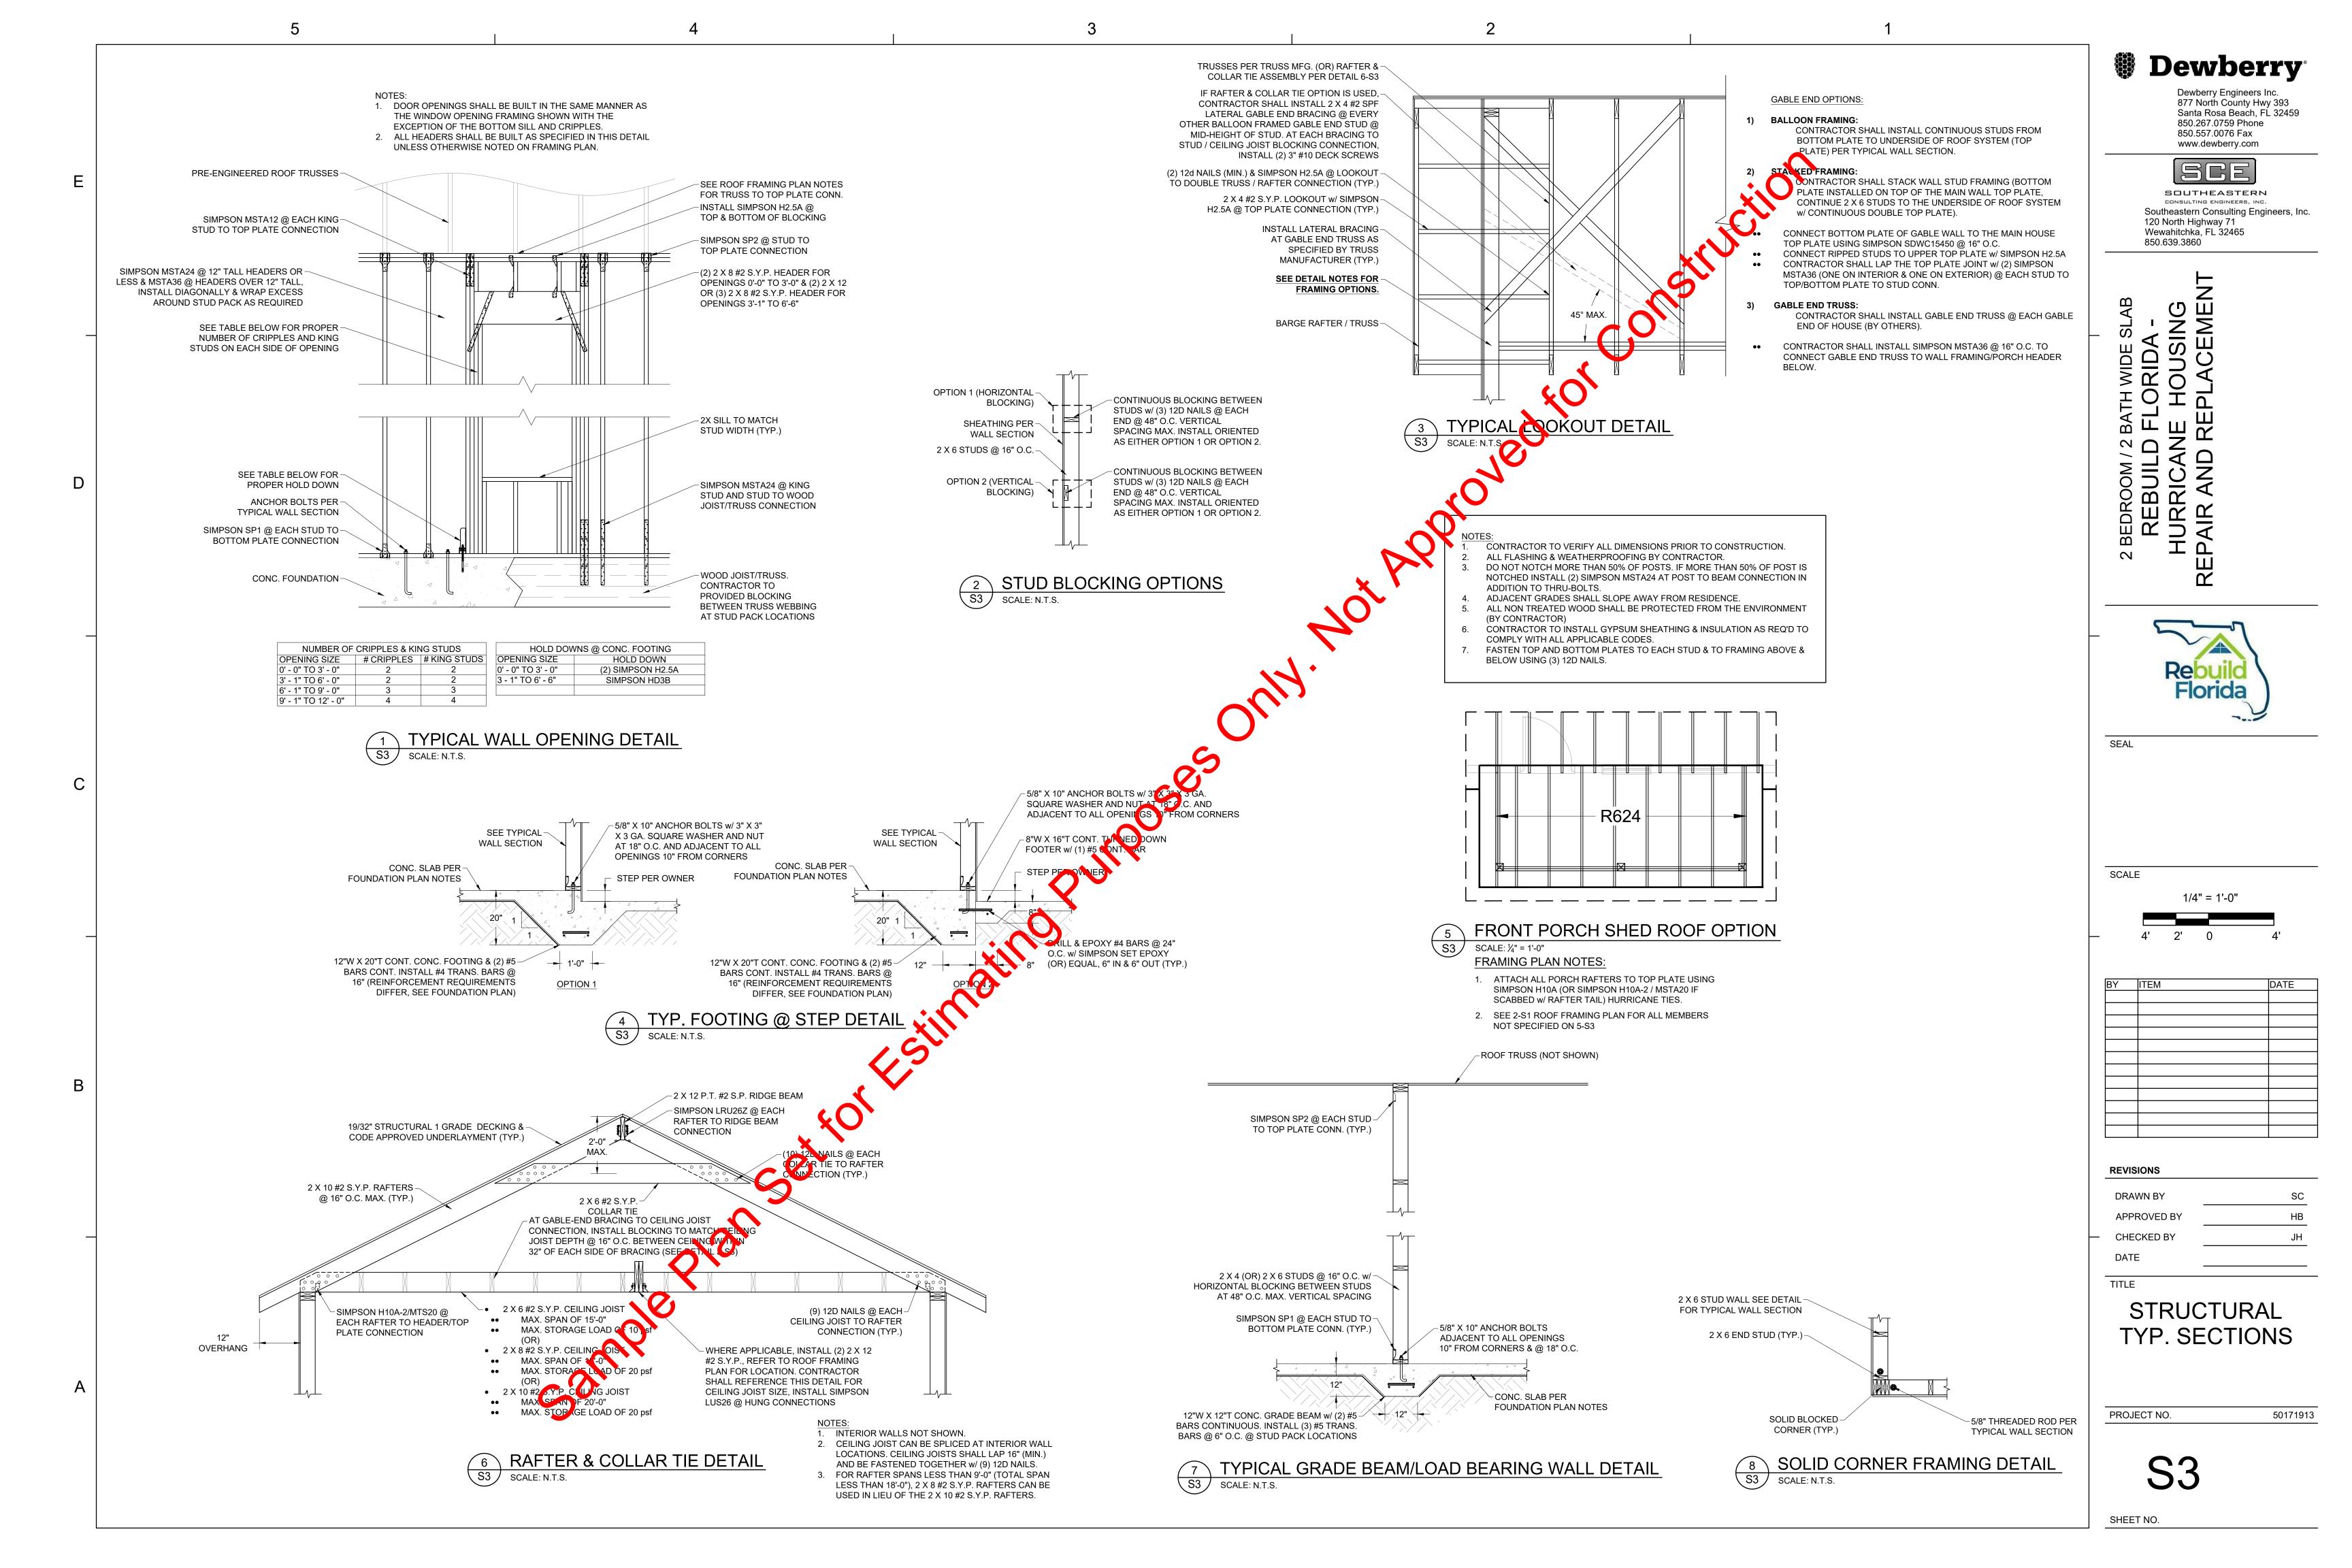

3. FOR DIMENSIONS NOT SHOWN ON THE STRUCTURAL CONTRACT DOCUMENTS, SEE THE ARCHITECTURAL PLANS.

4. THE CONTRACTOR SHALL VERIFY EXISTING SITE CONDITIONS, DIMENSIONS, AND ELEVATIONS PRIOR TO STARTING WORK. THE ENGINEER SHALL BE NOTIFIED IN WRITING OF ANY DISCREPANCIES IN EXISTING SITE CONDITIONS, DIMENSIONS, OR ELEVATIONS TO THOSE SHOWN IN THE STRUCTURAL CONTRACT DOCUMENTS.

THE REVIEW OF SUBMITTALS AND/OR SHOP DRAWINGS BY THE ENGINEER DOES NOT RELIEVE THE CONTRACTOR OF THE

SOLE RESPONSIBILITY TO REVIEW AND CHECK SHOP DRAWINGS PRIOR TO SUBMITTAL TO THE ENGINEER. THE CONTRACTOR REMAINS SOLELY RESPONSIBLE FOR ERRORS AND OMISSIONS ASSOCIATED WITH THE PREPARATION OF SHOP DRAWINGS AS THEY PERTAIN TO MEMBER SIZES, DETAILS, AND DIMENSIONS SPECIFIED IN THE CONTRACT DOCUMENTS. THE CONTRACTOR ALSO SHALL BE RESPONSIBLE FOR MEANS, METHOD, TECHNIQUES, SEQUENCES, AND PROCEDURES OF CONSTRUCTION INCLUDING BUT NOT LIMITED TO DEMOLITION PROCEDURES AND TEMPORARY SHORING.

6. THE CONTRACTOR IS SOLELY RESPONSIBLE FOR THE DESIGN, CONSTRUCTION, AND ERECTION OF SAFE AND ADEQUATE BRACING, SHORING, TEMPORARY SUPPORTS, ETC. REQUIRED FOR STABILITY OF THE STRUCTURE DURING ALL INTERMEDIATE STAGES OF CONSTRUCTION AND/OR DEMOLITION.

7. IN NO CASE SHALL STRUCTURAL ALTERATIONS OR WORK AFFECTING A STRUCTURAL MEMBER BE MADE, UNLESS APPROVED BY THE ENGINEER OF RECORD IN WRITING.

8. NO PROVISION OF ANY REFERENCED STANDARD SPECIFICATION, MANUAL OR CODE (WHETHER OR NOT SPECIFICALLY INCORPORATED BY REFERENCE IN THE CONTRACT DOCUMENTS) SHALL BE EFFECTIVE TO CHANGE THE DUTIES AND RESPONSIBILITIES OF OWNER, CONTRACTOR, ENGINEER, SUPPLIER, OR ANY OF THEIR CONSULTANTS, AGENTS, OR EMPLOYEES FROM THOSE SET FORTH IN THE CONTRACT DOCUMENTS. NOR SHALL IT BE EFFECTIVE TO ASSIGN TO THE STRUCTURAL ENGINEER OF RECORD OR ANY OF THE STRUCTURAL ENGINEER OF RECORD'S CONSULTANTS, AGENTS, OR EMPLOYEES ANY DUTY OR AUTHORITY TO SUPERVISE OR DIRECT THE FURNISHING OR PERFORMANCE OF THE WORK OR ANY DUTY OR AUTHORITY TO UNDERTAKE RESPONSIBILITIES CONTRARY TO THE PROVISIONS OF THE CONTRACT

CONTRACT DOCUMENTS INCLUDE, BUT ARE NOT LIMITED TO, THE STRUCTURAL DOCUMENTS (DRAWINGS AND SPECIFICATIONS), BUT DO NOT INCLUDE SHOP DRAWINGS, VENDOR DRAWINGS, OR MATERIAL PREPARED AND SUBMITTED BY THE CONTRACTOR

10. REFERENCE TO STANDARD SPECIFICATIONS OF ANY TECHNICAL SOCIETY, ORGANIZATION, OR ASSOCIATION OR TO CODES OF LOCAL OR STATE AUTHORITIES, SHALL MEAN THE LATEST STANDARD, CODE, SPECIFICATION OR TENTATIVE SPECIFICATION ADOPTED AT THE DATE OF TAKING BIDS, UNLESS SPECIFICALLY STATED OTHERWISE.

11. CONTRACT DOCUMENTS SHALL GOVERN IN THE EVENT OF A CONFLICT WITH THE CODE OF PRACTICE OR SPECIFICATIONS OF ACI, PCI, AISC, SJI OR OTHER STANDARDS. WHERE A CONFLICT OCCURS WITHIN THE CONTRACT DOCUMENTS, THE STRICTEST REQUIREMENT SHALL GOVERN.

12. MATERIAL, WORKMANSHIP, AND DESIGN SHALL CONFORM TO THE REFERENCED BUILDING CODE.

13. CONTRACTOR SHALL OBTAIN AND COORDINATE EDGE OF SLAB DIMENSIONS, OPENING LOCATIONS AND DIMENSIONS, DEPRESSED SLAB LOCATIONS AND EXTENTS, SLAB SLOPES, CURB LOCATIONS, AND CMU WALL LOCATIONS. ARCHITECT/STRUCTURAL ENGINEER SHALL BE NOTIFIED OF ANY DISCREPANCY OR OMISSION.

14. CONTRACTOR HAS SOLE RESPONSIBILITY FOR MEANS, METHODS, SAFETY, TECHNIQUES, SEQUENCES, AND PROCEDURES OF CONSTRUCTION.

15. CONTRACTOR HAS SOLE RESPONSIBILITY TO COMPLY WITH ALL OSHA REGULATIONS.

16. REPRODUCTION OF STRUCTURAL DRAWINGS FOR SHOP DRAWINGS IS NOT PERMITTED. ELECTRONIC DRAWING FILES WILL NOT BE PROVIDED TO THE CONTRACTOR.

17. SUBMIT SHOP DRAWINGS WHICH ADEQUATELY DEPICT THE STRUCTURAL ELEMENTS AND CONNECTIONS SHOWN IN THE CONTRACT DOCUMENTS. SHOP DRAWINGS SHALL BE SEALED BY ENGINEER LICENSED IN THE PROJECT STATE. REVIEW OF SHOP DRAWINGS SHALL BE FOR CONFORMANCE WITH THE CONTRACT DOCUMENTS REGARDING ARRANGEMENT AND SIZES OF MEMBERS AND THE CONTRACTOR'S INTERPRETATION OF THE DESIGN LOADS AND CONTRACT DOCUMENT DETAILS. REVIEW OF SUBMITTALS OR SHOP DRAWINGS BY THE ARCHITECT/STRUCTURAL ENGINEER DOES NOT RELIEVE THE CONTRACTOR OF THE SOLE RESPONSIBILITY TO REVIEW AND CHECK ALL SUBMITTALS AND SHOP DRAWINGS BEFORE SUBMITTING TO THE STRUCTURAL ENGINEER. REVIEW OF SUBMITTALS OR SHOP DRAWINGS BY THE ARCHITECT/STRUCTURAL ENGINEER DOES NOT RELIEVE THE CONTRACTOR OF FULL RESPONSIBILITY FOR COMPLIANCE WITH THE CONTRACT DOCUMENTS. CONTRACTOR REMAINS SOLELY RESPONSIBLE FOR ERRORS AND OMISSIONS ASSOCIATED WITH THE PREPARATION OF SHOP DRAWINGS AS THEY PERTAIN TO MEMBER SIZES, DETAILS, AND DIMENSIONS SPECIFIED IN THE CONTRACT DOCUMENTS. SHOP DRAWINGS SHALL BE SEALED BY ENGINEER LICENSED IN

PROJECT STATE. 18. WHERE A SECTION OR DETAIL IS SHOWN OR DETAILED FOR ONE CONDITION, IT SHALL APPLY TO ALL SIMILAR AND LIKE CONDITIONS. DETAILS LABELED "TYPICAL" ON THE STRUCTURAL DRAWINGS APPLY TO ALL SITUATIONS OCCURRING ON THE PROJECT THAT ARE THE SAME OR SIMILAR. THE CONTRACTOR SHALL CONSIDER ALL OF THE CONTRACT DOCUMENTS

19. ALL FLASHING AND WATERPROOFING BY CONTRACTOR.

IN DETERMINING SIMILAR AND LIKE CONDITIONS.

. $\,$ ALL ADA REQUIREMENTS SHALL BE ADHERED (IF APPLICABLE) TO AND MAY NOT BE SHOWN ON THESE PLANS IN ITS

OWNER/CONTRACTOR SHALL PROVIDE APPLICABLE FIRE PROTECTION DESIGN/DOCUMENTS NOT SHOWN ON THIS PLAN

21. PLANS DO NOT INCLUDE ANY FIRE ESCAPE PLAN, FIRE SPRINKLER, OR FIRE RELATED DESIGN ASPECTS, U.N.O..

22. OWNER/CONTRACTOR SHALL BE RESPONSIBLE FOR ALL THRESHOLD INSPECTION REQUIREMENTS (IF APPLICABLE).

23. ATTACH STAIR STRINGERS & LANDING FRAMING TO STAIRWELL STUD FRAMING w/ (2) SIMPSON SDWC15600 @ 16" O.C. 24. INSTALL LATERAL BRACING AT GABLE END TRUSS AS SPECIFIED BY TRUSS MANUFACTURER

CODE DESIGN

GENERAL

RECORD OF ANY CONFLICT AND/OR OMISSIONS.

1. WIND LOADS: SEE TABLE

ESTIMATED DEFLECTIONS (IN INCHES) ARE AS FOLLOWS:

DEAD + LIVE LOAD L/240 OR < 1" L/180 **ROOF MEMBERS:** FLOOR MEMBERS: L/360 OR < 1/2"

WHERE, L = SPAN LENGTH (IN INCHES) BETWEEN CENTERLINES OF SUPPORTS. (FOR CANTILEVERS, L IS TWICE THE LENGTH OF THE CANTILEVER.)

FOUNDATION

 FOUNDATION DESIGN IS BASED ON AN ASSUMED ALLOWABLE BEARING PRESSURE OF 2000 PSF. STRUCTURAL ENGINEER IS NOT RESPONSIBLE FOR SUBSURFACE CONDITIONS ENCOUNTERED IN THE FIELD DIFFERENT FROM THOSE ASSUMED

2. ALL FOUNDATION BEARING SOIL SHALL BE COMPACTED TO 98% STANDARD PROCTOR OR 95% MODIFIED PROCTOR AS

SPECIFIED BY AASHTO T-99 AND AASHTO T-180, RESPECTIVELY. 3. UNLESS OTHERWISE NOTED, ALL CONSTRUCTION JOINTS SHALL BE CONSTRUCTED w/ 3/4" X 3/4" (MIN.) KEY WAY. ALL SURFACES SHALL BE CLEANED BEFORE PLACEMENT OF ADJACENT CONCRETE. CONTRACTION JOINTS / SAW CUTS SHALL BE INSTALLED AT 10' O.C. EACH WAY OR NO GREATER THAN 30 TIMES THE SLAB THICKNESS (LESSER OF THE TWO) AND SHALL BE A MINIMUM OF 1/8" WIDE AND TO A DEPTH OF 25% OF THE SLAB THICKNESS (MIN.) UNLESS OTHERWISE NOTED. ALL CONCRETE SLABS LOCATED WITHIN VE FLOOD ZONES SHALL BE SCORED IN 25 SQ. FT. SECTIONS (MAXIMUM). REFER TO F.D.E.P. PERMIT DRAWINGS FOR ALL CONCRETE SLABS LOCATED SEAWARD OF THE COASTAL CONSTRUCTION CONTROL LINE.

4. STRUCTURAL TESTING/INSPECTION AGENCY SHALL CERTIFY THE BEARING MEDIUM BEFORE STARTING CONSTRUCTION.

5. NO FOOTINGS SHALL BE PLACED IN WATER.

6. ANY SOIL CONDITION ENCOUNTERED DURING EXCAVATION THAT IS CONTRARY TO THE CONDITIONS USED FOR DESIGN OF FOOTINGS AS OUTLINED IN THESE NOTES OR ON THE DRAWINGS SHALL BE BROUGHT TO THE ATTENTION OF THE ARCHITECT OR ENGINEER OF RECORD BEFORE PROCEEDING.

7. BACK FILL BOTH SIDES OF FOUNDATION WALLS AT SAME TIME TO PREVENT OVERTURNING.

CONCRETE MASONRY

1. CONCRETE MASONRY WORK SHALL CONFORM TO ACI 530, BUILDING CODE REQUIREMENTS FOR MASONRY STRUCTU AND ACI 530.1, SPECIFICATION FOR MASONRY STRUCTURES.

MORTAR SHALL COMPLY WITH THE BUILDING CODE REQUIREMENTS FOR CONCRETE MASONRY AND SHALL

MINIMUM COMPRESSIVE STRENGTH OF CONCRETE MASONRY SHALL BE F'M = 1,500 PSI.

FOLLOWING TYPE:

WALLS BELOW GRADE TYPE M OR S

4. CONCRETE MASONRY UNITS SHALL BE GROUTED WITH 2,500 PSI COARSE GROUT AS SHOWN IN DOCUMENTS, GROUT SHALL CONFORM TO ASTM C476.

5. PROVIDE HORIZONTAL JOINT REINFORCEMENT WITH NO. 9 GAGE LONGITUDINAL WIRES AT 16" VERTICALLY, UNLESS

NOTED OTHERWISE. PROVIDE SPECIAL ACCESSORIES FOR CORNERS, INTERSECTIONS, ETC. 6. MINIMUM VERTICAL WALL REINFORCEMENT SHALL BE #5 @32" UNLESS NOTED OTHERWISE.

7. DEFECTIVE AREAS IN CONCRETE INCLUDING, BUT NOT LIMITED TO, HONEY-COMBING, SPALLS, AND CRACKS WITH WIDTHS EXCEEDING 0.01 INCH SHALL BE REPAIRED. EXTENTS OF DEFECTIVE AREA TO BE DETERMINED BY THE STRUCTURAL

8. REINFORCING DOWELS MUST BE TIED IN PLACE PRIOR TO POURING FOOTING. "WET-STICKING" IS NOT ALLOWED.

1. REINFORCING STEEL SHALL CONFORM TO ASTM A615, GRADE 60, UNLESS NOTED OTHERWISE

2. WELDED WIRE FABRIC SHALL CONFORM TO ASTM A185 AND HAVE MINIMUM SIDE AND END LAPS OF 8".FOR ALL MONOLITHIC FOOTINGS, A DOUBLE LAYER OF WELDED WIRE FABRIC SHALL BE INSTALLED WITHIN 3'-0" OF

3. REINFORCING STEEL SHALL ONLY BE WELDED OR TACK-WELDED IF IT CONFORMS TO ASTM A706, AND AWS D1.4. REINFORCING SHALL NOT BE WELDED NOR TACK-WELDED UNLESS APPROVED BY THE STRUCTURAL

4. SUBMIT SHOP DRAWINGS WHICH ADEQUATELY DEPICT THE REINFORCING BAR SIZES AND PLACEMENT. WRITTEN DESCRIPTION OF REINFORCEMENT WITHOUT ADEQUATE SECTIONS, ELEVATIONS, AND DETAILS IS

PROVIDE DOWELS FROM FOUNDATIONS THE SAME SIZE AND NUMBER AS THE VERTICAL WALL OR COLUMN REINFORCING, UNLESS NOTED OTHERWISE. REINFORCING DOWELS MUST BE TIED IN PLACE PRIOR TO POURING FOOTING. "WET-STICKING" IS NOT ALLOWED.

6. PLACE REINFORCEMENT AS FOLLOWS, UNLESS NOTED OTHERWISE:

ALL FOOTINGS (3" CLEAR OF OUTSIDE PERIMETER OF FOOTING)

6.1. CAST-IN-PLACE (NON POST-TENSIONED) CONCRETE REINFORCEMENT COVER

PERMANENTLY EXPOSED TO EARTH: CAST AGAINST THE EARTH **EXPOSED TO EARTH OR WEATHER:** FOR BARS LARGER THAN A NO. 5 BAR NO. 5 BARS OR SMALLER COLUMN TIES

6.2. MASONRY REINFORCING STEEL SHALL BE PLACED IN THE CENTER OF CMU CELLS, UNLESS NOTED OTHERWISE.

3" CLEAR


2" CLEAR

1½" CLEAR

1 3/4" CLEAR

REINFORCEMENT SHALL BE SPLICED ONLY AT LOCATIONS SHOWN OR NOTED IN THE STRUCTURAL DOCUMENTS, EXCEPT REINFORCEMENT MARKED "CONTINUOUS" CAN BE SPLICED AT LOCATIONS DETERMINED BY CONTRACTOR. SPLICES AT OTHER LOCATIONS SHALL BE APPROVED IN WRITING BY THE STRUCTURAL ENGINEER. REINFORCING STEEL SPLICES SHALL BE AS FOLLOWS, UNLESS NOTED OTHERWISE:

MINIMUM LAP SPLICE LENGTH (IN.) - 3000 PSI CONCRETE						
	No. 3	No. 4	No. 5	No. 6	No. 7	No. 8
	22	29	36	43	63	72
	MINIMUN	I LAP SPLICE I	ENGTH (IN.) -	1500 PSI NORN	AL WEIGHT C	MU
6-in CMU WALL	19	25	39	81	NA	NA
8-in CMU WALL	19	25	31	57	79	113
12-in CMU WALL	. 19	25	31	53	61	75
RECOMMENDED END HOOKS ANCHORAGE LENGTH (IN.) - 3000 PSI CONCRETE						
	No. 3	No. 4	No. 5	No. 6	No. 7	No. 8
Ъ	2.25	3.00	3 75	4.50	5.25	6.00

 

10

12

14

POST INSTALLED ANCHORS

POST-INSTALLED ANCHORS SHALL ONLY BE USED WHERE SPECIFIED ON THE CONSTRUCTION DOCUMENTS. THE CONTRACTOR SHALL OBTAIN APPROVAL FROM THE ENGINEER-OF-RECORD PRIOR TO INSTALLING POST-INSTALLED ANCHORS IN PLACE OF MISSING OR MISPLACED CAST-IN-PLACE ANCHORS. CARE SHALL BE TAKEN IN PLACING POST-INSTALLED ANCHORS TO AVOID CONFLICTS WITH EXISTING REBAR. HOLES SHALL BE DRILLED AND CLEANED IN ACCORDANCE WITH THE MANUFACTURER'S WRITTEN INSTRUCTIONS. SUBSTITUTION REQUESTS FOR PRODUCTS OTHER THAN THOSE SPECIFIED BELOW SHALL BE SUBMITTED BY THE CONTRACTOR TO THE ENGINEER-OF-RECORD ALONG WITH CALCULATIONS THAT ARE PREPARED & SEALED BY A REGISTERED PROFESSIONAL ENGINEER. THE CALCULATIONS SHALL DEMONSTRATE THAT THE SUBSTITUTED PRODUCT IS CAPABLE OF ACHIEVING THE PERTINENT EQUIVALENT PERFORMANCE VALUES (MINIMUM) OF THE SPECIFIED PRODUCT USING THE APPROPRIATE DESIGN PROCEDURE AND/OR STANDARD(S) AS REQ'D BY THE BUILDING CODE. PROVIDE CONTINUOUS SPECIAL INSPECTION FOR ALL MECHANICAL AND ADHESIVE ANCHORS PER THE APPLICABLE EVALUATION REPORT. CONTACT MANUFACTURER'S REPRESENTATIVE FOR THE INITIAL TRAINING AND INSTALLATION OF ANCHORS AND FOR PRODUCT RELATED QUESTIONS AND AVAILABILITY.

1.1. CONCRETE ANCHORS

A. MECHANICAL ANCHORS SHALL HAVE BEEN TESTED AND QUALIFIED FOR USE IN ACCOMMAND. WITH ACI 355.2 AND ICC-ES AC193 FOR CRACKED AND UNCRACKED CONCRETE RECOGN PRE-APPROVED MECHANICAL ANCHORS INCLUDE: - SIMPSON STRONG-TIE "TITEN-HD" (ICC-ES ESR-2713)

- SIMPSON STRONG-TIE "STRONG-BOLT 2" (ICC-ES ESR-3037)

B. ADHESIVE ANCHORS SHALL HAVE BEEN TESTED AND QUALIFIED FOR USE IN ACCORDANCE WITH ACI 355.4 AND ICC-ES AC308 FOR CRACKED AND UNCRACKED CONCEPTE RECOGNITION. PRE-APPROVED ADHESIVE ANCHORS INCLUDE: - SIMPSON STRONG-TIE "SET-XP" (ICC-ES ESR-2508)

- SIMPSON STRONG-TIE "AT-XP" (IAPMO-ES ER-0263) - HILTI HIT HY150 INJECTION ADHESIVE - EPCON CERAMIC 6 EPOXY ADHESIVE SUPPLIED BY ITW PAINSET/RED HEAD - POWER-FAST EPOXY INJECTION GEL SUPPLIED BY PC WEAR FASTENING

C. POWDER AND GAS-ACTUATED FASTENERS SHALL HAVE LEZN TESTED AND QUALIFIED FOR USE IN ACCORDANCE WITH ICC-ES AC70. PRE-APPROVED POWDER ACTUATED FASTENERS INCLUDE: - SIMPSON STRONG-TIE "POWER-DRIVEN FASTELLERS" (ICC-ES ESR-2138) - SIMPSON STRONG-TIE "GAS-ACTUATED MATTINES" (ICC-ES ESR-2811)

2. MASONRY ANCHORS

2.1 ANCHORAGE TO SOLID-GROUTED CONCRETE MASONRY:

A. MECHANICAL ANCHORS SHALL HAVE BEEN TESTED AND QUALIFIED FOR USE IN ACCORDANCE WITH ICC-ES AC01 OR AC106. PRE-APPRO 150 MECHANICAL ANCHORS INCLUDE: - SIMPSON STRONG-TIE "TITON-HD" (IČC-ES ESR-1056) - SIMPSON STRONG-TIE "STRONG-BOLT 2" (IAMPO-ES ER-0240)
- SIMPSON STRONG TIE "WEL GE-ALL" (ICC-ES ESR-1396)

B. ADHESIVE ANCHORS SHALL HAVE BEEN TESTED AND QUALIFIED FOR USE IN ACCORDANCE WITH ICC-ES AC58. PRE-APPRIVED MECHANICAL ANCHORS INCLUDE: - SIMPSON STRONG-TIE "AT-XP" (IAMPO-ES ER-0281)

- SIMPSON STRENGTIE "SET-XP" (IAMPO-ES ER-0265) - HILTLUT HV 50 NJECTION ADHESIVE AMIC 6 EPOXY ADHESIVE SUPPLIED BY ITW RAMSET/RED HEAD

R-FABIT EPOXY INJECTION GEL SUPPLIED BY POWERS FASTENING 3. ANCHORAGE TO HOLLOW CONCRETE MASONRY:

HESIXE ANCHORS WITH SCREEN TUBES SHALL BE TESTED AND QUALIFIED IN ACCORDANCE WITH S AC58 OR AC60, AS APPROPRIATE. THE APPROPRIATE SCREEN TUBE SHALL BE USED AS MENDED BY THE ADHESIVE MANUFACTURER. PRE-APPROVED ADHESIVE ANCHORS WITH

TUBES INCLUDE: SIMPSON STRONG-TIE "SET" (ICC-ES ESR-1772) SIMPSON STRONG-TIE "AT" (ICC-ES ESR-1958)

· HILTI HIT HY150 INJECTION ADHESIVE - EPCON CERAMIC 6 EPOXY ADHESIVE SUPPLIED BY ITW RAMSET/RED HEAD - POWER-FAST EPOXY INJECTION GEL SUPPLIED BY POWERS FASTENING

ALL DRILLED & EPOXIED $\frac{5}{8}$ " THREADED RODS SHALL MAINTAIN A MINIMUM EDGE DISTANCE OF 1 $\frac{3}{4}$ " AND CLEAR SPACING OF 4" O.C. (MAX.)

CAST-IN-PLACE CONCRETE

ALL CONCRETE HAS BEEN DESIGNED IN ACCORDANCE WITH ACI 318 AND SHALL BE CONSTRUCTED IN ACCORDANCE WITH ACI 301.

2. UNLESS NOTED OTHERWISE, ALL CONCRETE SHALL HAVE A 28 DAY COMPRESSIVE STRENGTH OF 3000 PSI. 3. REFER TO ARCHITECTURAL DRAWINGS FOR MOLDS, GROVES, ORNAMENTS, CLIPS OR GROUNDS REQUIRED TO BE ENCASED IN CONCRETE AND FOR LOCATION OF FLOOR FINISHES AND SLAB DEPRESSIONS.

4. CONSTRUCTION JOINT LOCATIONS SHALL BE APPROVED BY THE STRUCTURAL ENGINEER. NO HORIZONTAL CONSTRUCTION JOINTS ARE PERMITTED EXCEPT THOSE SHOWN ON THE STRUCTURAL DRAWINGS.

DEFECTIVE AREAS IN CONCRETE INCLUDING, BUT NOT LIMITED TO, HONEY-COMBING, SPALLS, AND CRACKS WITH WIDTHS EXCEEDING O.O1 INCH SHALL BE REPAIRED. EXTENT OF DEFECTIVE AREA TO BE DETERMINED BY THE STRUCTURAL ENGINEER

1. ALL HEADERS, BEAMS, POSTS, ETC. HAVE BEEN DESIGNED TO SUPPORT ROOF FRAMING MEMBERS AS SHOWN ON ROOF FRAMING PLAN. IT IS THE RESPONSIBILITY OF THE TRUSS MFG. TO NOTIFY E.O.R. OF ANY DISCREPANCY & PROVIDE FINAL TRUSS LAYOUT TO E.O.R. FOR STRUCTURAL PLAN REVISION IF LAYOUT VARIES FROM THAT SHOWN ON THIS PLAN SET.

1.1. ALL DECK JOISTS HEREIN SHOWN AS 16" O.C. OR GREATER ARE INTENDED FOR 2 X 6 OR 5/4 X 6 WOOD DECKING. IT IS THE CONTRACTORS RESPONSIBILITY, IF USING COMPOSITE DECKING TO INSTALL DECK JOISTS @ 12" O.C. OR AS REQUIRED BY MANUFACTURERS SPECIFICATIONS.

STRUCTURAL GLUED LAMINATED TIMBER SHALL BE PRODUCED IN ACCORDANCE WITH THE AMERICAN INSTITUTE OF TIMBER CONSTRUCTION (AITC). MINIMUM ALLOWABLE BENDING STRESS SHALL BE 2,400 PSI (DRY CONDITIONS).

PROVIDE DRESSED SEASONED LUMBER, S4S, WITH A MAXIMUM MOISTURE CONTENT OF 19% AT TIME OF DRESSING AS LISTED BELOW.

3.1. INTERIOR AND EXTERIOR LOAD-BEARING WALLS:

SPRUCE PINE FUR (SPF) U.N.O.

3.2. LINTELS, FLOOR JOISTS AND BEAMS: SOUTHERN PINE (S.P.), NO. 2 GRADE.

3.3. WOOD IN CONTACT WITH CONCRETE OR MASONRY SHALL BE FOUNDATION GRADE PRESSURE-TREATED. USE GALVANIZED NAILS IN PRESSURE-TREATED WOOD. THE PROTECTIVE COATING ON LIGHT GAUGE STEEL CONNECTIONS IN CONTACT w/ PRESSURE-TREATED WOOD SHALL BE IN ACCORDANCE WITH THE CONNECTOR MANUFACTURERS RECOMMENDATIONS.

4. ENGINEERED LUMBER PRODUCTS

HORIZONTAL SHEAR

HORIZONTAL SHEAR

4.1. PARALLEL STRAND LUMBER (PSL) SHALL HAVE THE FOLLOWING MINIMUM ALLOWABLE

STRESSES AND PROPERTIES: ALLOWABLE BENDING STRESS COMPRESSION PERPENDICULAR TO GRAIN $F_{C\perp} = 750 \text{ PSI}$ COMPRESSION PARALLEL TO GRAIN = 2900 PSI $F_{V} = 290 \, PSI$ HORIZONTAL SHEAR

MODULUS OF ELASTICITY E = 2,000,000 PSI4.2. LAMINATED VENEER LUMBER (LVL) SHALL HAVE THE FOLLOWING MIN STRESSES AND PROPERTIES: ALLOWABLE BENDING STRESS $F_{R} = 2600 \, PSI$

COMPRESSION PERPENDICULAR TO GRAIN $F_{C^{\perp}} = 750 \text{ PS}$ COMPRESSION PARALLEL TO GRAIN HORIZONTAL SHEAR MODULUS OF ELASTICITY

4.3. LAMINATED STRAND LUMBER (LSL) SHALL HAVE THE FOLLOWING MINIMUM ALLOWABLE STRESSES AND PROPERTIES: ALLOWABLE BENDING STRESS COMPRESSION PERPENDICULAR TO PAIN E = 710 PSI COMPRESSION PARALLEL TO GRAIN , = 1835 PSI $F_{V} = 425 \, PSI$

MODULUS OF ELASTICITY GLULAM BEAMS (GLU) SHALL MAV THE FOLLOWING MINIMUM ALLOWABLE STRESSES AND PROPERTIES: ALLOWABLE BENDING STI COMPRESSION PERF INDICE AR TO GRAIN $F_{C\perp} = 805 \, PSI$ TENSION PARALLEL TO RAIN = 1350 PSI

MODULUS OF ELASTICITY E = 2,100,000 PSIPRESERVED GLUL, M BEAMS (GLU) SHALL HAVE THE FOLLOWING MINIMUM ALLOWABLE STRESS 25 VIL PROPERTIES:

E = 1,300,000 PSI

 $F_{V} = 300 \text{ PSI}$

ALLO VABLE BENDING STRESS $F_B = 2400 \, PSI$ COMPRESSION PERPENDICULAR TO GRAIN F_C = 740 PSI HORIZONTAL SHEAR $F_{V} = 300 \text{ PSI}$ MODULUS OF ELASTICITY E = 1,800,000 PS

STRUCTURAL PANELS

1. FLOOR PANELS SHALL BE CONSTRUCTED WITH TONGUE AND GROOVE APA RATED 3/4" PLYWOOD. FLOOR PANELS SHALL BE GLUED AND NAILED w/ 8d RING SHANK NAILS @4" O.C. AT PANEL EDGES AND AT 6" O.C. IN THE FIELD.

WALL PANELS SHALL BE CONSTRUCTED WITH APA RATED SHEATHING, SHEATHING SHALL BE ATTACHED WITH 8d COMMON NAILS @3" O.C. AT PANEL EDGES AND 6" O.C. IN THE FIELD. ALL PANEL EDGES SHALL BE BLOCKED.

ROOF PANELS SHALL BE CONSTRUCTED WITH APA RATED SHEATHING. SHEATHING SHALL BE ATTACHED WITH 8d RING SHANK NAILS @ 3" O.C. AT PANEL EDGES AND AT 6" O.C. IN THE FIELD. ALL PANEL EDGES SHALL BE BLOCKED OR ATTACHED WITH SIMPSON PSCA PANEL SHEATHING CLIPS.

5.4. NAIL HEADS SHALL NOT PENETRATE THE OUTER SURFACE OF SHEATHING.

6. FABRICATED WOOD TRUSSES

DESIGN OF WOOD TRUSSES SHALL BE THE SOLE RESPONSIBILITY OF THE CONTRACTOR. SUBMIT SHOP DRAWINGS, DESIGN LOAD DATA, AND SUPPORT REACTIONS SEALED BY AN ENGINEER LICENSED IN THE PROJECT STATE. REVIEW OF SHOP DRAWINGS SHALL BE FOR CONFORMANCE WITH THE CONTRACT DOCUMENTS WITH REGARD TO TRUSS CONFIGURATION, AND THE CONTRACTOR'S INTERPRETATION OF DESIGN LOADS AND DETAILS. SUCH REVIEW SHALL NOT RELIEVE THE CONTRACTOR OF THE FULL RESPONSIBILITY FOR THE DESIGN OF THE TRUSSES OR TRUSS CONNECTIONS NOT SPECIFICALLY DETAILED IN THE CONTRACT DOCUMENTS.

ERECTION AND BRACING OF PREFABRICATED WOOD TRUSSES SHALL BE IN CONFORMANCE WITH THE RECOMMENDATIONS OF THE TRUSS MANUFACTURER AND THE TRUSS PLATE INSTITUTE'S "BRACING WOOD TRUSSES: COMMENTARY AND RECOMMENDATIONS".

6.3. SECURE EACH COMMON ROOF TRUSS/RAFTER TO TOP PLATE WITH SIMPSON H-10 OR H-7 HURRICANE CLIP AT ALL BEARING POINTS. USE SIMPSON H-7 AT GIRDER TRUSSES. PROVIDE A MINIMUM OF TWO STUDS UNDER GIRDER TRUSS END BEARING.

TRUSSES ON SITE PRIOR TO INSTALLATION SHALL BE STORED IN A VERTICAL POSITION WITH SUPPORT POINTS PROVIDED AT FINAL BEARING POINTS AND BRACED TO AVOID 6.5. INSTALLATION OF ALL TRUSSES SHALL BE DONE USING A SPREADER BAR WITH A THREE

POINT VERTICAL PICK AND CARE IS TO BE USED IN LIFTING TO MINIMIZE HORIZONTAL

6.6. IMPROPER HANDLING OF THE TRUSSES AS NOTED ABOVE AND IN THE SPECIFICATIONS SHALL MEAN REMOVAL OF THE TRUSSES FROM THE JOB SITE.

6.7. TRUSS TO TRUSS CONNECTIONS SHALL BE VERIFIED BY THE TRUSS DESIGNER.

6.8. EXPOSED TRUSSES SHALL BE DELIVERED TO THE JOB SITE UNBLEMISHED AND SUITABLE FOR FIELD PAINTING. 6.9. CONTRACTOR TO REFER TO "STANDARD FOR HURRICANE RESISTANT CONSTRUCTION

SSTD 10-99 FOR FRAMING REQUIREMENTS OF WOOD FRAMED WALL SYSTEMS, TABLE 6.10. ALL FLOOR TRUSS DESIGN LOADS SHALL BE PER TRUSS MANUFACTURER. THE LOADS REFERENCED WITHIN THE FOLLOWING "STRUCTURAL LOADS" SECTION REPRESENTS THE LOADS USED FOR THE DESIGN OF STRUCTURAL MEMBERS SUPPORTING FLOOR

AND ROOF TRUSSES. 7. CONNECTIONS

> CONNECTIONS FOR STRUCTURAL TIMBER SHALL BE GALVANIZED STRONG TIE CONNECTORS BY THE SIMPSON COMPANY OR APPROVED EQUAL. CONNECTORS SHALL FOLLOW MANUF. CORROSION PROTECTION RECOMMENDATIONS.

7.2. THE NUMBER OF FASTENERS PER CONNECTION SHALL BE THE MAX. ALLOWED FOR THAT PARTICULAR FASTENER.

STRUCTURAL LOADS:

SUPERIMPOSED DEAD LOADS (RESIDENTIAL CONSTRUCTION) PORCH 10 PSF

SUPERIMPOSED LIVE LOADS (RESIDENTIAL CONSTRUCTION):

ATTICS w/ STORAGE ATTICS w/o STORAGE HABITABLE ATTICS & BEDRO ALL OTHER ROOMS

DECKS FLOOR ROOF WIND LOADS AS

160 MPH 124 MPI POSURE CATEGORY

ITERNAL PRESSURE COEFFICIENT MPACT GLASS WINDOWS & DOORS


MAIN WIND FRAME RESISTING SYSTEM (MWFRS)				
AREA	INTERIOR ZONE	END ZONE		
WALLS	38.23 PSF	47.79 PSF		
ROOF	± 26.46 PSF	± 33.08 PSF		

COMPONENTS AND STADDING BOOK DRESSURES (DSC

15 PSF


COMPONENTS AND CLADDING ROOF PRESSURES (PSF)								
ZONE		+ GCpi			- GCpi			
R	OOF (ZONE	1)		26.98			-58.12	
R	OOF (ZONE	2)	26.98			-92.71		
R	OOF (ZONE	3)	26.98			-110.01		
		COMPON	ENTS AND	CLADDING V	WALL PRES	SURES (PS	F)	
0 SF - 10 SF		10 SF	- 30 SF	30 SF	- 60 SF	60 SF	- 100 SF	
ZONE	+ GCpi	- GCpi	+ GCpi	- GCpi	+ GCpi	- GCpi	+ GCpi	- GCpi
4	40.82	-44.28	40.82	-44.28	37.91	-41.37	36.07	-39.53
5	40.82	-54.66	40.82	-54.66	37.91	-48.83	36.07	-45.15

NOTE: ALL PRESSURES SHOWN ARE BASED UPON ASD DESIGN, WITH A LOAD FACTOR OF 0.6.

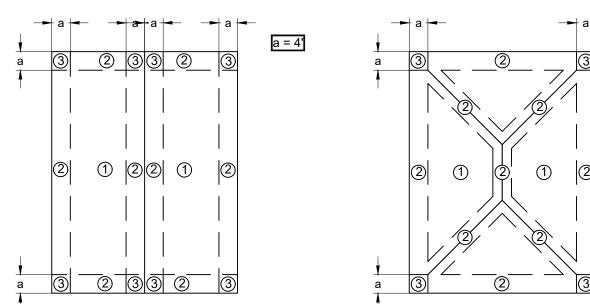

GABLED ROOF

HIPPED ROOF

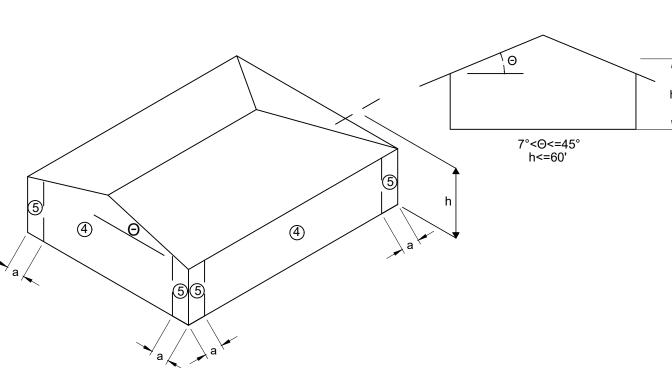

CERTIFICATION

THE STRUCTURE SHOWN ON THESE PLANS IS DESIGNED IN ACCORDANCE WITH FLORIDA BUILDING

N.T.S. = NOT TO SCALE

C.I.P. = CAST IN PLACE

S.S. = STAINLESS STEEL

BTM. = BOTTOM

TYP. = TYPICAL

REQ'D = REQUIRED

E.O.R. = ENGINEER OF RECORD

<u>ABBREVIATIONS</u>

CONC. = CONCRETE WWM = WELDED WIRE MESH CONT. = CONTINUOUS CMU = CONCRETE MASONRY UNIT P.T. = PRESSURE TREATED N.T.S. = NOT TO SCALE BTW = BETWEEN

CODE 8TH EDITION (2023).

SIM = SIMILAR LOC = LOCATION CONT. = CONTINUOUS

U.N.O. = UNLESS NOTED OTHERWISE L.B.W. = LOAD BEARING WALL HCA = HEADED CONCRETE ANCHOR MFG. = MANUFACTURER

	SHEARWALL/SHEATHING NAIL SCHEDULE (U.N.O.)				
WALLS	8d (0.131" x 2-1/2")	3" O.C. EDGE 6" O.C. FIELD			
ROOF	8d "RING SHANK" (0.131" X 2-1/2")	3" O.C. EDGE 6" O.C. FIELD			
TONG	TONGUE & GROOVE SHEATHING, IF APPLICABLE (U.N.O.)				
WALLS	(2) 3" #9 DECK SREWS	EACH STUD CONN.			
ROOF	(2) 3" #9 DECK SREWS	EACH TRUSS/RAFTER CONN.			

877 North County Hwy 393 Santa Rosa Beach, FL 32459 850.267.0759 Phone 850.557.0076 Fax www.dewberry.com

SOUTHEASTERN CONSULTING ENGINEERS, INC Southeastern Consulting Engineers, Inc. 120 North Highway 71 Wewahitchka, FL 32465 850.639.3860



SEAL

SCALE

REVISIONS

DRAWN BY APPROVED B CHECKED B

STRUCTURAL

PROJECT NO. 50171913

PER SECTION 471.003(2)(H), F.S., ALL MECHANICAL, ELECTRICAL, AND PLUMBING **GENERAL NOTES** ARE EXEMPT FROM PROFESSIONAL ENGINEERING SERVICES FOR THIS PROJECT. IT IS THE RESPONSIBILITY OF THE CONTRACTOR TO PERMIT AND CONSTRUCT THE APPLICABLE SYSTEM IN ACCORDANCE WITH FLORIDA PLUMBING NOTES: BUILDING CODE, LOCAL CODE REQUIREMENTS AND PROGRAMMATIC PLUMBING CONSTRUCTION DOCUMENTS SHALL BE SUBMITTED BY THE PLUMBING SUBCONTRACTOR FOR PERMITTING TO THE AUTHORITY HAVING JURISDICTION.

PLUMBING CONTRACTOR SHALL BE LICENSED AND RESPONSIBLE TO MEET ALL APPLICABLE
REQUIREMENTS OF THE FLORIDA BUILDING CODE AND THE LOCAL CODE REQUIREMENTS OF THE
JURISDICTION WHERE THE PROJECT WILL BE LOCATED.

ALL PLUMBING FIXTURES AND PIPING MATERIALS AND INSTALLATION SHALL CONFORM TO THE LOCAL REQUIREMENTS. IT IS THE RESPONSIBILITY OF THE CONTRACTOR TO PERMIT THE PROJECT WITH ALL AUTHORITIES HAVING JURISDICTION (AHJ). INFORMATION SHOWN PROVIDES MINIMUM PROGRAMMATIC REQUIREMENTS AND ARE GENERAL IN NATURE. DRAWINGS ARE SCHEMATIC IN NATURE AND PLUMBING CODES. INSULATE ALL PIPING AS REQUIRE BY THE FLORIDA BUILDING CODE.

USE WATER-CONSERVING FIX URES MEETING THE FOLLOWING WATERSENSE REQUIREMENTS:

a. TOILETS = 1.28 GPF FINAL PERMITTING AND CONSTRUCTION OF THE SYSTEM IS THE RESPONSIBILITY OF THE CONTRACTOR. ALL EQUIPMENT AND PRODUCTS SHALL a. TOILETS = 1.28 GPF
b. SHOWER HEADS + 2.0 PM
c. KITCHEN FAUCHTS + 2 GPM
d. BATHROOM FAUCETS = 1.5 GPM
e. WATER CLOSETS MUST HAVE A MINIMUM MAP RATING OF 600 GRAMS PER FLUSH.
COORDINATE FITTURES AND LOCATIONS WITH ARCHITECTURAL PLANS AND OWNER.
PROVIDE SERVICE CONNECTIONS TO THE LOCAL UTILITY THAT COMPLY WITH THE SERVICE AUTHORITY & REQUIREMENTS.
COORDINATE HOT WATER HEATER LOCATION AND PROVIDE PLASTIC DRAIN/DRIP PAN WITH DRAIN TO THE BUILDING EXTERIOR IN A CONSPICUOUS LOCATION. WATER HEATER SHALL BE MINIMUM 50 CALLON CALACITY AND ENERGY STAR LISTED.
COORDINATE HOSE BIBB LOCATIONS (MINIMUM OF 2 EXTERIOR HOSE BIBBS SHALL BE PROVIDED).
ROVIDE "NO-DRIP" SUPPLY/DRAIN AT WASHING MACHINE.
PRESIDE ACCESS PANELS TO TUB/SHOWER PLUMBING LINES/VALVE.
PERFORM ALL REQUIRED TESTS PRIOR TO INSTALLING PIPE INSULATION, BACKFILLING, OR INSTALLING TOILETS = 1.28 GPF BE SELECTED BY THE CONTRACTOR. PERFORM ALL REQUIRED TESTS PRIOR TO INSTALLING PIPE INSULATION, BACKFILLING, OR INSTALLING PROVIDE ALL CLEAN-OUTS, EXPANSION TANKS, VACUUM BREAKERS, AND OTHER MISCELLANEOUS COMPONENTS REQUIRED FOR A COMPLETE AND FUNCTIONAL SYSTEM WHETHER SHOWN ON DRAWINGS OR NOT. PROVIDE SHUT-OFF VALVES TO ALL FIXTURES. ALL PENETRATIONS THROUGH THE ROOF SHALL BE FLASHED AND SEALED USING PREFORMED RUBBER BOOTS. PLUMBING SUBCONTRACTOR SHALL PROVIDE AND INSTALL DRAIN PIPING FOR ALL HVAC EQUIPMENT. DISCHARGE TO GRADE. DO NOT CONNECT TO SANITARY PIPING. ALL DRAIN LINES SHALL HAVE WATER SEAL TRAPS AS REQUIRED BY CODE. ALL PLUMBING FIXTURES AND GROUPS SHALL BE VENTED IN ACCORDANCE WITH THE CURRENT VERSION OF THE FLORIDA BUILDING CODE. ALL SANITARY SEWER PIPING SHALL BE SOLID-CORE, SCHEDULE 40 PVC DWV PIPE WITH APPROPRIATE FITTINGS. MINIMUM SLOPE OF THE SANITARY SEWER PIPING SHALL BE MAINTAINED PER CODE. AVOID ROUTING PIPE THROUGH BUILDING FOOTINGS. WHERE CONFLICTS ARE UNAVOIDABLE, ROUTE PIPING A MINIMUM OF 12" BELOW FOOTING. HOT- AND COLD-WATER SUPPLY PIPING SHALL BE CPVC WITH APPROVED FITTINGS. PLUMBING CONSTRUCTION DRAWINGS SHALL INDICATE THE LOCATION OF CLEAN-OUTS AND CONNECTIONS TO EXISTING UTILITIES INCLUDING WATER AND SANITARY SEWER FOR REVIEW BY THE AUTHORITY HAVING JURISDICTION. HOT & COLD WATER PIPING AND SANITARY DRAIN TRAPS SHALL NOT BE INSTALLED IN ANY LOCATION KITCHEN SINK TO HAVE ENERGY STAR GARBAGE DISPOSAL. PLUMBER SHALL COORDINATE WITH ELECTRICIAN FOR INSTALLATION. -USE PIPE BOOT @ ALL ROOF PENETRATIONS (TYP) 1 1/2"— 2" KITCHEN SINK & DISHWASHER-4" WC-FIRST FLOOR **RISER DIAGRAM** NOT TO SCALE



Dewberry

Dewberry Engineers Inc. 877 North County Hwy 393 Santa Rosa Beach, FL 32459 850.267.0759 Phone 850.557.0076 Fax www.dewberry.com

SEAL

SCALE

-2" WASHING

MACHINE

As indicated

Description REVISIONS DRAWN BY ETO APPROVED BY

TITLE **GENERAL INFORMATION**

2BR WIDE

P0.1

50171913

SHEET NO.

PROJECT NO.

CHECKED BY

HVAC CONSTRUCTION DOCUMENTS SHALL BE SUBMITTED BY THE HVAC SUBCONTRACTOR FOR PERMITTING TO THE

HVAC CONTRACTOR SHALL BE LICENSED AND RESPONSIBLE TO MEET ALL APPLICABLE REQUIREMENTS OF THE

FLORIDA BUILDING CODE AND THE LOCAL CODE REQUIREMENTS OF THE JURISDICTION WHERE THE PROJECT WILL BE

ONDENSATE DRAIN PANS, OVERFLOW SWITCHES, AND PIPING CONSTRUCTION DRAWINGS SHALL BE BASED ON THE LOCATION AND ORIENTATION OF THE PROPOSED SITE. HVAC YSTEM THALL BE SIZED BASED ON ACCA MANUAL J AND S, LATEST EDITION. CONTRACTOR SHALL PROVIDE

LL DUCTS AND PLENUMS SHALL BE MADE AIR TIGHT. SEAL ALL DUCT SEAMS USING TAPE AND MASTIC OVER JOINTS. CONSTRUCT AND INSTALL DUCTWORK IN COMPLIANCE WITH THE FLORIDA BUILDING CODE, LATEST EDITION. MAXIMUM DUCT LEAKAGE SHALL NOT EXCEED 5% OF RATED AIFLOW, OR AS REQUIRED BY LOCAL CODES. PROTECT OPEN DUCTS DURING CONSTRUCTION TO MINIMIZE DUST AND DEBRIS USING BLUE MAX OR EQUAL DUCT

REQUIREMENTS FOR THE PRESSURE CLASS REQUIRED. MAXIMUM LENGTH OF FLEX DUCT SHALL BE 5'. THE HVAC CONTRACTOR SHALL DESIGN THE DUCT SYSTEM BASED ON ACCA MANUAL D, LATEST EDITION. INSULATE DUCTWORK AS REQUIRED BY FLORIDA BUILDING CODE BUT NOT LESS THAN R-6. FLEXIBLE DUCTS SHALL BE EXTENDED FULLY. EXCESS DUCT MATERIAL SHALL BE LIMITED TO LESS THAN 5%.

INSTALL FLEXIBLE DUCT PER MANUFACTURER'S RECOMMENDATIONS INCLUDING JOINING, SEALING, LIMITATIONS OF

INSTALL FIRE AND SMOKE DAMPERS WHERE REQUIRED BY LOCAL CODES AND ASSEMBLY PENETRATIONS.

INSTALL SMOKE DETECTORS WHERE REQUIRED BY LOCAL CODES.

PLUMBING SUBCONTRACTOR SHALL PROVIDE A MEANS OF CONDENSATE DISPOSAL FOR EACH PIECE OF HVAC

CONDENSATE DISPOSAL SYSTEM SHALL BE DESIGNED AND INSTALLED IN ACCORDANCE WITH THE FLORIDA BUILDING

PRIMARY CONDENSATE PIPING LOCATED WITHIN THE BUILDING ENVELOPE SHALL BE INSULATED USING 3/4" CLOSED

ALL CONDENSATE DISPOSAL PIPING SHALL BE TESTED DURING HVAC EQUIPMENT STARTUP.

HEAT PUMP AND AIR-HANDLING UNIT SHALL BE INSTALLED IN ACCORDANCE WITH THE FLORIDA BUILDING CODE AND

AND TIED DOWN AS REQUIRED BY THE FLORIDA BUILDING CODE USING APPROVED HURRICANE STRAPS. THE MANUFACTURER'S RECOMMENDED CLEARANCES SHALL BE MAINTAINED ON ALL SIDES OF HEAT PUMP AND AIR-

HEAT PUMP AND AIR-HANDLING UNITS SHALL BE INSTALLED PER THE MANUFACTURER'S RECOMMENDATIONS AND IN

EQUIPMENT ACCESS SHALL NOT BE REDUCED BY REFRIGERANT PIPING, CONDENSATE DRAINS, OR OTHER

EXHAUST DUCTS FOR BATHROOMS, POWDER ROOMS, AND KITCHEN HOODS SHALL TERMINATE AT THE BUILDING

TOILET EXHAUST FANS SHALL BE FURNISHED WITH BACKDRAFT DAMPERS.

TOILET EXHAUST FANS SHALL BE CONTROLLED BY MANUALLY OPERATED TIMERS.

DRYER EXHAUST DUCT SHALL BE ROUTED TO THE BUILDING EXTERIOR PER THE FLORIDA BUILDING CODE AND MANUFACTURER RECOMMENDATIONS. INSTALL BOOSTER FAN AS REQUIRED AND AS ALLOWED BY CODE. VENTILATION AIR DUCT SHALL BE CONNECTED TO THE RETURN AIR PLENUM.

VENTILATION AIR DUCT SHALL INCLUDE A MANUAL VOLUME DAMPER AND A NORMALLY CLOSED ISOLATION DAMPER THE VENTILATION ISOLATION DAMPER SHALL BE WIRED TO OPEN WHENEVER ASSOCIATED AHU IS TURNED ON.

VENTILATION AIR INTAKE SHALL BE LOCATED IN ACCORDANCE WITH THE FLORIDA BUILDING CODE. AND SHALL BE A MINIMUM OF 10 FEET FROM EXHAUST TERMINATIONS, A MINIMUM OF 10 FEET FROM PLUMBING VENTS, A MINIMUM OF 3 FEET FROM OPERABLE WINDOWS AND DOORS, AND A MINIMUM OF 3 FEET FROM PROPERTY LINES.

AIR HANDLING UNIT SCHEDULE								
	4 D E 4 O E D) (E D	MODEL 0175	EVE 0D: W			AUX HEATERS		DEMARKS
MARK	AREA SERVED	EA SERVED MODEL SIZE EXT SP in Wg	EXT SP in Wg FAN TYPE \	V/PH/HZ	STAGES	V/PH/HZ	REMARKS	
AHU-1	ENTIRE HOUSE	SEE REMARKS	-	FC	230/1/60	1	230/1/60	1,2,3

2. PROVIDE SEVEN DAY PROGRAMMABLE THERMOSTAT, MERV 8 FILTER, AND ELECTRIC RESISTANCE HEAT.

EXHAUST FAN SCHEDULE						
MARK	TYPE	CFM	SP in Wg	DRIVE	VOLTS/PH/HZ	REMARKS
EF-1	CEILING	50	0.25	DIRECT	115/1/60	1,2,3,4

- 2. PROVIDE BACKDRAFT DAMPER, INLET GRILLE, SPEED CONTROLLER, AND DISCHARGE WALL CAP OR ROOF JACK.
- 4. PROVDE EXHAUST FAN WITH MANUALLY OPERATED TIMER.

HEAT PUMP SCHEDULE				
MARK	NOMINAL TONS	SYSTEM SERVED	V/PH/HZ	REMARKS
HP-1	SEE REMARKS	AHU-1	208/230/1/60	1,2,3

- 1. MODEL TO BE SELECTED BY CONTRACTOR
- 2. UNIT SHALL BE MINIMUM 16 SEER.
- 3. REQUIRED NOMINAL TONS FOR HEAT PUMP MUST MATCH THAT FOR AIR HANDLER UNIT.



Dewberry Engineers Inc. 877 North County Hwy 393 Santa Rosa Beach, FL 32459 850.267.0759 Phone 850.557.0076 Fax www.dewberry.com



SCALE

As indicated


No.	Description	Date

NO.	Description	Date
REVISIONS		
DRAWN BY		ETO
APPROVED	BY	CLS
CHECKED B	Υ	CLS
DATE		

GENERAL INFORMATION 2BR WIDE

PROJECT NO. 50171913

M0.1

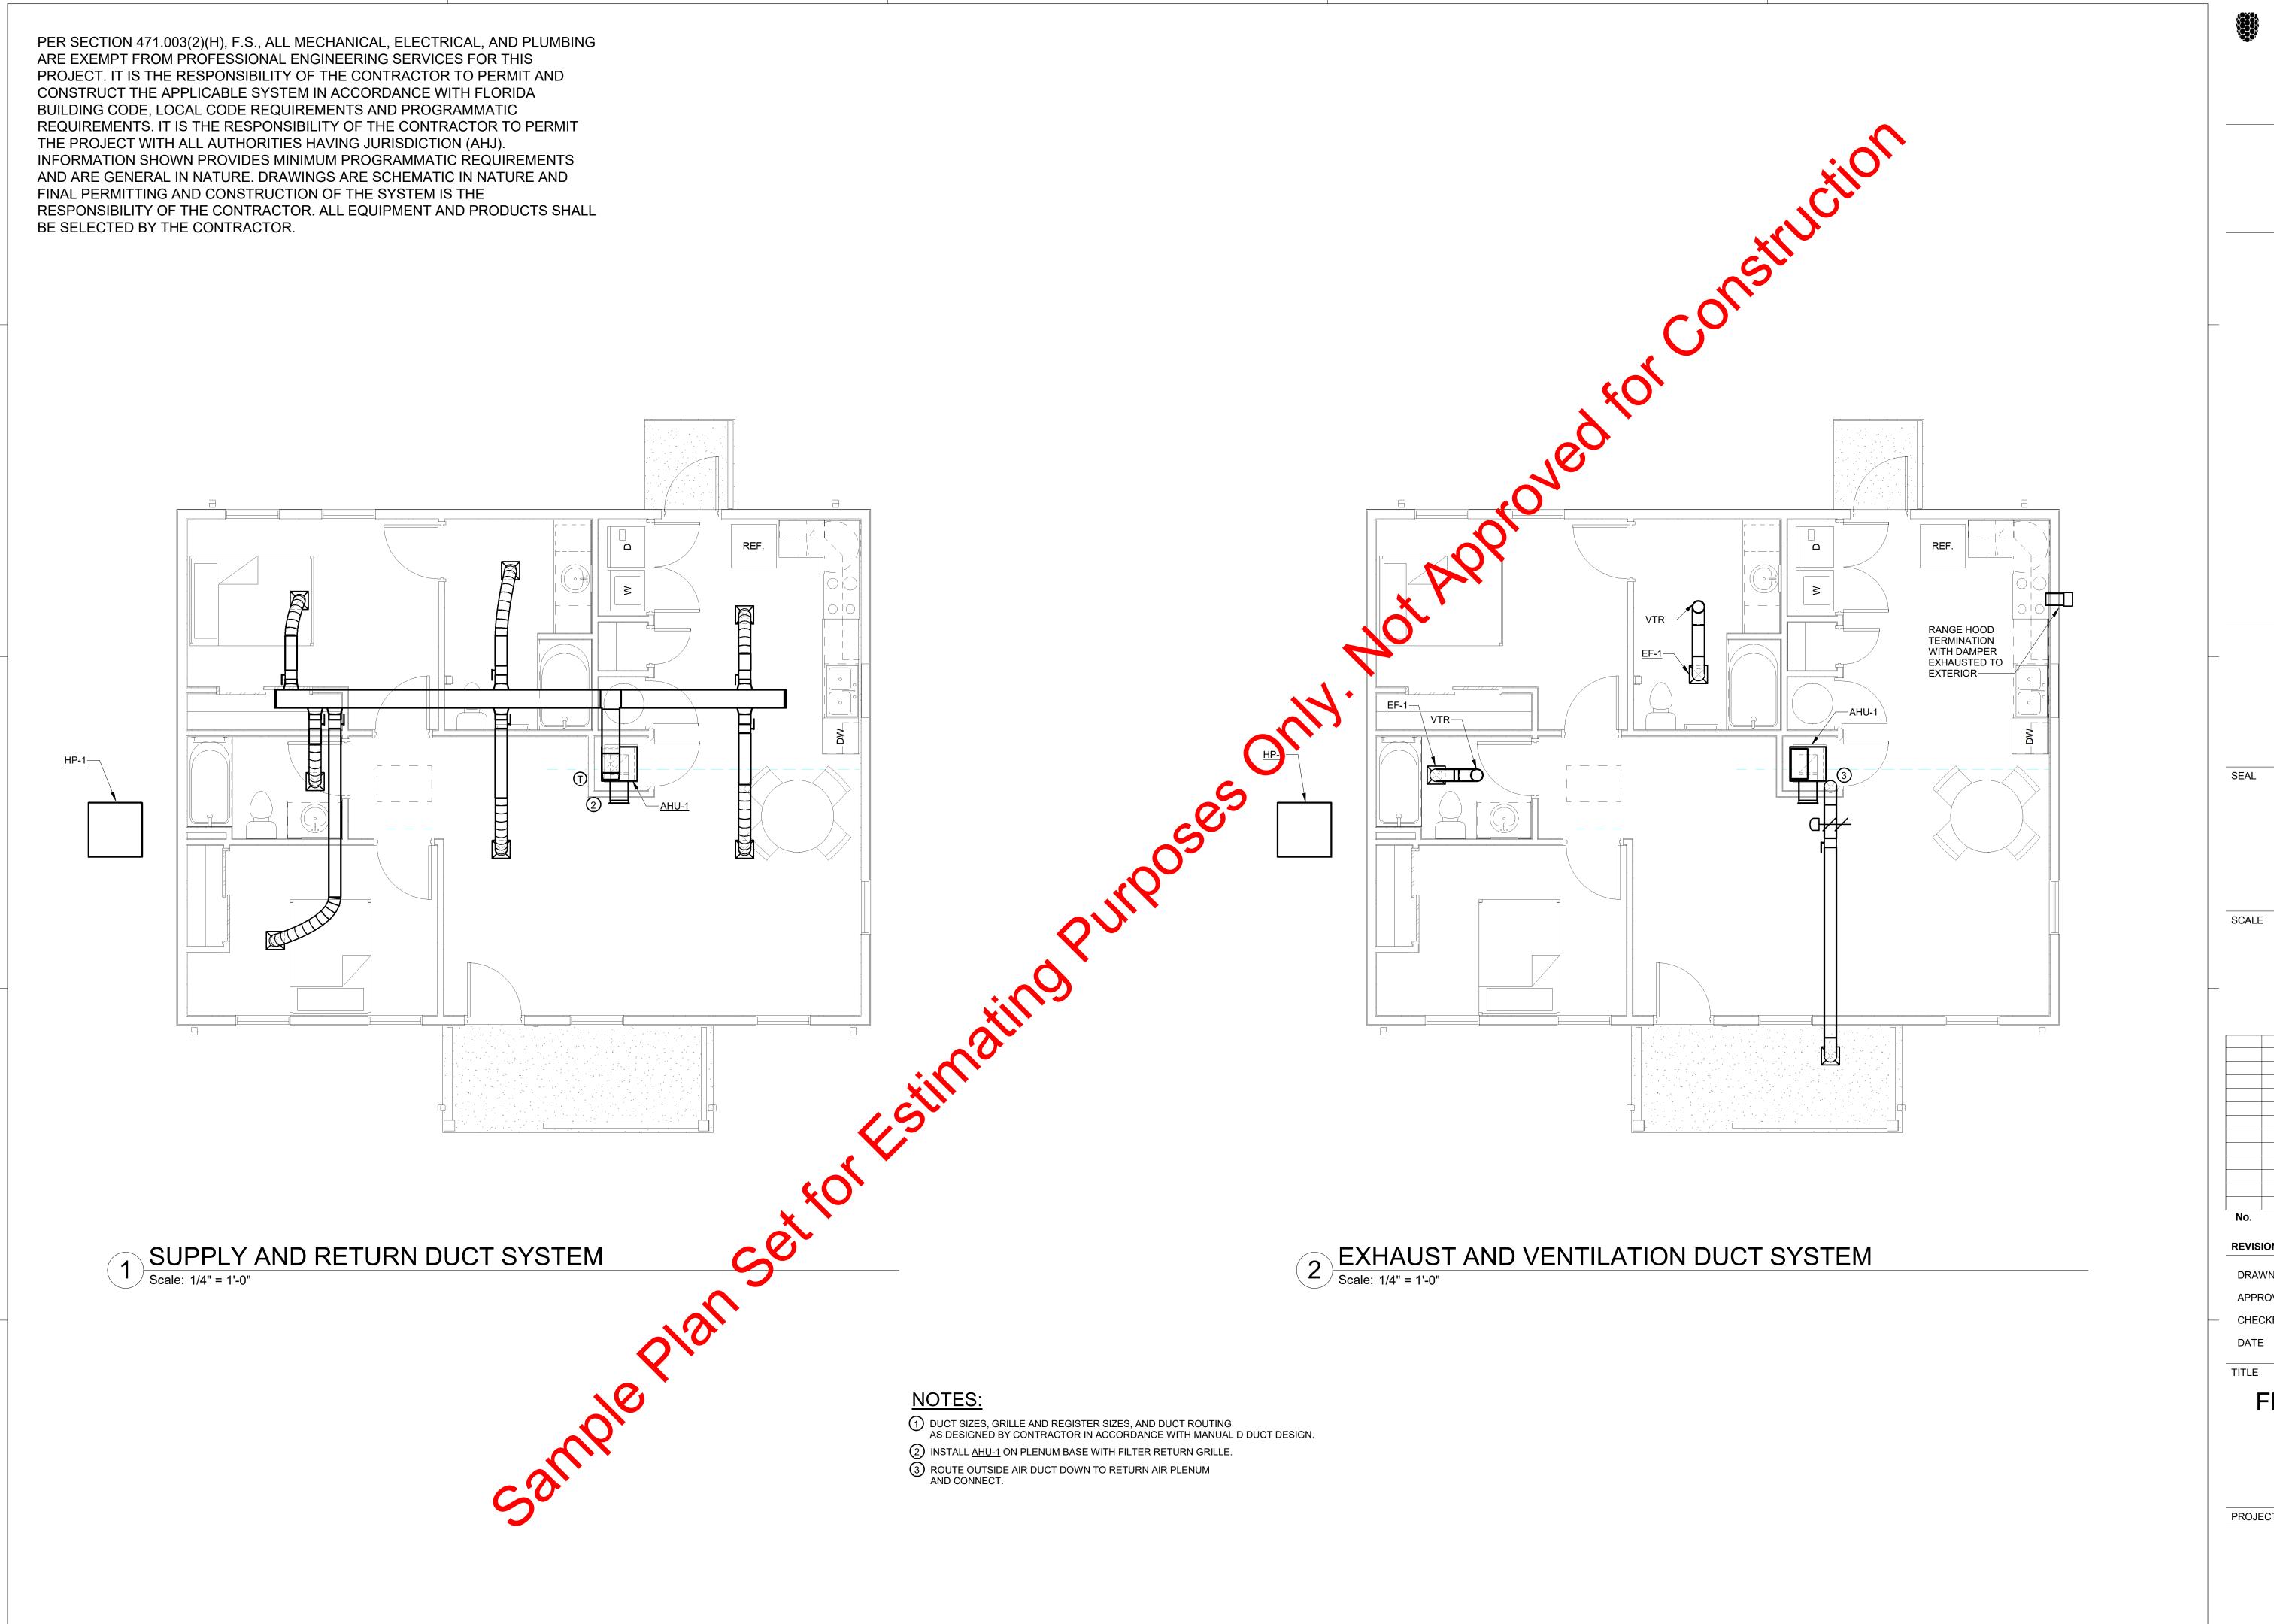

Dewberry Engineers Inc. 877 North County Hwy 393 Santa Rosa Beach, FL 32459 850.267.0759 Phone 850.557.0076 Fax www.dewberry.com

Rebuild Florida

1/4" = 1'-0"

No. Description Date

REVISIONS

DRAWN BY ETO
APPROVED BY CLS

CHECKED BY

DATE

FLOOR PLANS 2BR WIDE

PROJECT NO. 50171913

M1.0

NOTES (SHEET NO. E1.0)

- 1. COMBINATION LIGHT / EXHAUST FAN FIXTURE TO BE ENERGY STAR COMPLIANT. COORDINATE WITH MECHANICAL CONTRACTOR.
- 2. INSTALL (1) 220 DISCONNECT. MAINTAIN A 3 FT CLEARANCE IN FRONT OF DISCONNECT

ELECTRICAL GENERAL NOTES

- 1. ELECTRICAL CONTRACTOR SHALL SIZE SERVICE, CONDUCTORS, FUSES, BREAKERS, AND SWITCHES IN ACCORDANCE WITH LOCAL BUILDING CODI.: AN ELECTRICAL LOAD CALCULATION WILL BE REQUIRED FOR SERVICE SIZING.
- 2. PROVIDE SERVICE ENTRANCE GROWNDING IN ACCORDANCE WITH LOCAL BUILDING CODE.
- 3. ELECTRICAL CONTRACTOR SHALL COORDINATE WITH POWER COMPANY TO FULFILL REQUIREMENTS IN ESTABLISHING SERVICE. CONTRACTOR RESPONSIBLE FOR ALL ASSOCIATED FEES.
- ALL WIRING SHALL BE COPPER WITH ONE EXCEPTION ONLY. THE SERVICE ENTERANCE CONDUCTORS MAY USE COPPER OR ALDMINUM (SE OR USE). OTHERWISE, NO ALUMINUM WIRING SHALL BE USED
- SMOKE DETECTORS SHOWN SHALL BE COMBINATION SMOKE/CARBON MONOXIDE ALARMS. AND BE APPROVED AND LISTED IN ACCORDANCE WITH UL 217 AND 2034. THEY SHALL BE HARD WIRED WITH BATTERY BACK-UP. ALL DETECTORS WITHIN A UNIT SHALL BE INTERCONNECTED SUCH THAT ALL ALARM UPON ACTIVATION OF A SINGLE DETECTOR.
- 6. AL LIGHT FIXTURES AND CEILING FANS SHALL BE ENERGY STAR QUALIFIED.
- PROVIDE ARC FAULT CIRCUIT INTERRUPTER (AFCI) PROTECTION WHERE REQUIRED BY CODE. PREFERRED COMPLIANCE PATH IS PROTECTION AT THE BRANCH CIRCUIT BREAKER LEVEL.
- COORDINATION WITH OTHER TRADES: EXECUTE THE WORK IN FULL COOPERATION WITH OTHER CONSTRUCTION TRADES. PRIOR TO STARTING WORK, EXAMINE A COMPLETE SET OF CONSTRUCTION DOCUMENTS FOR ALL TRADES TO VERIFY COORDINATION, CHECK FOR INTERFERENCES, AND DETERMINE POINTS OF CONNECTIONS FOR EQUIPMENT. DUE TO STRUCTURAL CONDITIONS, MECHANICAL DUCT OR PIPING INTERFERENCE, OR OTHER REASONS, THE CONTRACTOR MAY DESIRE TO INSTALL THE WORK IN AN ALTERNATE MANNER FROM THAT SHOWN. SUCH CHANGES SHALL BE PRESENTED TO THE OWNER'S REPRESENTATIVE FOR APPROVAL BEFORE PROCEEDING.
- PROVIDE DATA (CAT-6) AND TELEVISION (RG-6 SHIELDED) RECEPTACLES IN ALL BEDROOMS AND (1) IN LIVING ROOM. PROVIDE ALL TERMINATIONS AND COVER PLATES TO MATCH POWER RECEPTACLE COVER PLATES.
- 10. LOCATIONS WHERE CONDUITS PENETRATE FIRE-RATED WALLS, FLOORS, OR CEILINGS SHALL BE FIREPROOFED USING A UL-LISTED METHOD TO MAINTAIN THE EXISTING RATING.
- 1. COORDINATE THE MOUNTING HEIGHT AND LOCATIONS OF THE ELECTRICAL DEVICES WITH ARCHITECTURAL ELEVATIONS AND GENERAL TRADES CONTRACTOR PRIOR TO ROUGH-IN. RECEPTACLES LOCATED WITHIN SIX (6) FEET OF SINK SHALL BE GROUND FAULT CIRCUIT INTERRUPTER (GFCI) TYPE RECEPTACLES. RECEPTACLES NOT READILY ACCESSIBLE THAT REQUIRE GFCI PROTECTION SHALL BE SO AT THE CIRCUIT BREAKER.
- 12. COORDINATE LOCATION OF CONDUITS, OUTLETS AND JUNCTION BOXES WITH MECHANICAL EQUIPMENT SO THAT OUTLETS AND JUNCTION BOXES ARE ACCESSIBLE FOR SERVICING AND HVAC DUCTWORK CAN BE CONNECTED DIRECTLY TO DIFFUSERS.
- PERFORM ALL WORK IN ACCORDANCE WITH 2020 NATIONAL ELECTRICAL CODE (NEC) (OR WHICHEVER IS LATEST FLORIDA-ADOPTED EDITION OF THE NEC) AND ALL APPLICABLE LOCAL CODES.
- 14. FOR RECORD DRAWING REQUIREMENTS, REFER TO THE GENERAL CONDITIONS. MAINTAIN A DEDICATED SET OF DRAWINGS ON THE JOBSITE AND MARK ALL VARIATIONS TAKEN TO THE CONTRACT DRAWINGS. SEE PLANS FOR SUGGESTED LOCATIONS.
- 5. ALL ELECTRICAL EQUIPMENT SHALL BE INSTALLED SUCH THAT PROPER WORKING CLEARANCES ARE MAINTAINED.
- 16. COORDINATE WITH MECHANICAL TO PROVIDE APPROPRIATE CIRCUITS FOR HVAC AND PLUMBING EQUIPMENT. PROVIDE LOCAL DISCONNECT FOR EACH PIECE OF EQUIPMENT AND ENSURE WORKING CLEARANCE TO DISCONNECT IS MAINTAINED.
- 17. ALL WORK SHALL MEET APPLICABLE REQUIREMENTS OF THE FLORIDA RESIDENTIAL CODE 2023 EDITION (OR MOST RECENT) AND CHAPTER 4 [RE] RESIDENTIAL ENERGY EFFICIENCY OF FBC, ENERGY CONSERVATION 2023 (OR MOST RECENT)
- 18. ALL CONSTRUCTION WORK SHALL BE IN COMPLIANCE WITH ALL LOCAL CITY, COUNTY, STATE OF FLORIDA AND FEDERAL CODES. THE CONTRACTOR SHALL GIVE ALL NOTICES AND COMPLY WITH ALL LAWS, ORDINANCES, RULES, REGULATIONS, AND LAWFUL ORDERS OF ANY PUBLIC AUTHORITY BEARING PERFORMANCE OF THE
- 19. COMBINATION SMOKE /CARBON MONOXIDE DETECTORS SHALL BE PROVIDED IN AND OUTSIDE ALL SLEEPING AREAS. SEE PLANS FOR SUGGESTED LOCATIONS.
- 20. CONTRACTOR TO COORDINATE ALL UTILITIES INSTALLATION AND CONNECTION WITH LOCAL UTILITY COMPANY. AVOID ROUTING CONDUIT THROUGH BUILDING FOOTINGS. WHERE CONFLICTS ARE UNAVOIDABLE, ROUTE CONDUIT AT A MINIMUM OF 12" BELOW FOOTING.
- 21. ALL PENETRATIONS THROUGH FIRE RATED WALLS ARE TO BE SEALED WITH CODE APPROVED FIRESTOPPING
- 2. CONTRACTOR SHALL PROVIDE ALL ELECTRICAL FIXTURES, HARDWARE, AND ACCESSORIES IN A CONSISTENT MATERIAL FINISH.
- CONTRACTOR SHALL PROVIDE ELECTRICAL LOAD CALCULATIONS AND ANY ADDITIONAL ELECTRICAL INFORMATION REQUESTED BY PERMIT DEPARTMENT NOT SHOWN IN DRAWINGS.
- INFORMATION REQUESTED BY PERMIT DEPARTMENT NOT SHOWN IN DRAWINGS.

 4. CONTRACTOR SHALL WIRE SERVICE CONDUCTORS THROUGH A JUNCTION BOX. THE INTENT IS THAT IF A
- FUTURE HOMEOWNER DESIRES TO INSTALL A BACKUP GENERATOR, THEY COULD REPLACE THE BOX WITH A SERVICE ENTRANCE AUTOMATIC TRANSFER SWITCH. PROVIDE CONTINUOUS SERVICE ENTRANCE CONDUCTORS THROUGH THE BOX WITH EXTRA LENGTH TO FACILITATE FUTURE CONNECTION. COORDINATE LOCATION BOX AND METER BASE WITH THE POWER COMPANY.

PER SECTION 471.003(2)(H), F.S., ALL MECHANICAL, ELECTRICAL, AND PLUMBING ARE EXEMPT FROM PROFESSIONAL ENGINEERING SERVICES FOR THIS PROJECT. IT IS THE RESPONSIBILITY OF THE CONTRACTOR TO PERMIT AND CONSTRUCT THE APPLICABLE SYSTEM IN ACCORDANCE WITH FLORIDA BUILDING CODE, LOCAL CODE REQUIREMENTS AND PROGRAMMATIC REQUIREMENTS. IT IS THE RESPONSIBILITY OF THE CONTRACTOR TO PERMIT THE PROJECT WITH ALL AUTHORITIES HAVING JURISDICTION (AHJ). INFORMATION SHOWN PROVIDES MINIMUM PROGRAMMATIC REQUIREMENTS AND ARE GENERAL IN NATURE. DRAWINGS ARE SCHEMATIC IN NATURE AND FINAL PERMITTING AND CONSTRUCTION OF THE SYSTEM IS THE RESPONSIBILITY OF THE CONTRACTOR. ALL EQUIPMENT AND PRODUCTS SHALL BE SELECTED BY THE CONTRACTOR.




Dewberry Engineers Inc. 877 North County Hwy 393 Santa Rosa Beach, FL 32459 850.267.0759 Phone 850.557.0076 Fax www.dewberry.com



SEAL

SCALE

As indicated

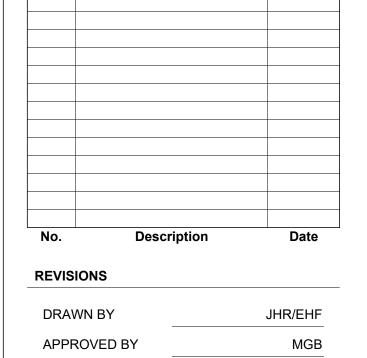

ELECTRICAL PLAN 2 BR WIDE

PROJECT NO. 50171913

E1.0

SHEET NO.

CHECKED BY

DATE

REBUILD FLORIDA - HURRICANE HOUSING REPAIR AND REPLACEMENT

ADDRESS, CITY COUNTY, FLORIDA

FL-HI22-XXXXXXX

3 BEDROOM / 2 BATH WIDE SLAB

PROJECT MANAGER

Dewberry Engineers Inc.
877 North County Hwy 393
Santa Rosa Beach, FL 32459
850.267.0759

ARCHITECTURAL

Dewberry Architects Inc.


STRUCTURAL

Hunter Baumgardner, PE Southeastern Consulting Engineers, Inc.







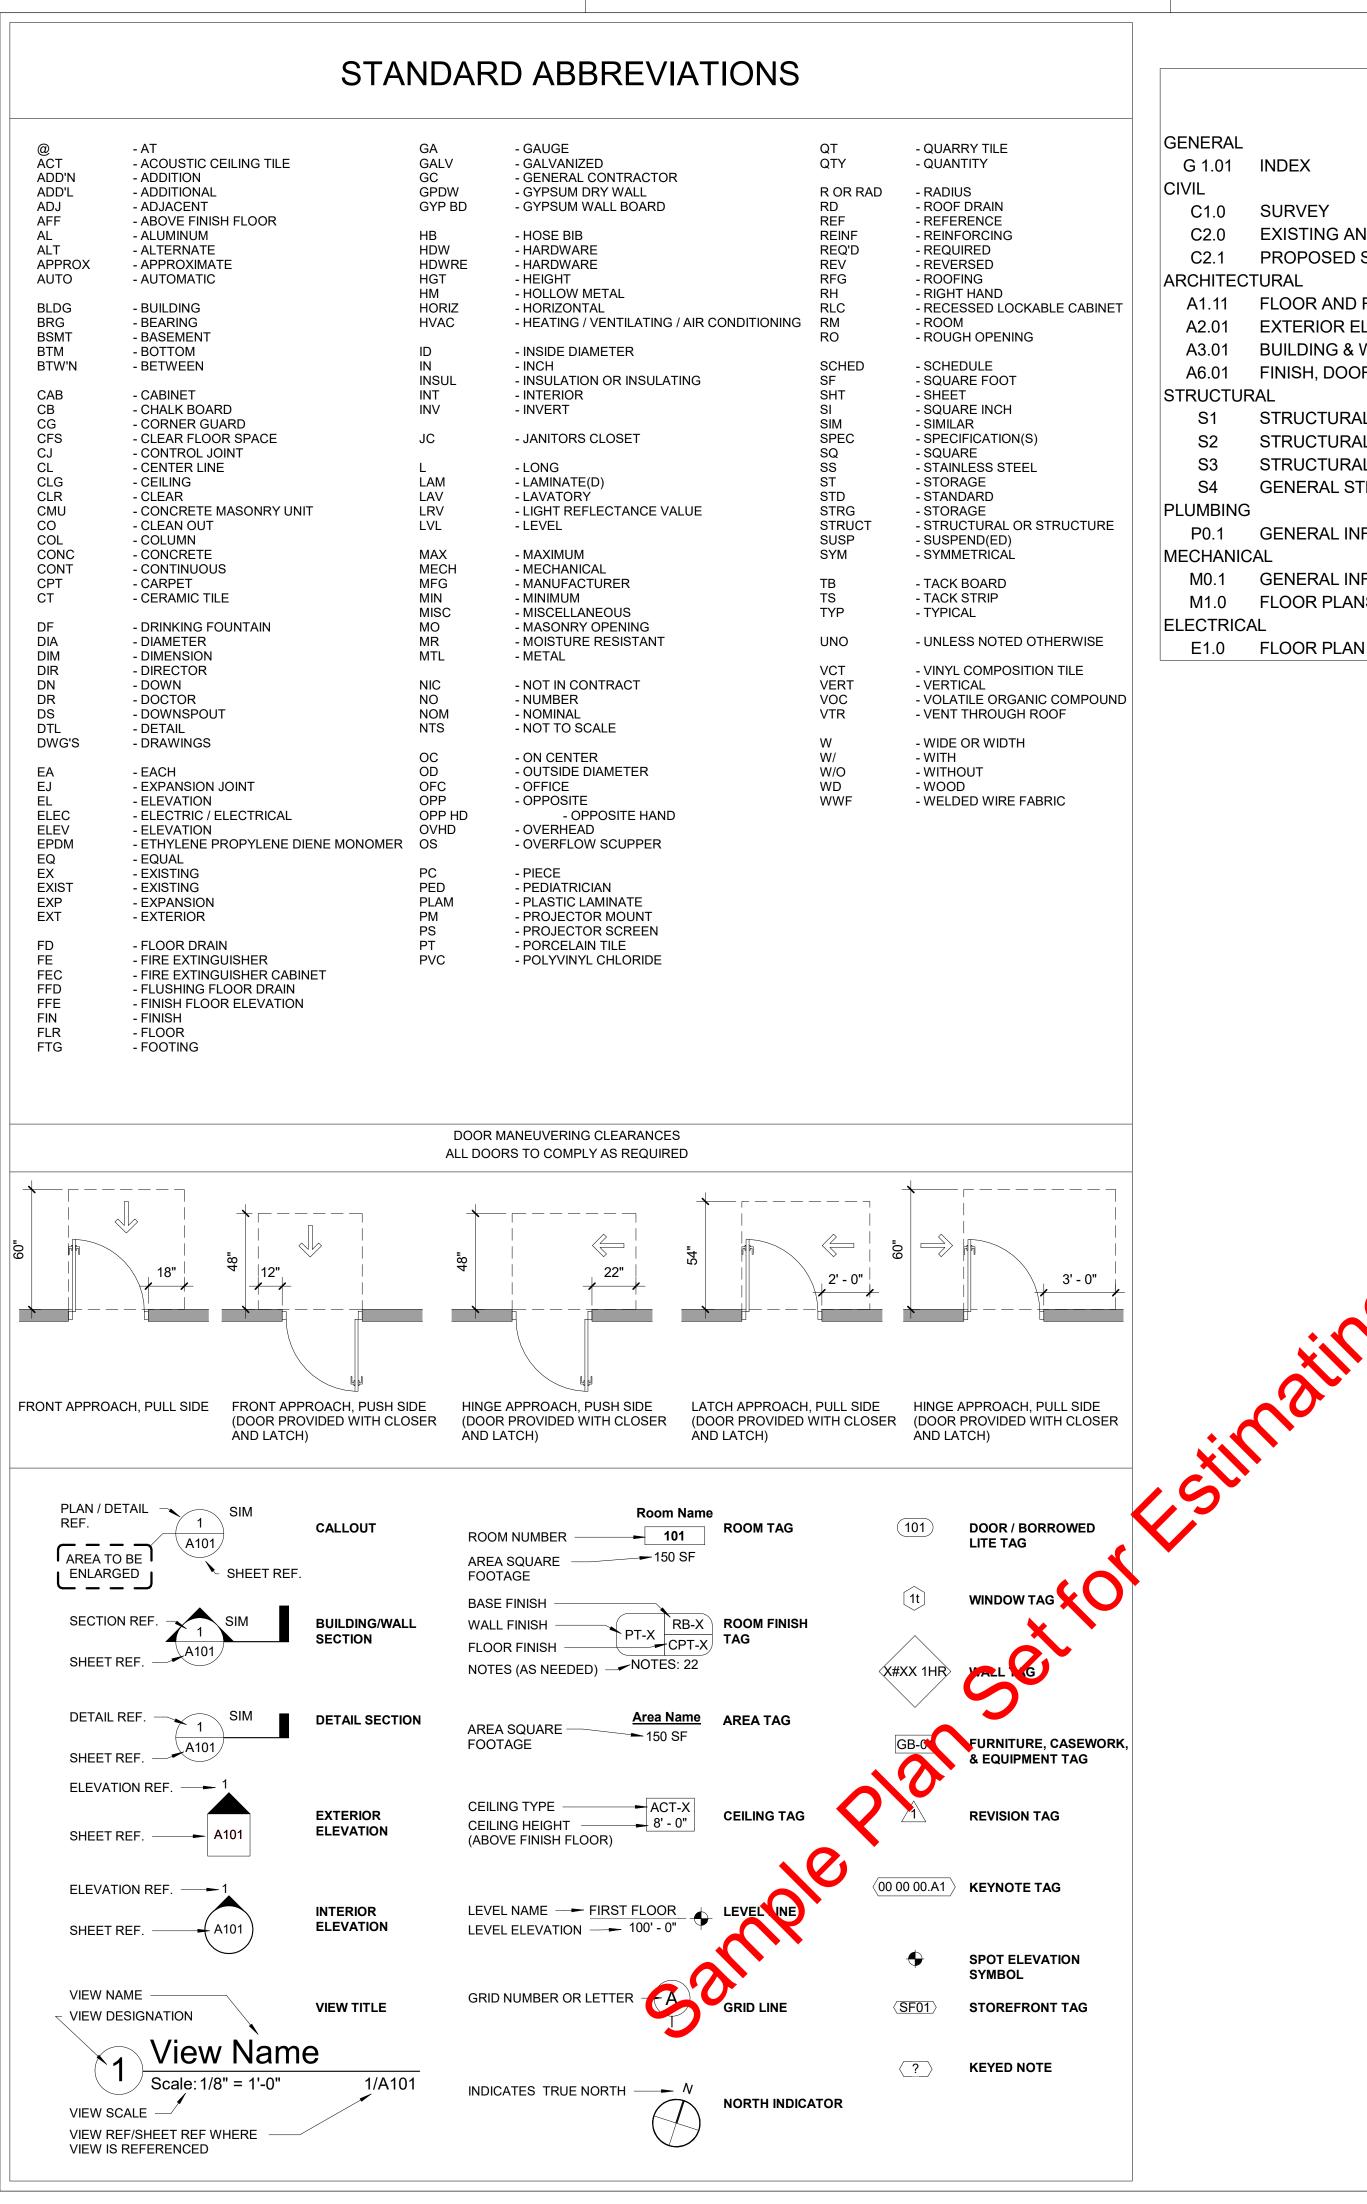

SHEET INDEX GENERAL G 1.01 INDEX SURVEY EXISTING AND PROPOSED SITE OVERLAY PROPOSED SITE AND DRAINAGE PLAN **ARCHITECTURAL** FLOOR AND ROOF PLANS A1.11 **EXTERIOR ELEVATIONS BUILDING & WALL SECTIONS AND INTERIOR ELEVATIONS** FINISH, DOOR, & WINDOW SCHEDULES **STRUCTURAL** STRUCTURAL PLAN VIEWS STRUCTURAL DETAILS STRUCTURAL DETAILS GENERAL STRUCTURAL NOTES **PLUMBING** GENERAL INFORMATION MECHANICAL GENERAL INFORMATION FLOOR PLANS **ELECTRICAL**

GENERAL CONSTRUCTION NOTES

INSTALLATION OF THE WORK.

AND BENCHMARK CERTIFICATE.

DISCONNECT UTILITIES AS REQUIRED.

A. BUILDING DATA

SEISMIC DESIGN CATEGORY : TBD (FIGURE R301.2.2(2))

B. ENERGY SUMMARY

: 1,281 SF : 117 SF

: 1,398 SF

: NEW CONSTRUCTION

: SINGLE FAMILY RESIDENTIAL

: 18'-4" (+ HEIGHT OF PIERS IF APPLICABLE)

REQUIRED

R-38

R-13

R-13

R-0

0.4

0.25

TYPE OF WORK

FIRE ALARM

SPRINKLERS

STANDPIPES

FIRE DISTRICT

RISK CATEGORY

BUILDING HEIGHT

CLIMATE ZONE

TABLE R402.1.2

CEILING

FLOOR SLAB

SHGC

IECC REQUIREMENTS:

THERMAL ENVELOPE

MAXIUMUM U-FACTOR

NEW BUILDING AREA

GROSS

CONSTRUCTION TYPE

FLOOD HAZARD AREA

FIRE/SMOKE RATED WALLS

CONDITIONED

UNCONDITIONED

WALLS ABOVE GRADE (WOOD FRAMED)

FENESTRATION REQUIREMENTS

OR REGULATIONS TAKE PRECEDENCE.

PLANS ARE NOT TO BE SCALED AND ARE INTENDED TO BE A

AFFECT ALL INSTALLATIONS INDICATED ON THE DRAWINGS.

INCLUDING DETAILS AND LABOR NECESSARY FOR SUCCESSFUL

FURNISH ALL MATERIALS, EQUIPMENT, AND LABOR NECESSARY TO

INSTALL ALL EQUIPMENT AND MATERIALS IN STRICT ACCORDANCE

DETAILS ARE INTENDED TO SHOW END RESULT OF DESIGN. MINOR

MODIFICATIONS MAY BE REQUIRED TO SUIT JOB DIMENSIONS OR

EVERY EFFORT HAS BEEN MADE TO PROVIDE THE COMPLETE SCOPE OF WORK. MINOR OMISSIONS AND SUCREPANCIES IN THE

COMPLETED FACILITY AND IMPROVEMENTS IN ACCORDANCE WITH

GENERAL CONTRACTOR SMALL PROVIDE AT THE JOB SITE A FULL

DISCREPANCIES, PRICE THE NORE EXPENSIVE OR EXTENSIVE

SET OF CONSTRUCTION OCUMENTS ANNOTATED WITH THE

LATEST REVISION AND CLARIFICATIONS FOR THE USE BY ALL.

RESPONSBILITY TO CALL FOR LOCAL INSPECTIONS AND OBTAIN

FROM THE STATE FIRE MARSHAL IF REQUIRED.

NTRACTOR SHALL VERIFY THE MINIMUM FINISH FLOOR

LEVATION WITH THE CITY/PARISH FEMA BASE FLOOD ELEVATION

THE CONTRACTOR SHALL HAVE THE WORK SITE CLEANED ON A

DAILY BASIS. THE DISPOSAL OF ANY WASTE SHALL BE OFF SITE

COORDINATE WITH UTILITY PROVIDERS TO LOCATE, CAP, AND/OR

AND IN A MANNER PRESCRIBED UNDER THE LAW.

WORK SHOWN OR REFERRED TO ON ANY DRAWNIGGUALL BE PROVIDED AS THOUGH SHOWN ON ALL RELATED DRAWINGS.

DRAWINGS SHALL NOT DIMINISH THE EXPECTATION OF A

THE INTENT OF THESE DOCUMENTS. IN THE EVENT OF

SPECIFICALLY INDICATED OTHERWISE OR WHERE LOCAL CODES

DIAGRAMMATIC OUTLINE, UNLESS OTHERWISE NOTED.

WITH MANUFACTURERS' RECOMMENDATIONS UNLESS

IT IS THE RESPONSIBILITY OF THE CONTRACTOR TO VERIFY AND THE CONTRACTOR SHALL VISIT THE JOB SITE TO REVIEW THE COMPLY WITH ALL BUILDING CODE, MUNICIPAL CODE AND HOME SCOPE OF WORK AND CONFIRM THAT THE WORK MAY BE OWNER ASSOCIATION (HOA) REQUIREMENTS. ACCOMPLISHED AS SHOWN.

> RAZE EXISTING STRUCTURE AS REQUIRED, PROPERLY DISPOSING OF DEBRIS WITH A LEGAL DUMPSTER ON SITE.

MOVE SIDEWALKS, DRIVEWAYS, AND OTHER FLATWORK ON SITE

REQUIRED.

S REQUIRED. REMOVE EXISTING SHRUBS, TREE ROOTS, ETC WHERE NEW FLATWORK, DRAINLINES, AND HOUSE SLABS WILL BE LOCATED AS

COORDINATE TREE REMOVAL WITH MUNICPALITY. PROTECT TREES

FILL HOLES CAUSED BY REMOVAL OF EXISTING OBSTRUCTIONS WITH SOIL SIMILAR TO EXISTING ADJACENT SOILS.

SLOPE ALL CONCRETE PAVING AWAY FROM BUILDING AT MINIMUM

SLOPE ALL FINAL GRADING AWAY FROM BUILDING TO ENSURE

SLOPE ALL CONCRETE WALKS AWAY FROM BUILDING AT MINIMUM

POSITIVE DRAINAGE TO AREA DRAINS OR CULVERTS, NOT TO ADJACENT PROPERTIES.

ALL DRIVEWAY AND SIDEWALKS SHALL MEET LOCAL DEPARTMENT OF PUBLIC WORKS STANDARD DETAILS IF APPLICABLE.

23. THE CONTRACTOR SHALL COORDINATE ALL UTILITIES INSTALLATION AND CONNECTION WITH LOCAL UTILITY COMPANY.

CONTRACTOR SHALL PROVIDE CLEAN OUT LOCATIONS, TIE-IN

LOCATIONS, AND WATER AND SEWER LINE LOCATIONS ON SITE TO

GENERAL CONTINATION SHALL COORDINATE, APPLY, AND PAY FOR 24. ALL PERMI S IN SPECTIONS, AND/OR CERTIFICATES FROM THE APPROPRIA E GENCIES. IT IS THE CONTRACTOR'S PERMIT DEPARTMENT FOR REVIEW. LAY NEW SOD AROUND PERIMETER OF FOUNDATION A MINIMUM OF

8 FEET. STABILIZE OTHER DISTURBED SOILS BY OTHER APPROPRIATE METHODS. CONTRACTOR SHALL PROVIDE ALL PLUMBING FIXTURES,

ELECTRICAL FIXTURE, DOOR HARDWARE, BATHROOM HARDWARE, AND BATHROOM ACCESSORIES IN A CONSISTENT MATERIAL FINISH. APPLIANCES SHALL BE ENERGY STAR CERTIFIED - CLOTHES

WASHER, CLOTHES DRYER, RANGE HOOD, DISHWASHER, REFRIGERATOR. SUPPLY HOSES TO WATER USING FIXTURES AND APPLIANCES MUST BE ARMORED PEX OR METAL (NOT COPPER).

ALL EXTERIOR PAINT TO MEET LIGHT REFLECTANCE VALUE (LRV) OF

PER FBC APPENDIX F, PASSIVE RADON-RESISTANT CONSTRUCTION: PROVIDE 6 MIL VAPOR BARRIER UNDER SLAB ON GRADE. 2" PRESSURE-SENSITIVE VINYL TAPE ALL JOINTS.

SEAL AND CAULK ALL SLAB PENETRATIONS WITH MASTIC OR SLABS AND FOUNDATIONS SHALL BE CONSTRUCTED USING

A SLAB EDGE DETAIL THAT ELIMINATES CRACKS THAT COULD CONNECT THE HOUSE INTERIOR TO SUBSLAB SOIL. MONOLITHIC SLAB CONSTRUCTION USED WHERE POSSIBLE. ALL CONTRACTION JOINTS SHALL BE CLEANED AND SEALED

AGAINST SOIL-GAS ENTRY BY USE OF AN APPROVED SEALANT. WORK SPACES FORMED INTO A SLAB SHALL BE SEALED GAS-TIGHT. EXPOSED SOIL SHALL BE COMPACTED AND FULLY COVERED WITH A SOLVENT-BASED PLASTIC ROOF CEMENT

OR OTHER APPROVED ELASTOMERIC MATERIAL TO A MIN. WHERE PENETRATING PIPES ARE SLEEVED, THEY SHALL BE SEALED BY JOINT SEALANT OR APPROVED ALTERNATIVE

VAPOR BARRIER NOT REQUIRED FOR PIER CONSTRUCTION WHEN BOTTOM OF FLOOR JOISTS ARE GREATER THAN 18" FROM GRADE

C. BUILDING CODE SUPPORTING DATA

APPLICABLE CODE

EXCEPTION: KITCHENS

R304.2

/ PROVIDED

/ R-19

/ R-19

/ R-0

/ R-38 BLOWN

OR / (2) R-19 BLANKET

:2023 FLORIDA BUILDING CODE, RESIDENTIAL 2023 FLORIDA BUILDING CODE, ENERGY CONSERVATION 2018 WOOD FRAME CONSTRUCTION MANUAL **AMERICANS WITH DISABILITIES ACT GUIDELINES**

ENCLOSED SPACE UNDER STAIRS THAT IS ACCESSED BY A DOOR OR ACCESS PANEL SHALL HAVE WALLS, UNDER-STAIR SURFACE AND ANY SOFFITS PROTECTED ON THE ENCLOSED SIDE WITH 1/2-INCH GYPSUM BOARD IN COMBUSTIBLE CONSTRUCTION, FIREBLOCKING SHALL BE PROVIDED TO CUT OFF

BOTH VERTICAL AND HORIZONTAL CONCEALED DRAFT OPENINGS AND TO FORM AN EFFECTIVE FIRE BARRIER BETWEEN STORIES, AND BETWEEN A TOP STORY AND THE HABITABLE ROOMS SHALL HAVE AN AGGREGATE GLAZING AREA OF NOT LESS THAN 8

PERCENT OF THE FLOOR AREA OF SUCH ROOMS HABITABLE ROOMS SHALL HAVE A ROOM AREA OF NOT LESS THAN 70 SQUARE FEET

EXCEPTION: KITCHENS HABITABLE ROOMS SHALL BE NOT LESS THAN 7 FEET IN ANY HORIZONTAL DIMENSION

BASEMENTS, HABITABLE ATTICS, AND EVERY SLEEPING ROOM SHALL HAVE NOT LESS THAN ONE OPERABLE EMERGENCY ESCAPE AND RESCUE OPENING

EMERGENCY ESCAPE AND RESCUE OPENINGS SHALL HAVE A NET CLEAR OPENING OF NOT LESS THAN 5.7 SQUARE FEET

NOT LESS THAN ONE EGRESS DOOR SHALL BE PROVIDED FOR EACH DWELLING UNIT, AND SHALL PROVIDE A CLEAR WIDTH OF NOT LESS THAN 32 INCHES.

THERE SHALL BE A LANDING OR FLOOR ON EACH SIDE OF EACH EXTERIOR DOOR. THE WIDTH OF THE LANDING SHALL BE NOT LESS THAN THE DOOR SERVED. LANDINGS SHALL HAVE A DIMENSION OF NOT LESS THAN 36 INCHES MEASURED IN THE DIRECTION OF TRAVEL

THE WIDTH OF A HALLWAY SHALL BE NOT LESS THAN 3 FEET

A FLIGHT OF STAIRS SHALL NOT HAVE A VERTICAL RISE LARGER THAN 12 FEET 7 INCHES BETWEEN FLOOR LEVELS OR LANDINGS

THE MAXIMUM RISER HEIGHT SHALL BE 7 3/4 INCHES

THE TREAD DEPTH SHALL BE NOT LESS THAN 10 INCHES

FEET OF EACH CORNER OF THE BUILDING

SMOKE ALARMS SHALL BE INSTALLED IN EACH SLEEPING ROOM, OUTSIDE EACH SEPARATE SLEEPING AREA IN THE IMMEDIATE VICINITY OF THE BEDROOMS, NOT LESS THAN 3 FEET HORIZONTALLY FROM THE DOOR OR OPENING OF A BATHROOM THAT

BUILDINGS SHALL BE PROVIDED WITH APPROVED ADDRESS IDENTIFICATION. THE ADDRESS IDENTIFICATION SHALL BE LEGIBLE AND PLACED IN A POSITION THAT IS VISIBLE FROM THE STREET OR ROAD FRONTING THE PROPERTY. EACH CHARACTER SHALL BE NOT LESS THAN 4 INCHES IN HEIGHT

CONTAINS A BATHTUB OR SHOWER, AND ON EACH ADDITIONAL STORY.

THE UNDER-FLOOR SPACE BETWEEN THE BOTTOM OF THE FLOOR JOISTS AND THE EARTH UNDER ANY BUILDING SHALL HAVE VENTILATION OPENINGS THROUGH FOUNDATION WALLS OR EXTERIOR WALLS. THE MINIMUM NET AREA OF VENTILATION OPENINGS SHALL BE NOT LESS THAN 1 SQUARE FOOT FOR EACH 150 SQUARE FEET OF UNDER-FLOOR SPACE AREA. ONE SUCH VENTILATING OPENING SHALL BE WITHIN 3

Dewberry

877 North County Hwy 393

850.267.0759 Phone

850.557.0076 Fax

www.dewberry.com

Santa Rosa Beach, FL 32459

SCALE

As indicated

Description REVISIONS **DRAWN BY** SEH APPROVED BY LWH **CHECKED BY** ANS


50171913


PROJECT NO.

SHEET NO.


DATE

TITLE

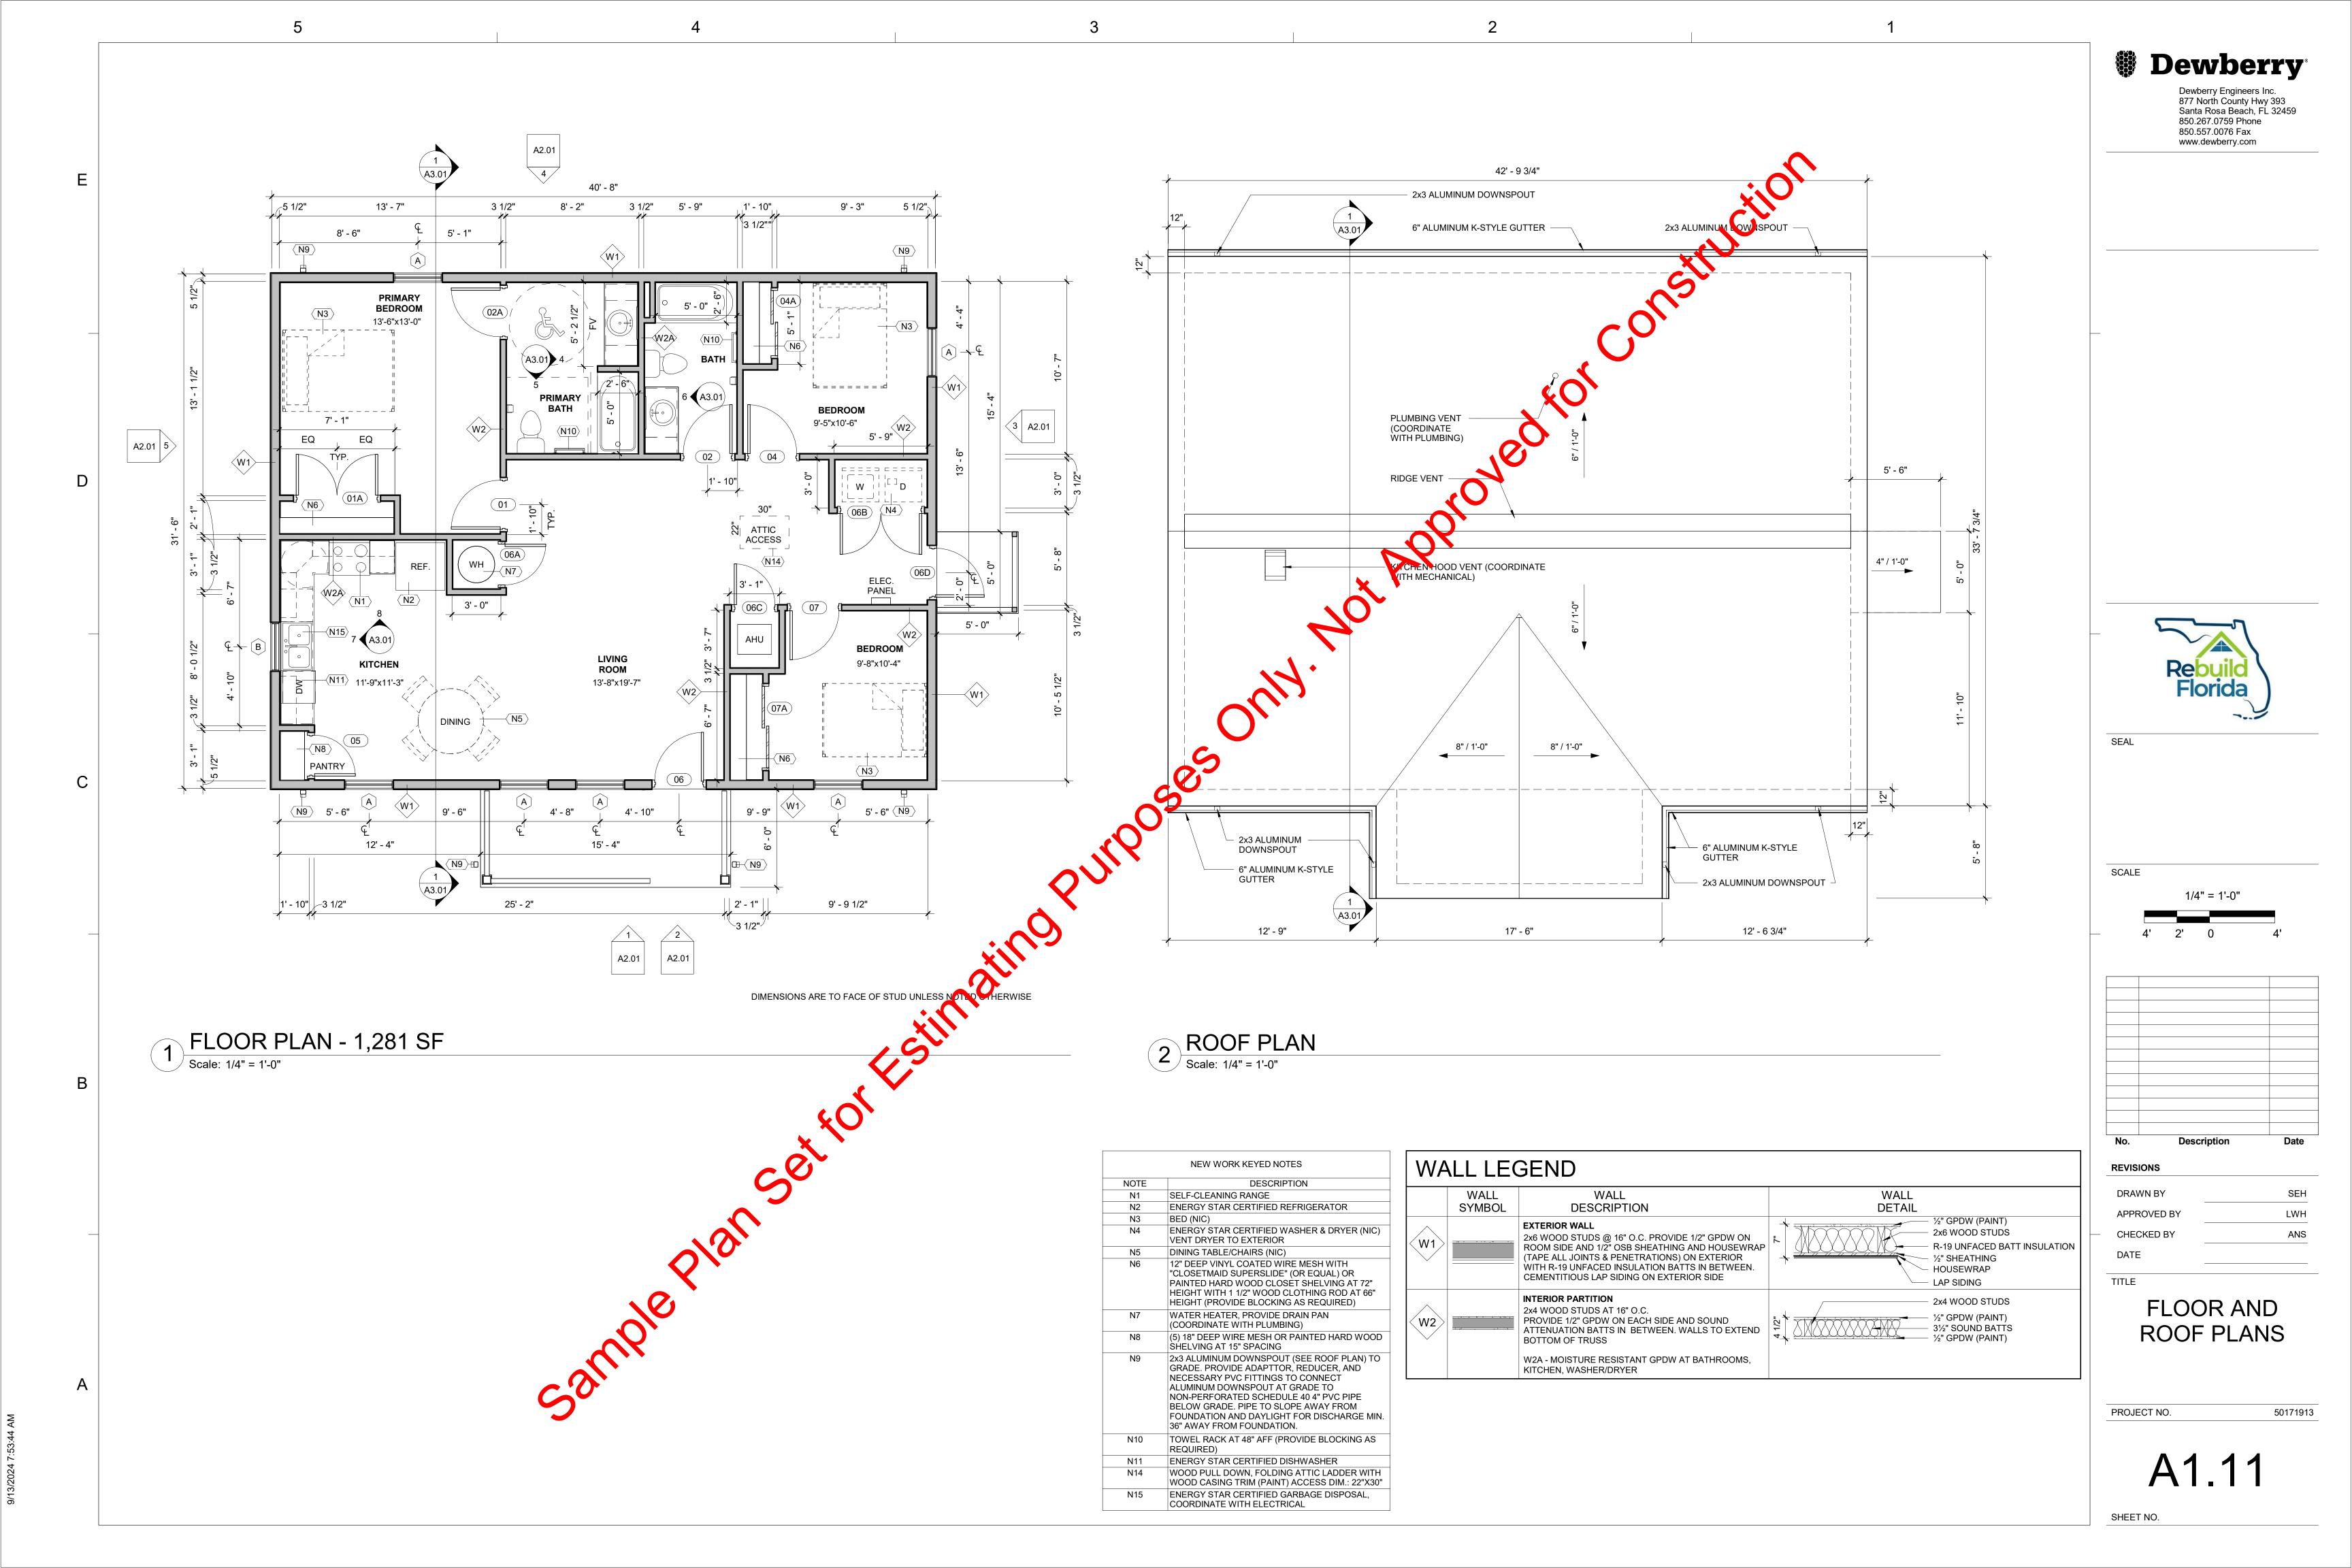

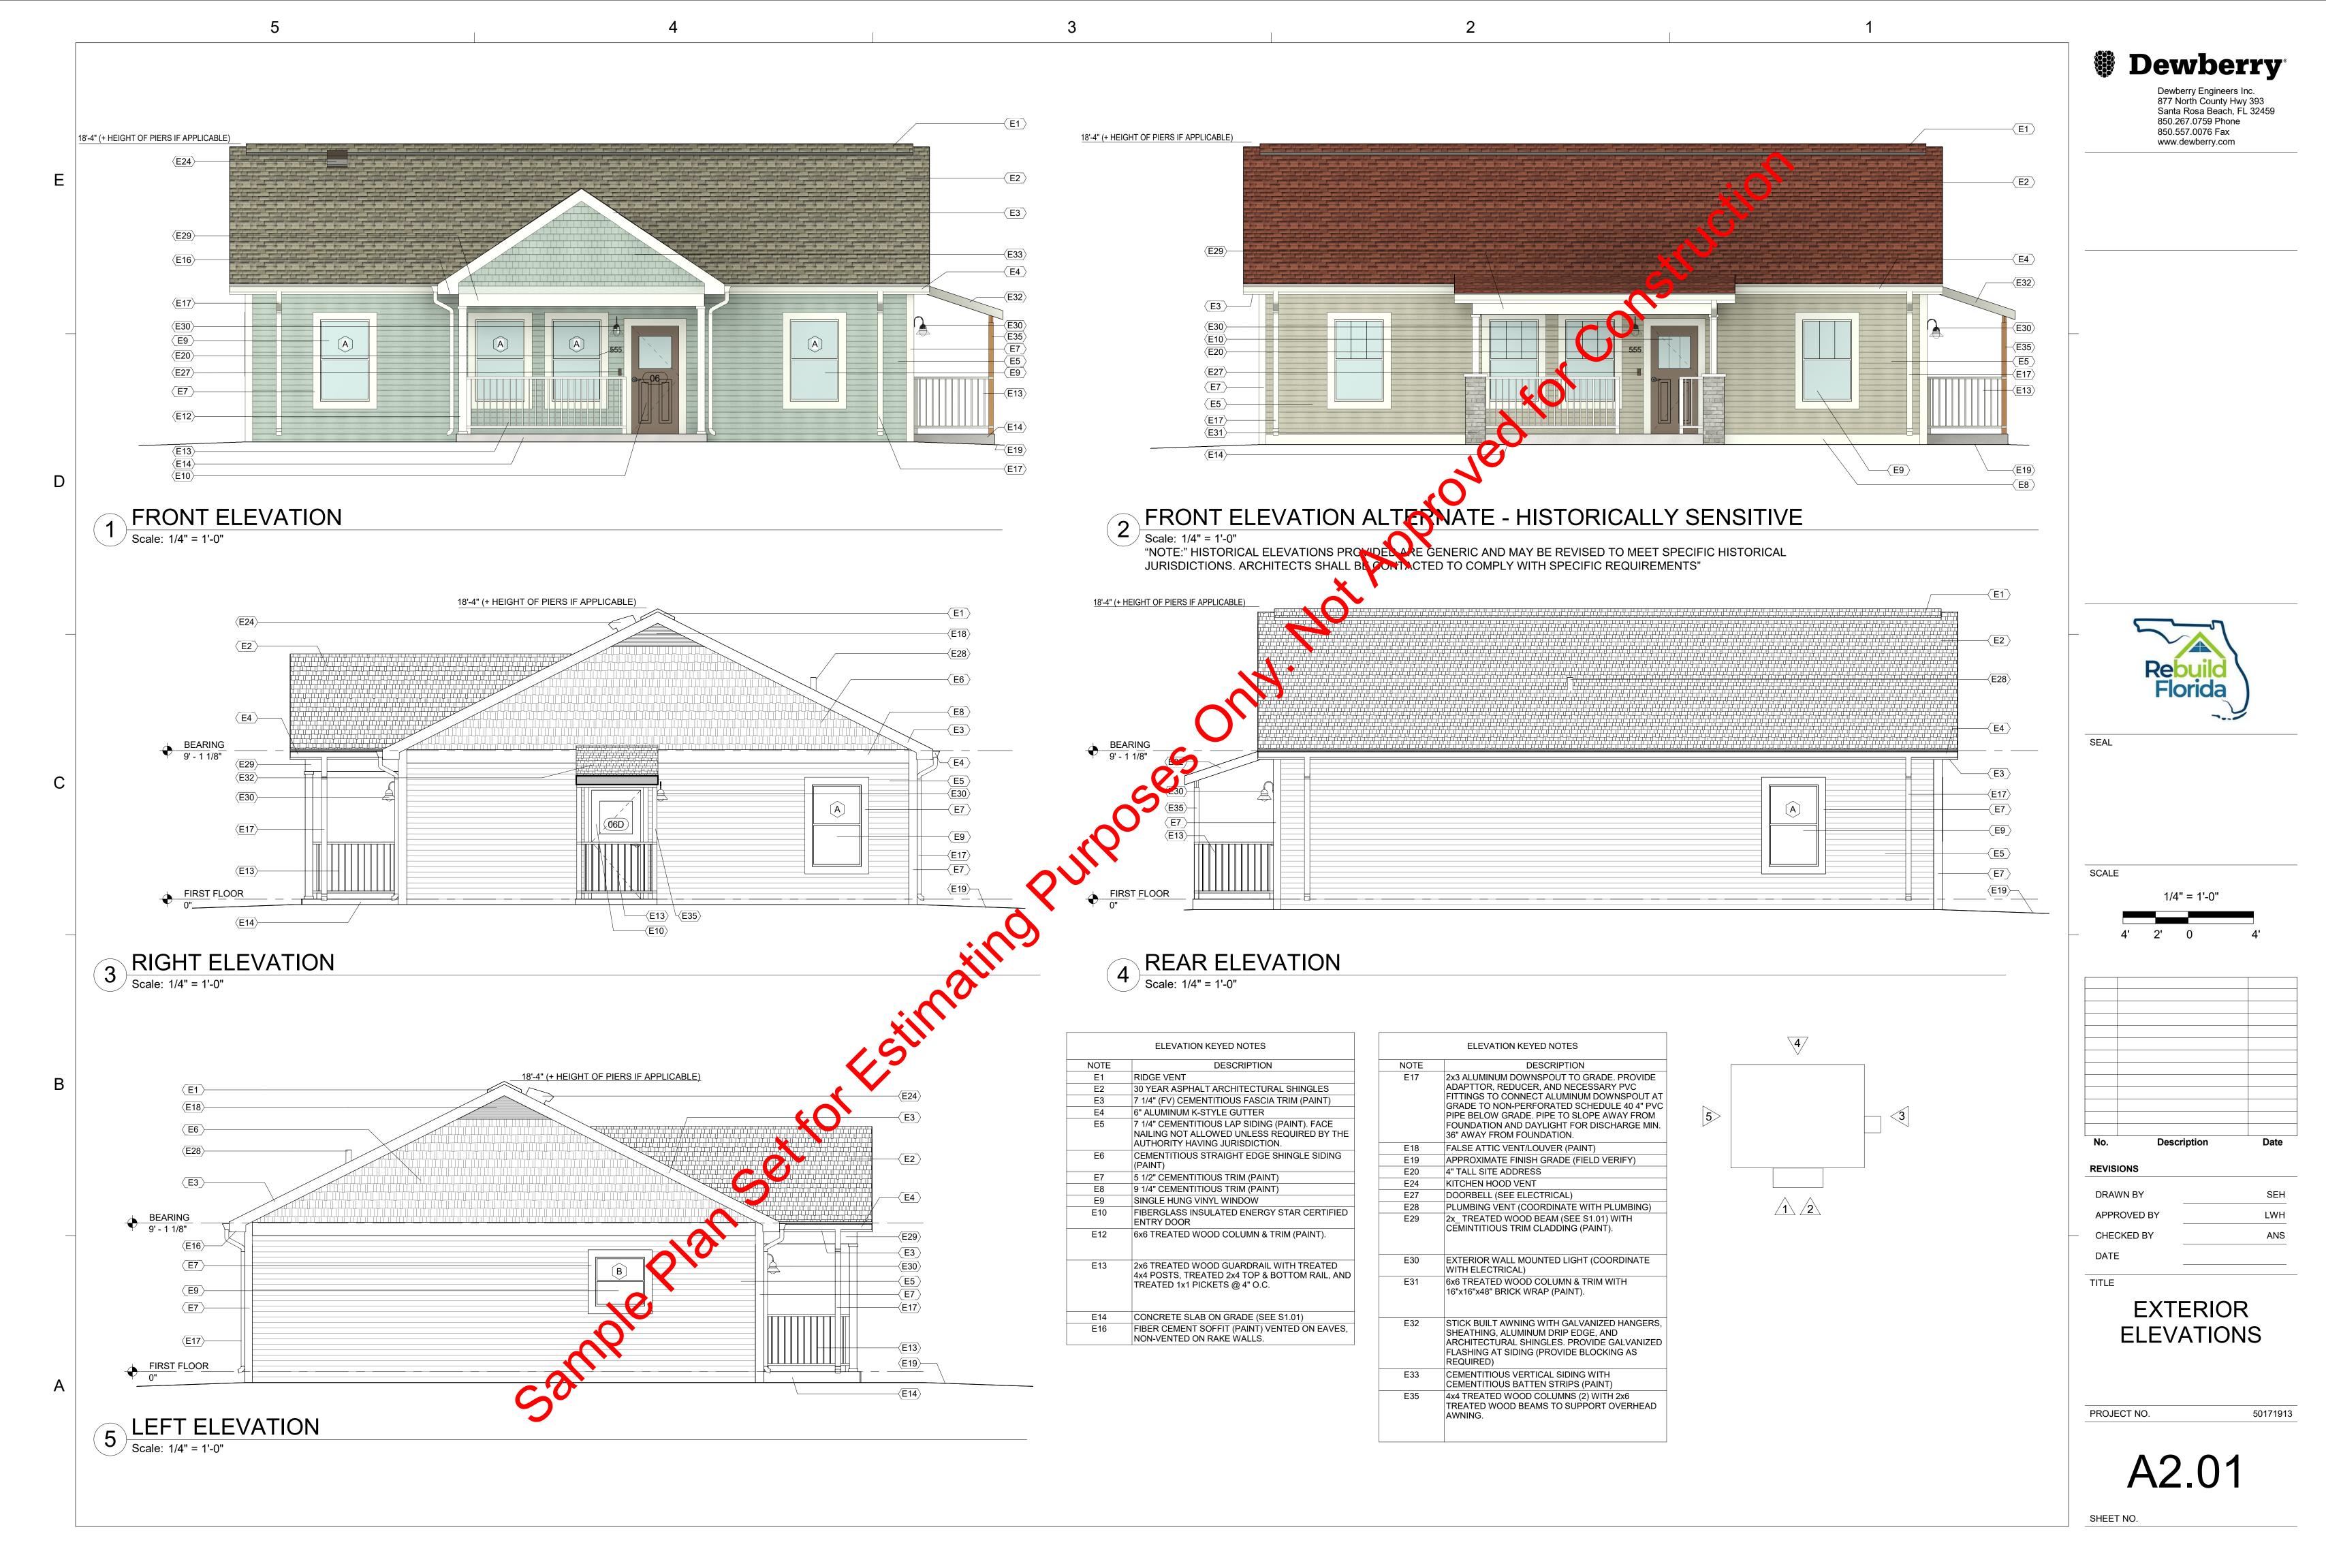


9/13/2024 /:53:47 AM

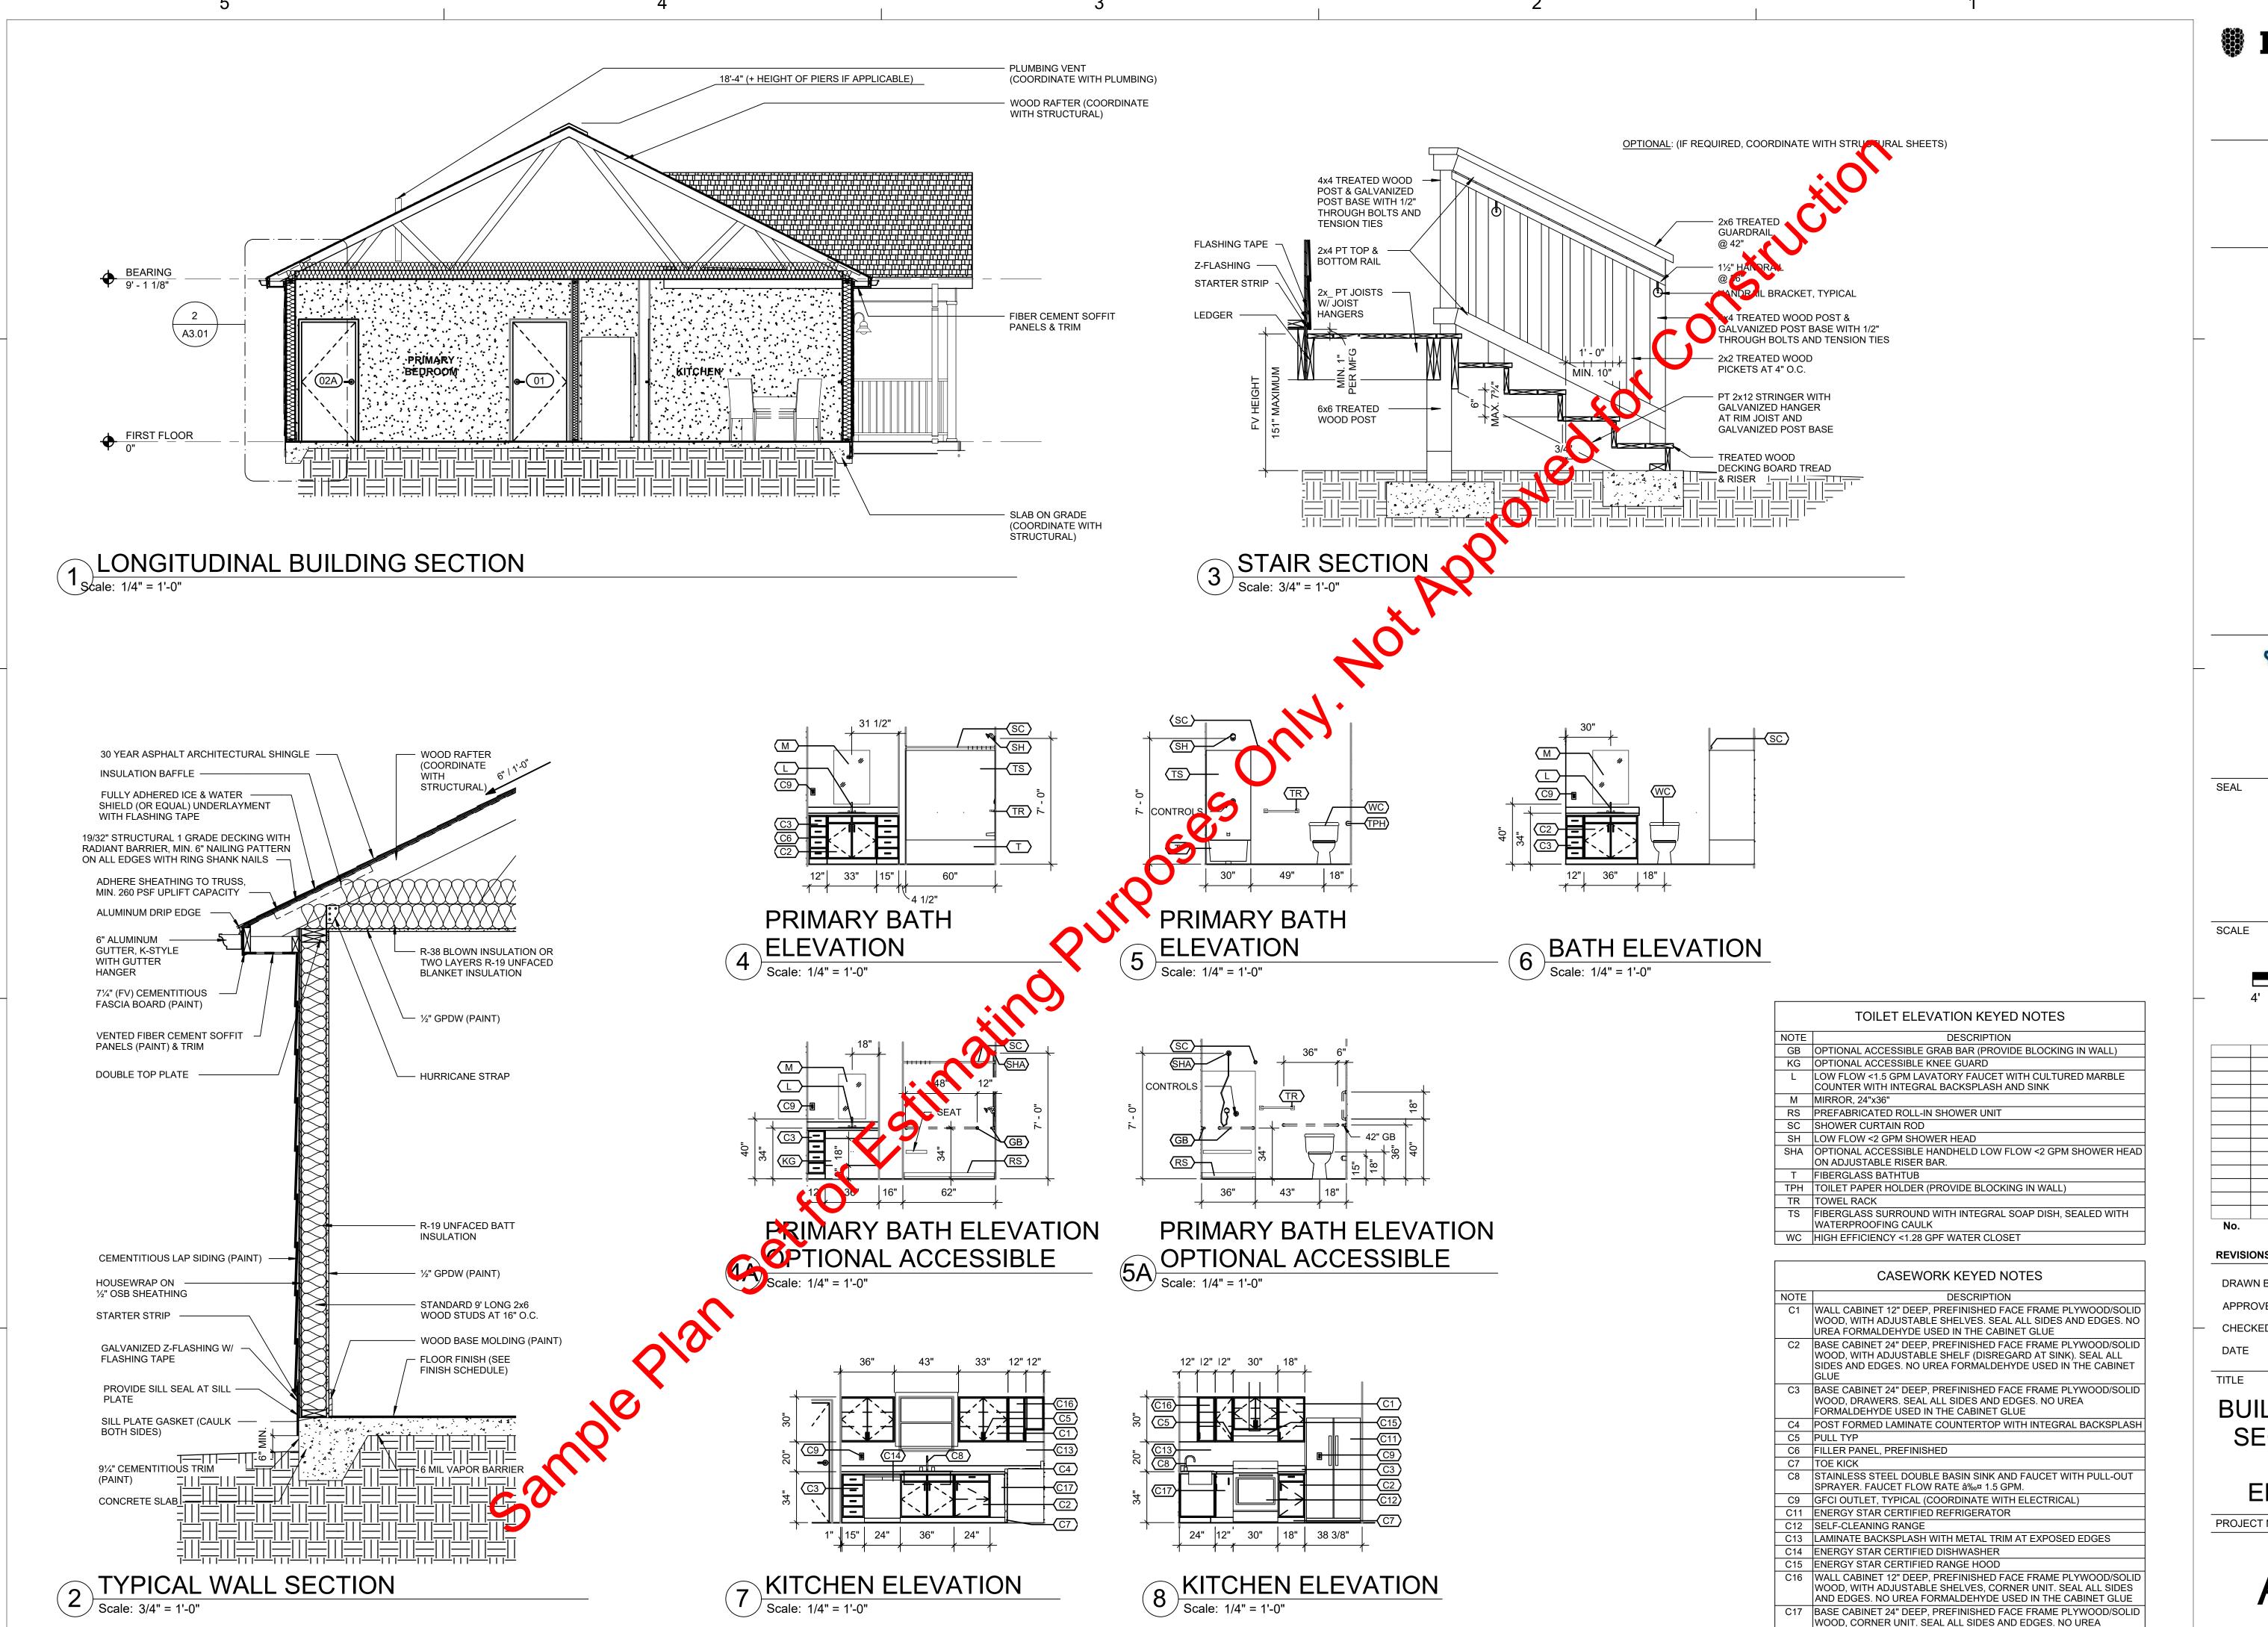

Dewberry Engineers Inc. 877 North County Hwy 393 Santa Rosa Beach, FL 32459 850.267.0759 Phone 850.557.0076 Fax www.dewberry.com

1/4" = 1'-0"

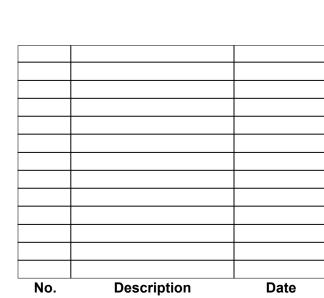

REVISIONS

	DRAWN BY	SEH
	APPROVED BY	LWH
-	CHECKED BY	ANS
	DATE	

BUILDING & WALL SECTIONS AND **INTERIOR ELEVATIONS**


PROJECT NO.

A3.01

50171913

SHEET NO.

FORMALDEHYDE USED IN THE CABINET GLUE

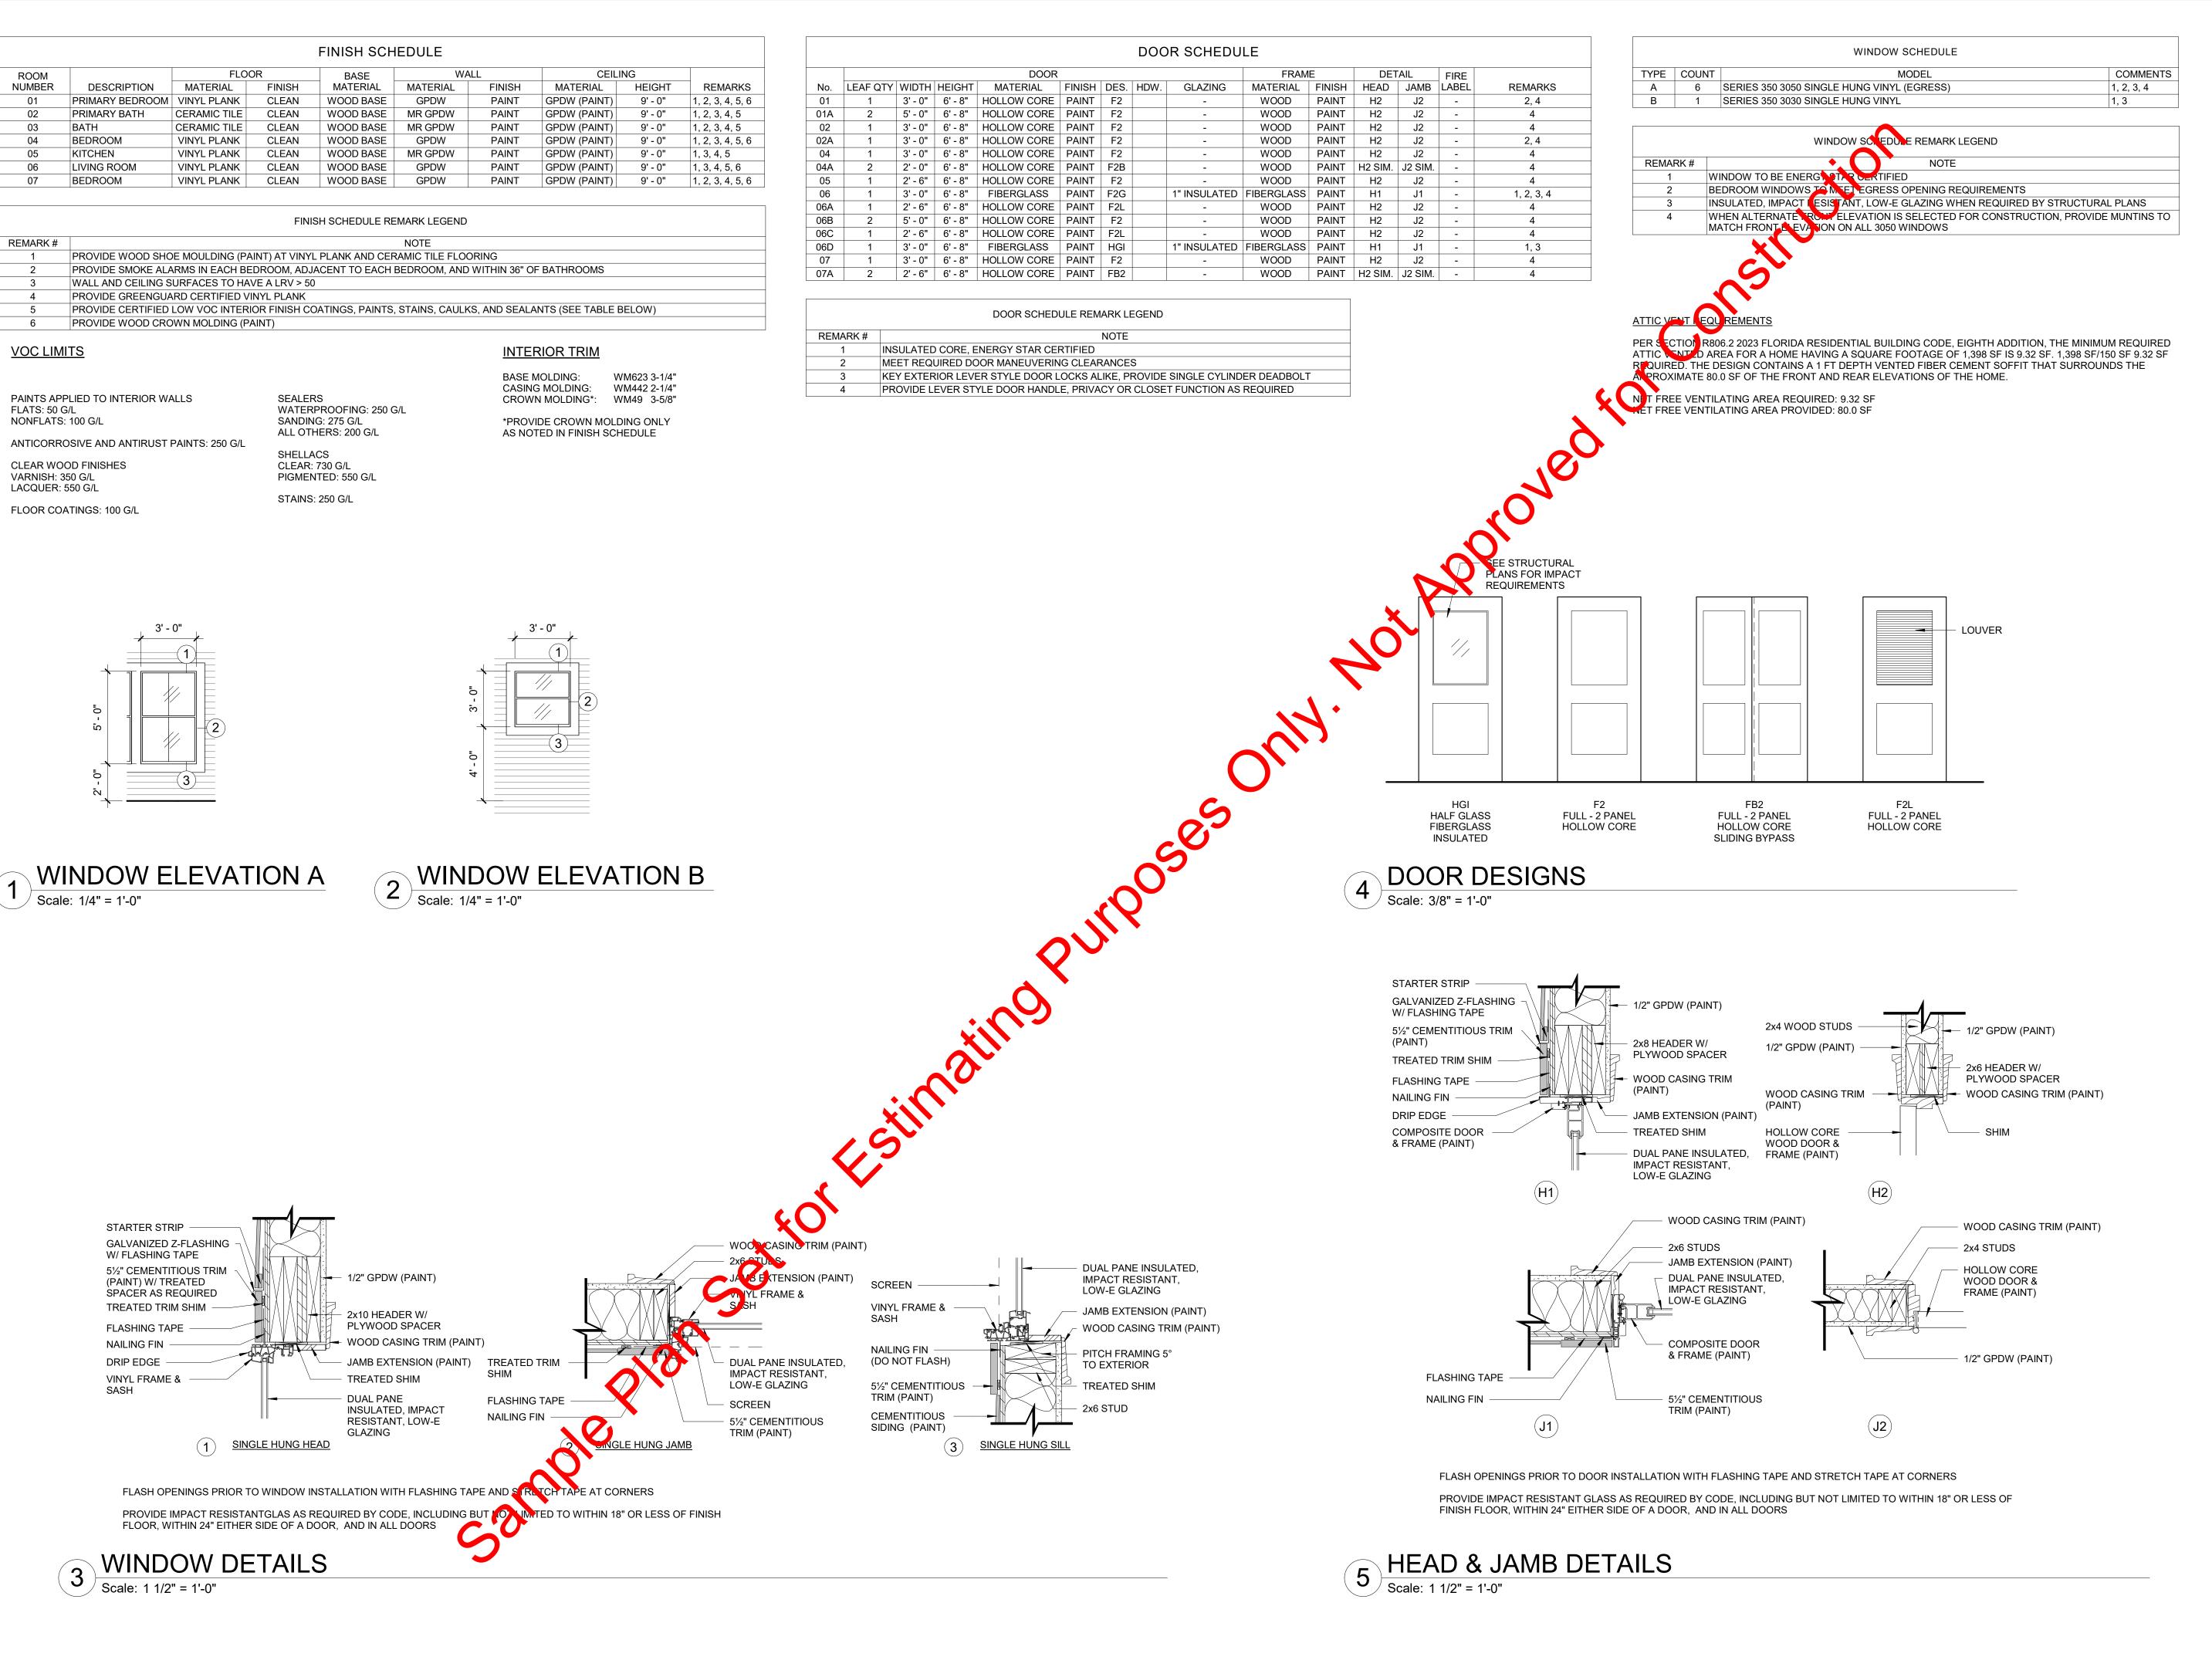

Dewberry Engineers Inc. 877 North County Hwy 393 Santa Rosa Beach, FL 32459 850.267.0759 Phone 850.557.0076 Fax www.dewberry.com

Rebuild Florida

SCALE

SEAL

As indicated

No. Description Date

REVISIONS


DRAWN BY SEH
APPROVED BY LWH
CHECKED BY ANS
DATE


TITLE

FINISH, DOOR, & WINDOW SCHEDULES

PROJECT NO. 50171913

A6.01

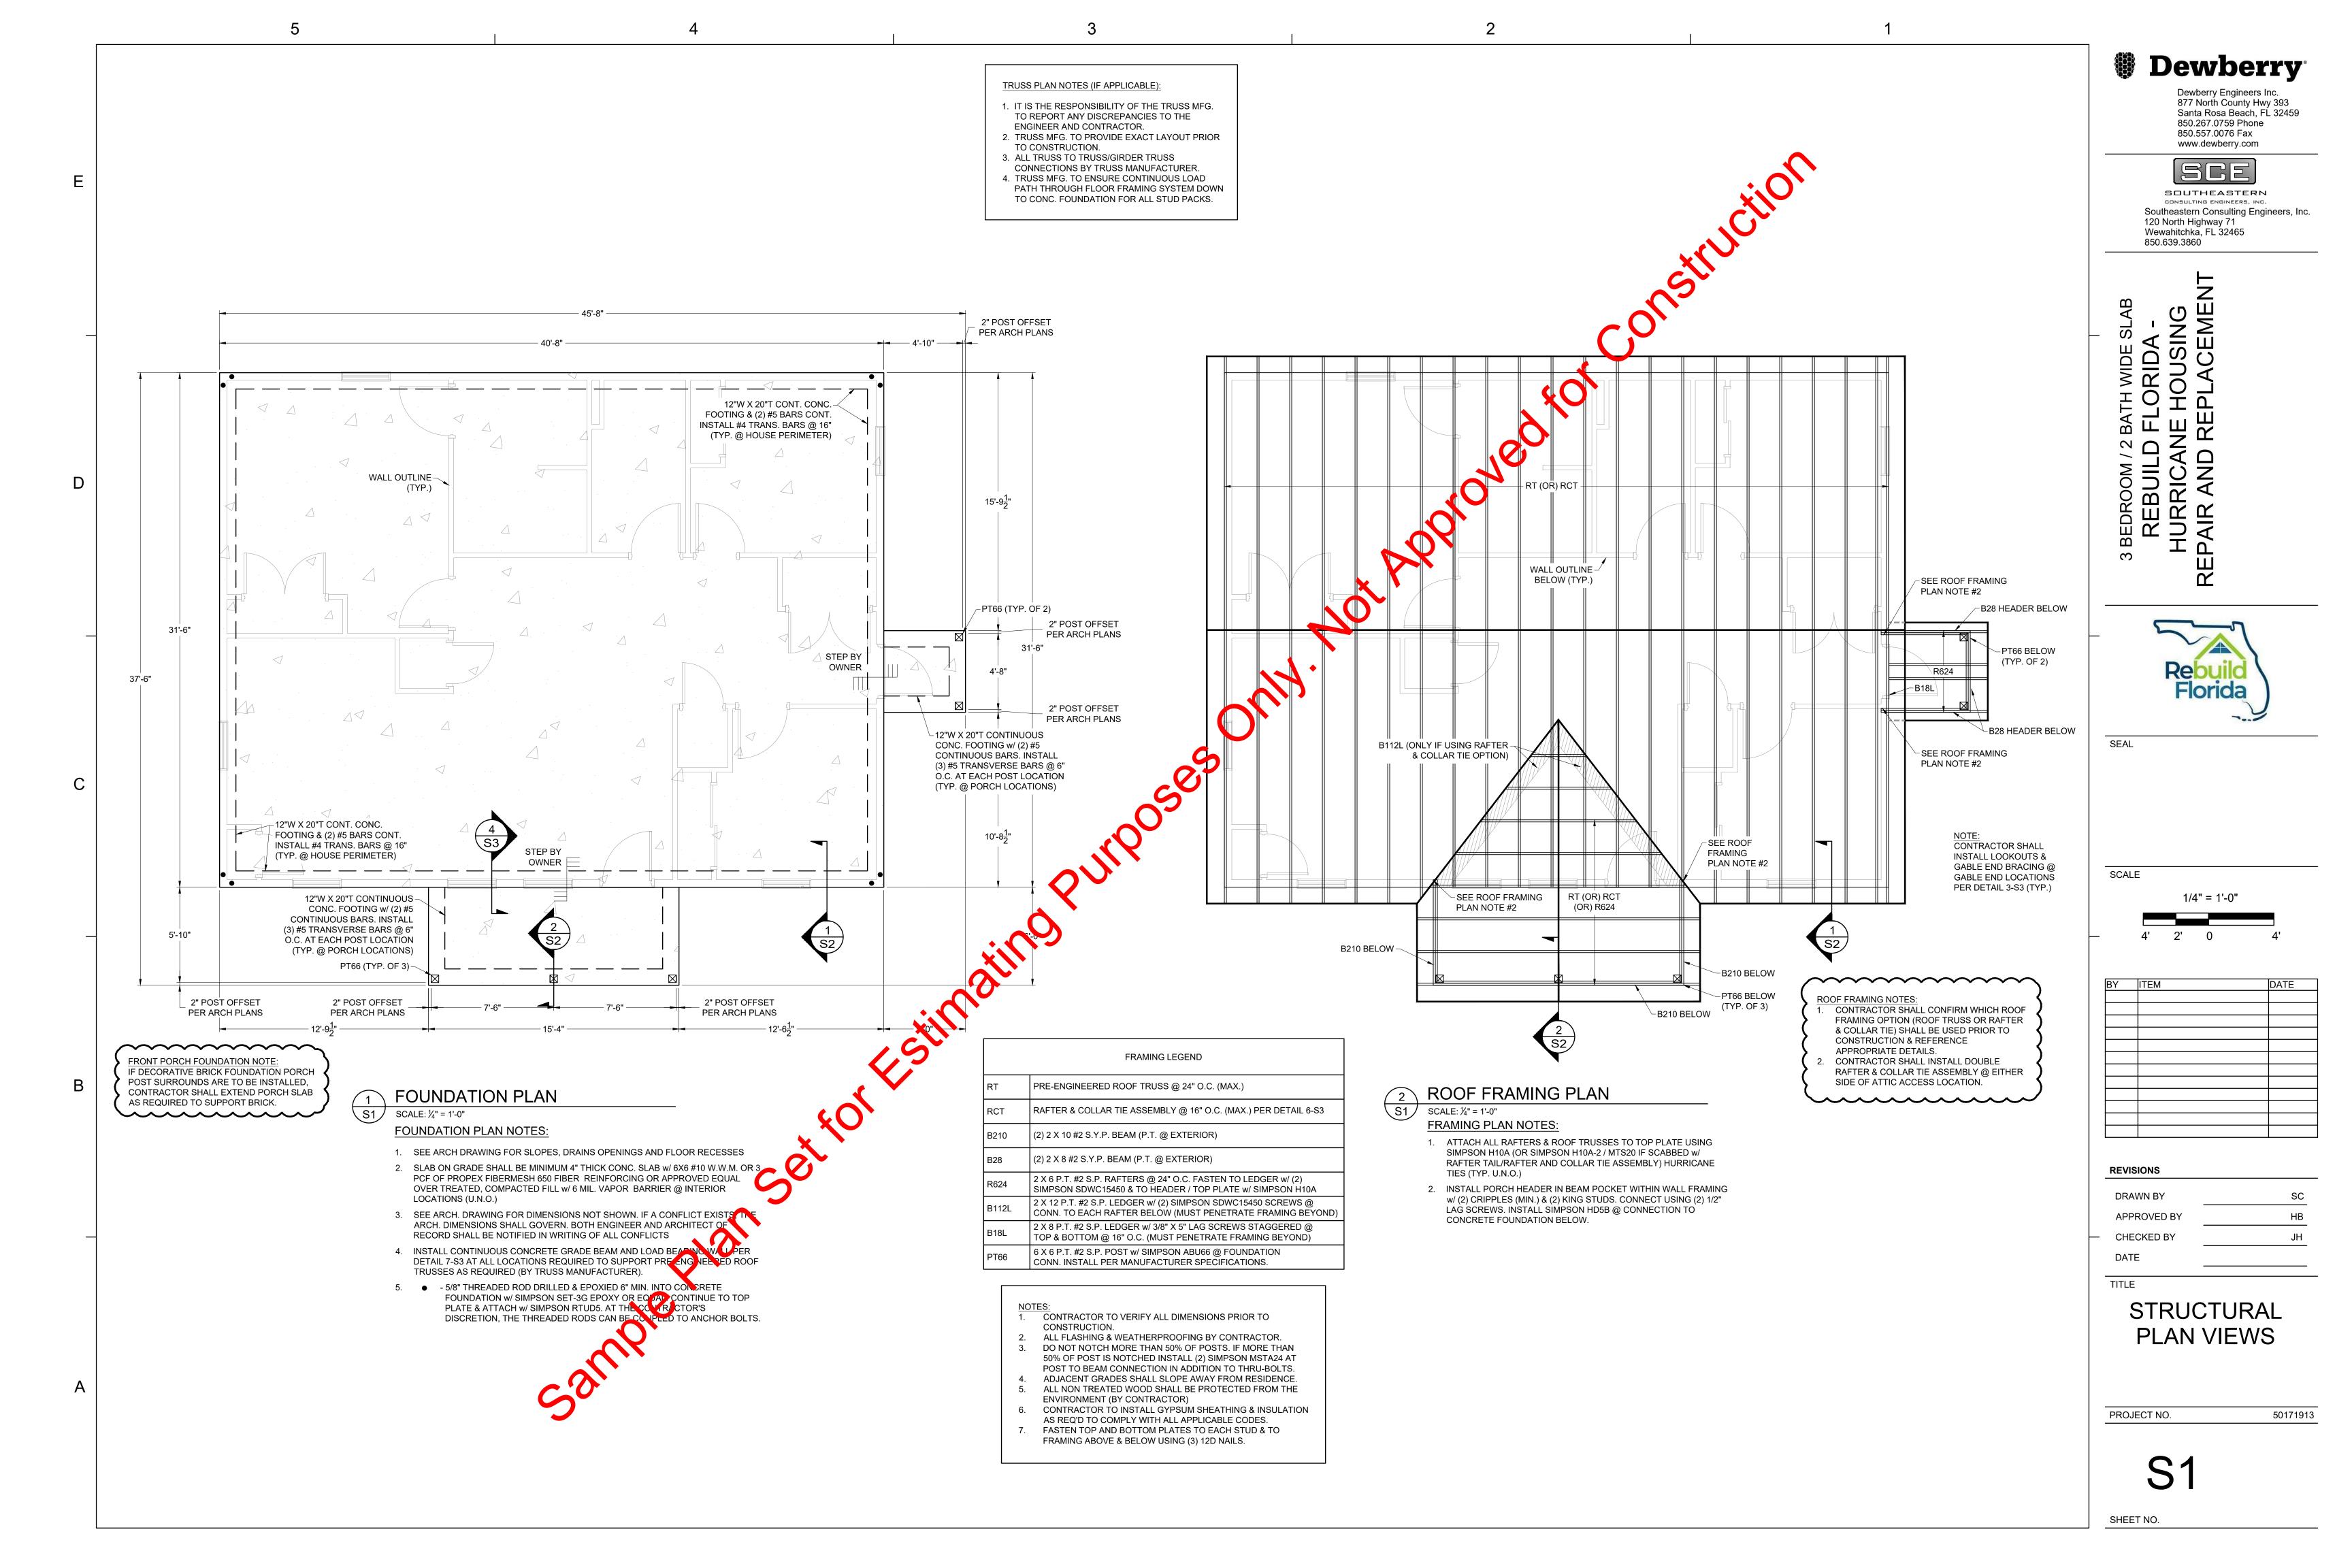

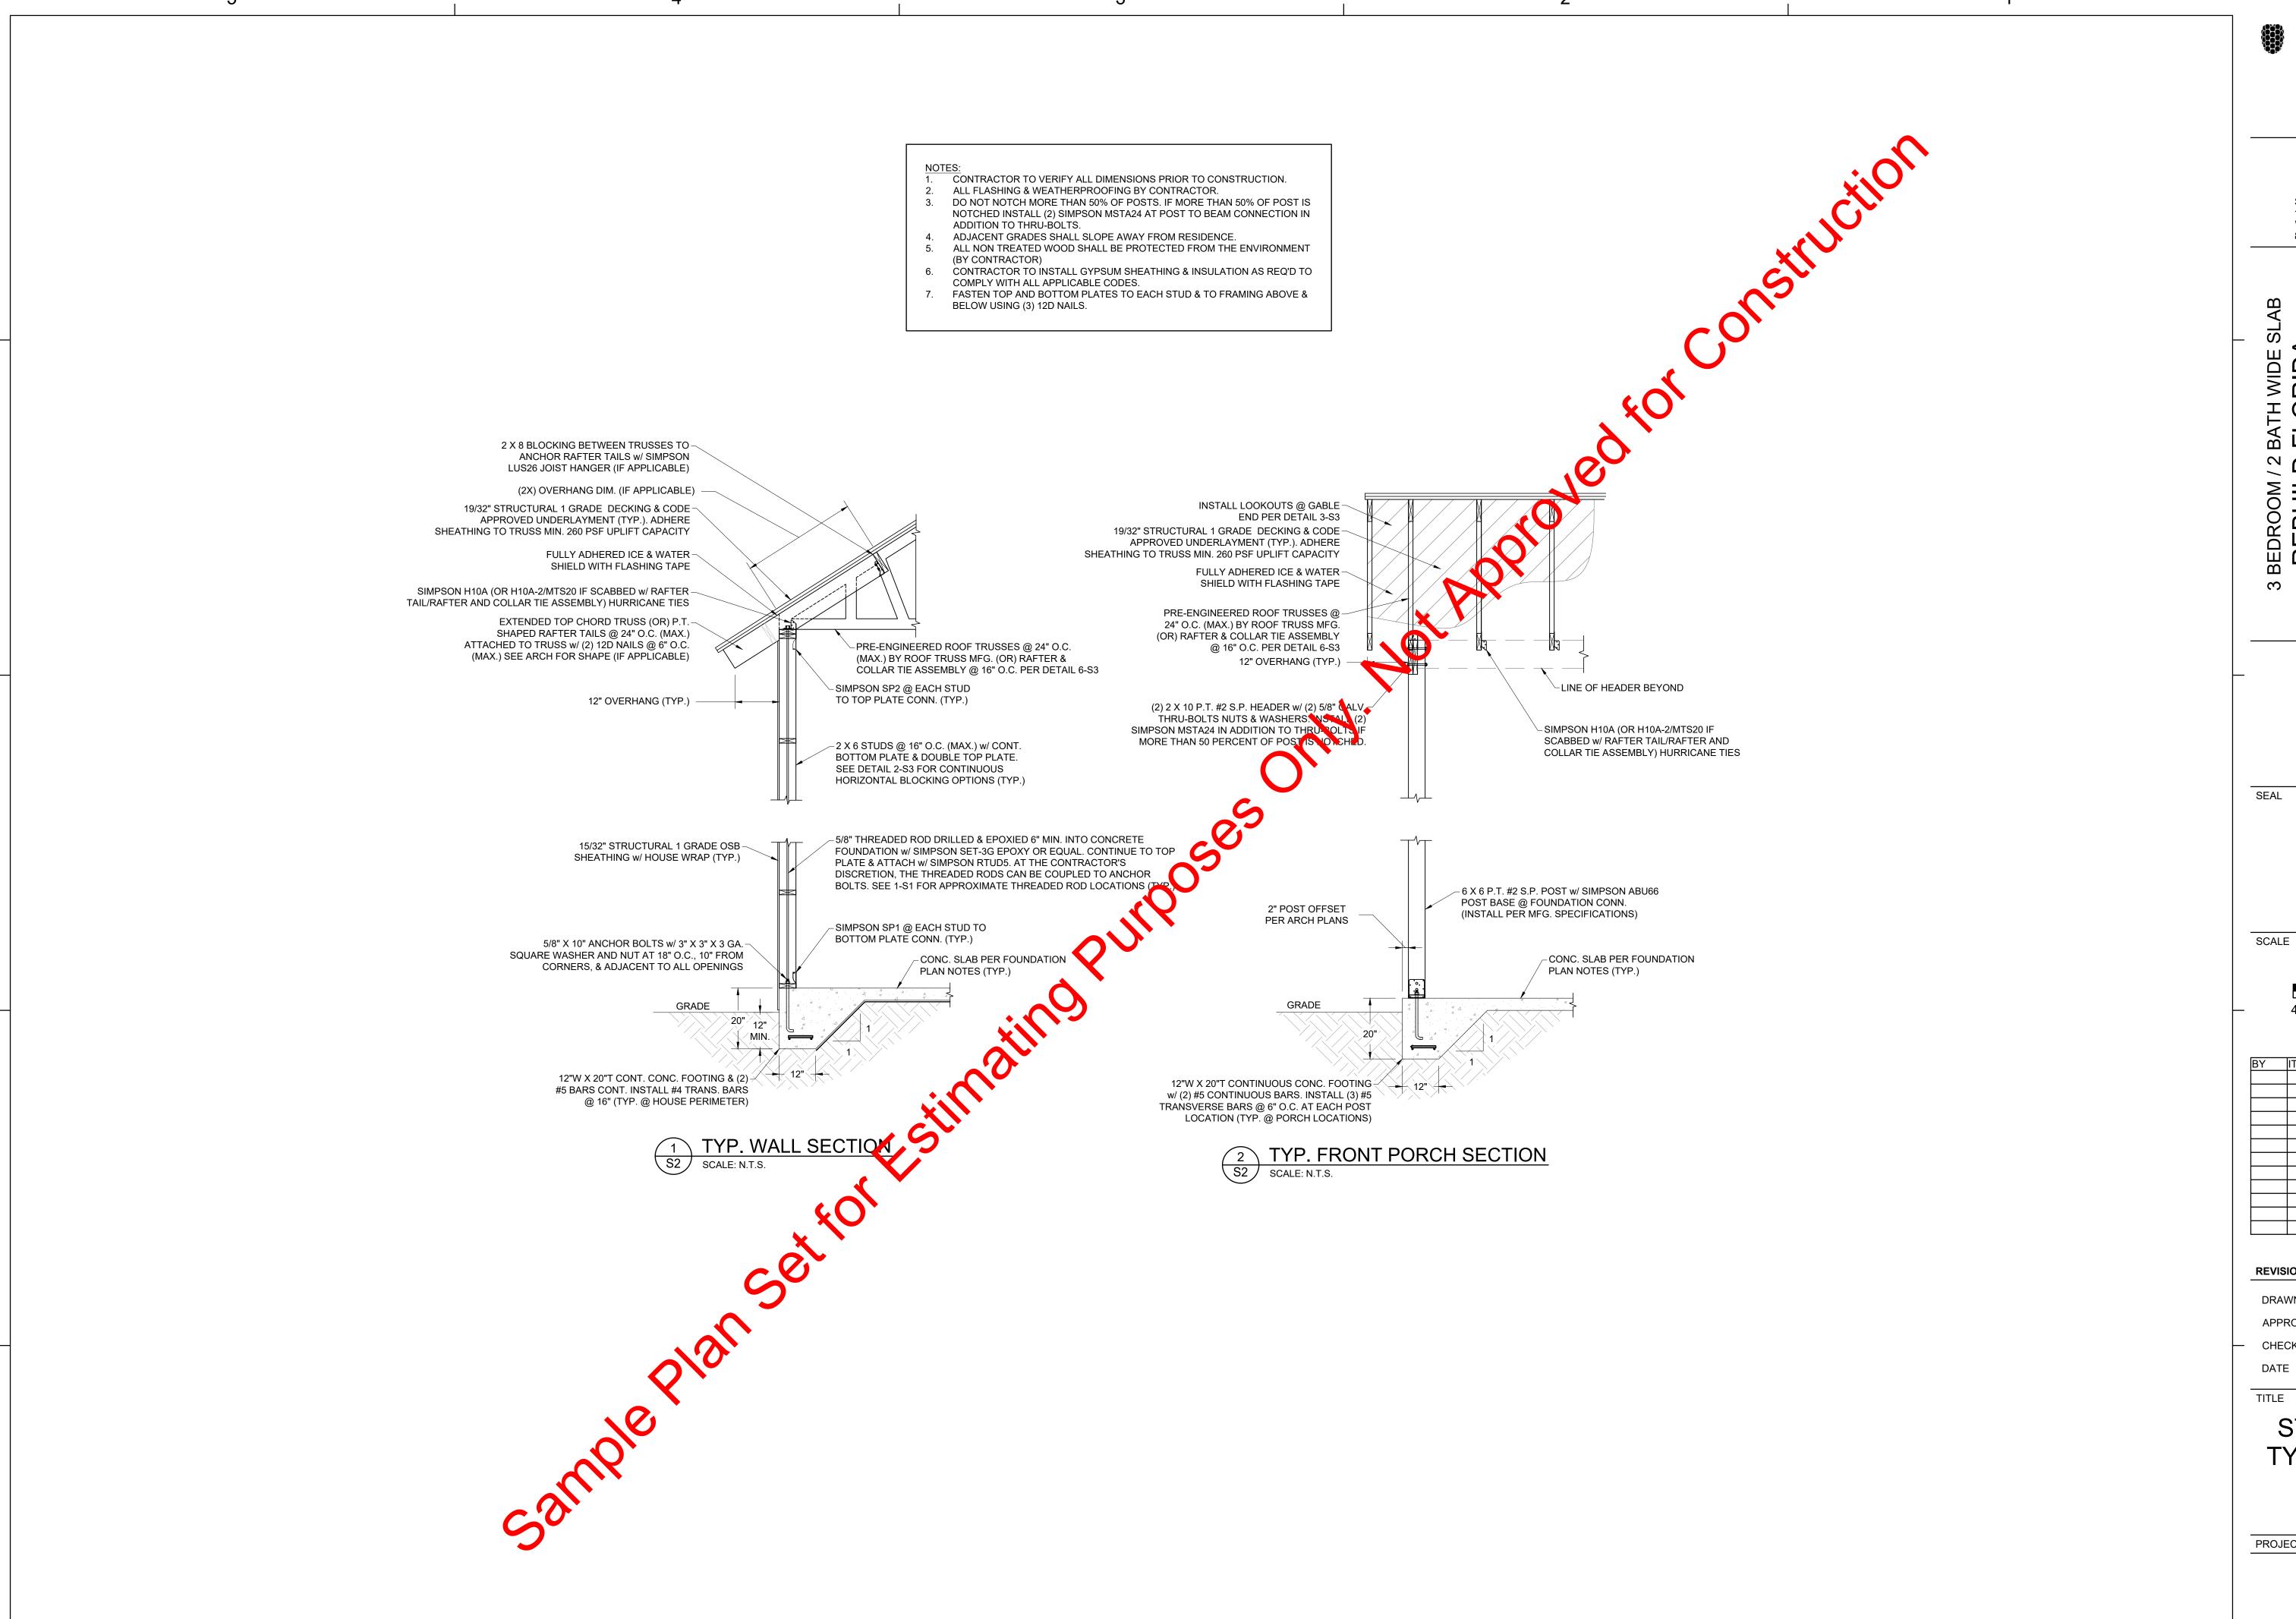

Dewberry Engineers Inc. 877 North County Hwy 393 Santa Rosa Beach, FL 32459 850.267.0759 Phone 850.557.0076 Fax www.dewberry.com

SOUTHEASTERN Southeastern Consulting Engineers, Inc. 120 North Highway 71 Wewahitchka, FL 32465 850.639.3860




	BY	ITEM	DATE
i '			

REVISIONS

DRAWN BY APPROVED B CHECKED B

STRUCTURAL TYP. SECTIONS

PROJECT NO. 50171913

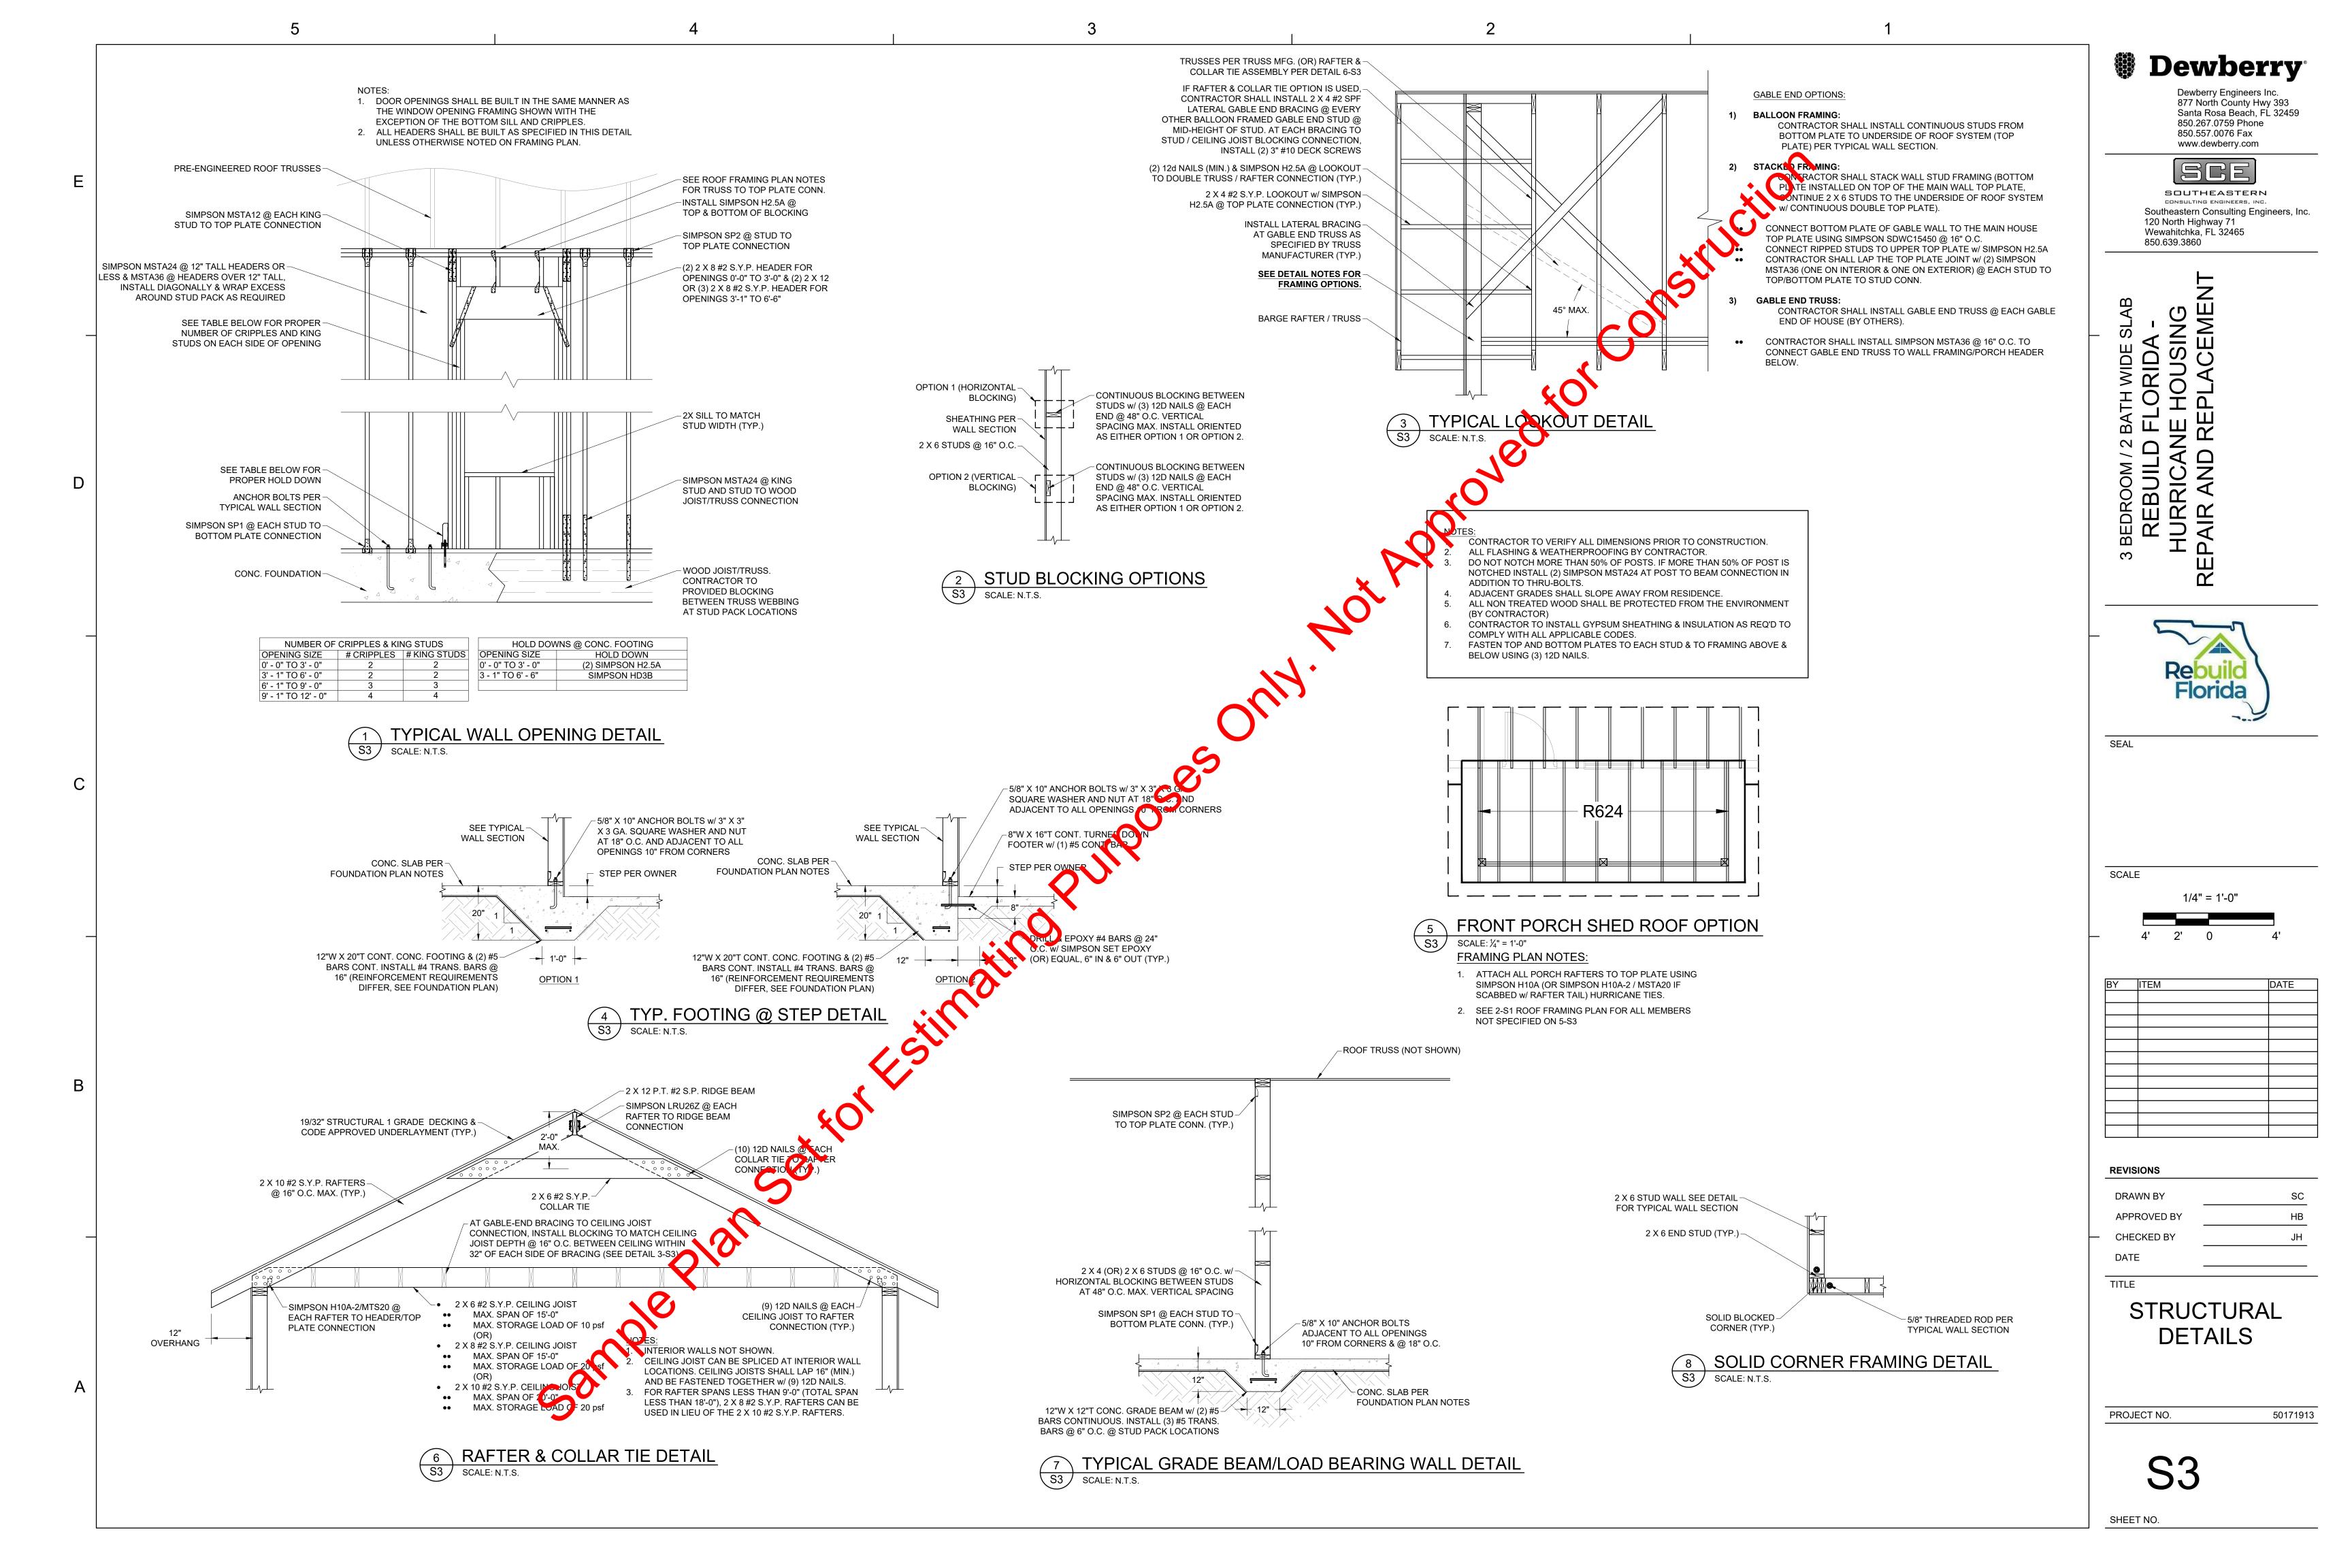

RECORD OF ANY CONFLICT AND/OR OMISSIONS.

- THE CONTRACTOR SHALL COORDINATE ARCHITECTURAL, MECHANICAL, ELECTRICAL, PLUMBING, AND CIVIL WORKS DOCUMENTS WITH THE STRUCTURAL CONTRACT DOCUMENTS. NOTIFICATION SHALL BE MADE TO THE ENGINEER OF
- FOR DIMENSIONS NOT SHOWN ON THE STRUCTURAL CONTRACT DOCUMENTS, SEE THE ARCHITECTURAL PLANS.
- THE CONTRACTOR SHALL VERIFY EXISTING SITE CONDITIONS, DIMENSIONS, AND ELEVATIONS PRIOR TO STARTING WORK THE ENGINEER SHALL BE NOTIFIED IN WRITING OF ANY DISCREPANCIES IN EXISTING SITE CONDITIONS, DIMENSIONS, OR ELEVATIONS TO THOSE SHOWN IN THE STRUCTURAL CONTRACT DOCUMENTS.
- THE REVIEW OF SUBMITTALS AND/OR SHOP DRAWINGS BY THE ENGINEER DOES NOT RELIEVE THE CONTRACTOR OF THE SOLE RESPONSIBILITY TO REVIEW AND CHECK SHOP DRAWINGS PRIOR TO SUBMITTAL TO THE ENGINEER. THE CONTRACTOR REMAINS SOLELY RESPONSIBLE FOR ERRORS AND OMISSIONS ASSOCIATED WITH THE PREPARATION OF SHOP DRAWINGS AS THEY PERTAIN TO MEMBER SIZES, DETAILS, AND DIMENSIONS SPECIFIED IN THE CONTRACT DOCUMENTS. THE CONTRACTOR ALSO SHALL BE RESPONSIBLE FOR MEANS. METHOD. TECHNIQUES. SEQUENCES. AND PROCEDURES OF CONSTRUCTION INCLUDING BUT NOT LIMITED TO DEMOLITION PROCEDURES AND TEMPORARY SHORING.
- THE CONTRACTOR IS SOLELY RESPONSIBLE FOR THE DESIGN, CONSTRUCTION, AND ERECTION OF SAFE AND ADEQUATE BRACING, SHORING, TEMPORARY SUPPORTS, ETC. REQUIRED FOR STABILITY OF THE STRUCTURE DURING ALL INTERMEDIATE STAGES OF CONSTRUCTION AND/OR DEMOLITION.
- IN NO CASE SHALL STRUCTURAL ALTERATIONS OR WORK AFFECTING A STRUCTURAL MEMBER BE MADE, UNLESS APPROVED BY THE ENGINEER OF RECORD IN WRITING.
- NO PROVISION OF ANY REFERENCED STANDARD SPECIFICATION, MANUAL OR CODE (WHETHER OR NOT SPECIFICALLY INCORPORATED BY REFERENCE IN THE CONTRACT DOCUMENTS) SHALL BE EFFECTIVE TO CHANGE THE DUTIES AND RESPONSIBILITIES OF OWNER, CONTRACTOR, ENGINEER, SUPPLIER, OR ANY OF THEIR CONSULTANTS, AGENTS, OR EMPLOYEES FROM THOSE SET FORTH IN THE CONTRACT DOCUMENTS. NOR SHALL IT BE EFFECTIVE TO ASSIGN TO THE STRUCTURAL ENGINEER OF RECORD OR ANY OF THE STRUCTURAL ENGINEER OF RECORD'S CONSULTANTS, AGENTS, OR EMPLOYEES ANY DUTY OR AUTHORITY TO SUPERVISE OR DIRECT THE FURNISHING OR PERFORMANCE OF THE WORK OR ANY DUTY OR AUTHORITY TO UNDERTAKE RESPONSIBILITIES CONTRARY TO THE PROVISIONS OF THE CONTRACT DOCUMENTS.
- CONTRACT DOCUMENTS INCLUDE, BUT ARE NOT LIMITED TO, THE STRUCTURAL DOCUMENTS (DRAWINGS AND SPECIFICATIONS), BUT DO NOT INCLUDE SHOP DRAWINGS, VENDOR DRAWINGS, OR MATERIAL PREPARED AND SUBMITTED BY THE CONTRACTOR.
- 10. REFERENCE TO STANDARD SPECIFICATIONS OF ANY TECHNICAL SOCIETY, ORGANIZATION, OR ASSOCIATION OR TO CODES OF LOCAL OR STATE AUTHORITIES, SHALL MEAN THE LATEST STANDARD, CODE, SPECIFICATION OR TENTATIVE SPECIFICATION ADOPTED AT THE DATE OF TAKING BIDS, UNLESS SPECIFICALLY STATED OTHERWISE
- CONTRACT DOCUMENTS SHALL GOVERN IN THE EVENT OF A CONFLICT WITH THE CODE OF PRACTICE OR SPECIFICATIONS OF ACI, PCI, AISC, SJI OR OTHER STANDARDS. WHERE A CONFLICT OCCURS WITHIN THE CONTRACT DOCUMENTS, THE STRICTEST REQUIREMENT SHALL GOVERN.
- 12. MATERIAL, WORKMANSHIP, AND DESIGN SHALL CONFORM TO THE REFERENCED BUILDING CODE.
- 13. CONTRACTOR SHALL OBTAIN AND COORDINATE EDGE OF SLAB DIMENSIONS, OPENING LOCATIONS AND DIMENSIONS, DEPRESSED SLAB LOCATIONS AND EXTENTS, SLAB SLOPES, CURB LOCATIONS, AND CMU WALL LOCATIONS. ARCHITECT/STRUCTURAL ENGINEER SHALL BE NOTIFIED OF ANY DISCREPANCY OR OMISSION.
- 14. $\,$ CONTRACTOR HAS SOLE RESPONSIBILITY FOR MEANS, METHODS, SAFETY, TECHNIQUES, SEQUENCES, AND PROCEDURES OF CONSTRUCTION.
- 15. CONTRACTOR HAS SOLE RESPONSIBILITY TO COMPLY WITH ALL OSHA REGULATIONS.
- 16. REPRODUCTION OF STRUCTURAL DRAWINGS FOR SHOP DRAWINGS IS NOT PERMITTED. ELECTRONIC DRAWING FILES WILL NOT BE PROVIDED TO THE CONTRACTOR.
- 17. SUBMIT SHOP DRAWINGS WHICH ADEQUATELY DEPICT THE STRUCTURAL ELEMENTS AND CONNECTIONS SHOWN IN THE CONTRACT DOCUMENTS. SHOP DRAWINGS SHALL BE SEALED BY ENGINEER LICENSED IN THE PROJECT STATE. REVIEW OF SHOP DRAWINGS SHALL BE FOR CONFORMANCE WITH THE CONTRACT DOCUMENTS REGARDING ARRANGEMENT AND SIZES OF MEMBERS AND THE CONTRACTOR'S INTERPRETATION OF THE DESIGN LOADS AND CONTRACT DOCUMENT DETAILS. REVIEW OF SUBMITTALS OR SHOP DRAWINGS BY THE ARCHITECT/STRUCTURAL ENGINEER DOES NOT RELIEVE THE CONTRACTOR OF THE SOLE RESPONSIBILITY TO REVIEW AND CHECK ALL SUBMITTALS AND SHOP DRAWINGS BEFORE SUBMITTING TO THE STRUCTURAL ENGINEER. REVIEW OF SUBMITTALS OR SHOP DRAWINGS BY THE ARCHITECT/STRUCTURAL ENGINEER DOES NOT RELIEVE THE CONTRACTOR OF FULL RESPONSIBILITY FOR COMPLIANCE WITH THE CONTRACT DOCUMENTS. CONTRACTOR REMAINS SOLELY RESPONSIBLE FOR ERRORS AND OMISSIONS ASSOCIATED WITH THE PREPARATION OF SHOP DRAWINGS AS THEY PERTAIN TO MEMBER SIZES, DETAILS, AND DIMENSIONS SPECIFIED IN THE CONTRACT DOCUMENTS. SHOP DRAWINGS SHALL BE SEALED BY ENGINEER LICENSED IN PROJECT STATE.
- 18. WHERE A SECTION OR DETAIL IS SHOWN OR DETAILED FOR ONE CONDITION, IT SHALL APPLY TO ALL SIMILAR AND LIKE CONDITIONS. DETAILS LABELED "TYPICAL" ON THE STRUCTURAL DRAWINGS APPLY TO ALL SITUATIONS OCCURRING ON THE PROJECT THAT ARE THE SAME OR SIMILAR. THE CONTRACTOR SHALL CONSIDER ALL OF THE CONTRACT DOCUMENTS IN DETERMINING SIMILAR AND LIKE CONDITIONS.
- 19. ALL FLASHING AND WATERPROOFING BY CONTRACTOR.
- 20. ALL ADA REQUIREMENTS SHALL BE ADHERED (IF APPLICABLE) TO AND MAY NOT BE SHOWN ON THESE PLANS IN ITS
- OWNER/CONTRACTOR SHALL PROVIDE APPLICABLE FIRE PROTECTION DESIGN/DOCUMENTS NOT SHOWN ON THIS PLAN

21. PLANS DO NOT INCLUDE ANY FIRE ESCAPE PLAN, FIRE SPRINKLER, OR FIRE RELATED DESIGN ASPECTS, U.N.O..

- 22. OWNER/CONTRACTOR SHALL BE RESPONSIBLE FOR ALL THRESHOLD INSPECTION REQUIREMENTS (IF APPLICABLE).
- 23. ATTACH STAIR STRINGERS & LANDING FRAMING TO STAIRWELL STUD FRAMING w/ (2) SIMPSON SDWC15600 @ 16" O.C.
- 24. INSTALL LATERAL BRACING AT GABLE END TRUSS AS SPECIFIED BY TRUSS MANUFACTURER

CODE DESIGN

WIND LOADS: SEE TABLE

ESTIMATED DEFLECTIONS (IN INCHES) ARE AS FOLLOWS: LIVE LOAD DEAD + LIVE LOAD L/240 OR < 1" ROOF MEMBERS: L/180

FLOOR MEMBERS: L/360 OR $< \frac{1}{2}$ " L/240 WHERE, L = SPAN LENGTH (IN INCHES) BETWEEN CENTERLINES OF SUPPORTS. (FOR CANTILEVERS, L IS TWICE THE LENGTH OF THE CANTILEVER.)

FOUNDATION

- FOUNDATION DESIGN IS BASED ON AN ASSUMED ALLOWABLE BEARING PRESSURE OF 2000 PSF. STRUCTURAL ENGINEER IS NOT RESPONSIBLE FOR SUBSURFACE CONDITIONS ENCOUNTERED IN THE FIELD DIFFERENT FROM THOSE ASSUMED
- ALL FOUNDATION BEARING SOIL SHALL BE COMPACTED TO 98% STANDARD PROCTOR OR 95% MODIFIED PROCTOR AS SPECIFIED BY AASHTO T-99 AND AASHTO T-180, RESPECTIVELY.
- UNLESS OTHERWISE NOTED, ALL CONSTRUCTION JOINTS SHALL BE CONSTRUCTED w/ 3/4" X 3/4" (MIN.) KEY WAY. ALL SURFACES SHALL BE CLEANED BEFORE PLACEMENT OF ADJACENT CONCRETE. CONTRACTION JOINTS / SAW CUTS SHALL BE INSTALLED AT 10' O.C. EACH WAY OR NO GREATER THAN 30 TIMES THE SLAB THICKNESS (LESSER OF THE TWO) AND SHALL BE A MINIMUM OF 1/8" WIDE AND TO A DEPTH OF 25% OF THE SLAB THICKNESS (MIN.) UNLESS OTHERWISE NOTED. ALL CONCRETE SLABS LOCATED WITHIN VE FLOOD ZONES SHALL BE SCORED IN 25 SQ. FT. SECTIONS (MAXIMUM). REFER TO F.D.E.P. PERMIT DRAWINGS FOR ALL CONCRETE SLABS LOCATED SEAWARD OF THE COASTAL CONSTRUCTION CONTROL LINE.
- 4. STRUCTURAL TESTING/INSPECTION AGENCY SHALL CERTIFY THE BEARING MEDIUM BEFORE STARTING CONSTRUCTION. NO FOOTINGS SHALL BE PLACED IN WATER.
- ANY SOIL CONDITION ENCOUNTERED DURING EXCAVATION THAT IS CONTRARY TO THE CONDITIONS USED FOR DESIGN OF FOOTINGS AS OUTLINED IN THESE NOTES OR ON THE DRAWINGS SHALL BE BROUGHT TO THE ATTENTION OF THE ARCHITECT OR ENGINEER OF RECORD BEFORE PROCEEDING.
- BACK FILL BOTH SIDES OF FOUNDATION WALLS AT SAME TIME TO PREVENT OVERTURNING.

CONCRETE MASONRY

- CONCRETE MASONRY WORK SHALL CONFORM TO ACI 530, BUILDING CODE REQUIREMENTS FOR MASONRY STRUCTUR AND ACI 530.1, SPECIFICATION FOR MASONRY STRUCTURES.
- MINIMUM COMPRESSIVE STRENGTH OF CONCRETE MASONRY SHALL BE F'M = 1,500 PSI.
- MORTAR SHALL COMPLY WITH THE BUILDING CODE REQUIREMENTS FOR CONCRETE MASONRY AND SHALL FOLLOWING TYPE: WALLS BELOW GRADE TYPE M OR S

- CONCRETE MASONRY UNITS SHALL BE GROUTED WITH 2,500 PSI COARSE GROUT AS SHOWN IN DOCUMENTS. GROUT SHALL CONFORM TO ASTM C476.
- PROVIDE HORIZONTAL JOINT REINFORCEMENT WITH NO. 9 GAGE LONGITUDINAL WIRES AT 16" VERTICALLY, UNLESS NOTED OTHERWISE. PROVIDE SPECIAL ACCESSORIES FOR CORNERS, INTERSECTIONS, ETC.
- MINIMUM VERTICAL WALL REINFORCEMENT SHALL BE #5 @32" UNLESS NOTED OTHERWISE.
- DEFECTIVE AREAS IN CONCRETE INCLUDING, BUT NOT LIMITED TO, HONEY-COMBING, SPALLS, AND CRACKS WITH WIDTHS EXCEEDING 0.01 INCH SHALL BE REPAIRED. EXTENTS OF DEFECTIVE AREA TO BE DETERMINED BY THE STRUCTURAL
- REINFORCING DOWELS MUST BE TIED IN PLACE PRIOR TO POURING FOOTING. "WET-STICKING" IS NOT ALLOWED.

REINFORCEMENT

1. REINFORCING STEEL SHALL CONFORM TO ASTM A615, GRADE 60, UNLESS NOTED OTHERWISE

- 2. WELDED WIRE FABRIC SHALL CONFORM TO ASTM A185 AND HAVE MINIMUM SIDE AND END LAPS OF 8".FOR ALL MONOLITHIC FOOTINGS, A DOUBLE LAYER OF WELDED WIRE FABRIC SHALL BE INSTALLED WITHIN 3'-0" OF ALL FOOTINGS (3" CLEAR OF OUTSIDE PERIMETER OF FOOTING)
- REINFORCING STEEL SHALL ONLY BE WELDED OR TACK-WELDED IF IT CONFORMS TO ASTM A706, AND AWS D1.4. REINFORCING SHALL NOT BE WELDED NOR TACK-WELDED UNLESS APPROVED BY THE STRUCTURAL ENGINEER OF RECORD.
- SUBMIT SHOP DRAWINGS WHICH ADEQUATELY DEPICT THE REINFORCING BAR SIZES AND PLACEMENT WRITTEN DESCRIPTION OF REINFORCEMENT WITHOUT ADEQUATE SECTIONS, ELEVATIONS, AND DETAILS IS
- PROVIDE DOWELS FROM FOUNDATIONS THE SAME SIZE AND NUMBER AS THE VERTICAL WALL OR COLUMN REINFORCING, UNLESS NOTED OTHERWISE. REINFORCING DOWELS MUST BE TIED IN PLACE PRIOR TO POURING FOOTING. "WET-STICKING" IS NOT ALLOWED.
- PLACE REINFORCEMENT AS FOLLOWS, UNLESS NOTED OTHERWISE:
- 6.1. CAST-IN-PLACE (NON POST-TENSIONED) CONCRETE REINFORCEMENT COVER
- PERMANENTLY EXPOSED TO EARTH CAST AGAINST THE EARTH EXPOSED TO EARTH OR WEATHER: FOR BARS LARGER THAN A NO. 5 BAR

NO. 5 BARS OR SMALLER

1 3/4" CLEAR COLUMN TIES 6.2. MASONRY REINFORCING STEEL SHALL BE PLACED IN THE CENTER OF CMU CELLS, UNLESS NOTED OTHERWISE.

3" CLEAR

2" CLEAR

1½" CLEAR


6.00

16

REINFORCEMENT SHALL BE SPLICED ONLY AT LOCATIONS SHOWN OR NOTED IN THE STRUCTURAL DOCUMENTS, EXCEPT REINFORCEMENT MARKED "CONTINUOUS" CAN BE SPLICED AT LOCATIONS DETERMINED BY CONTRACTOR. SPLICES AT OTHER LOCATIONS SHALL BE APPROVED IN WRITING BY THE STRUCTURAL ENGINEER. REINFORCING STEEL SPLICES SHALL BE AS FOLLOWS, UNLESS NOTED OTHERWISE:

	MI	NIMUM LAP SP	LICE LENGTH ((IN.) - 3000 PSI	CONCRETE	
	No. 3	No. 4	No. 5	No. 6	No. 7	No. 8
	22	29	36	43	63	72
	MINIMUN	I LAP SPLICE L	ENGTH (IN.) -	1500 PSI NORN	MAL WEIGHT C	MU
6-in CMU WALL	19	25	39	81	NA	NA
8-in CMU WALL	19	25	31	57	79	113
12-in CMU WALL	19	25	31	53	61	75
	RECOMMEN	NDED END HOO	OKS ANCHORA	GE LENGTH (IN	N.) - 3000 PSI C	ONCRETE
	No. 3	No. 4	No. 5	No. 6	No. 7	No. 8

 3.75



4.50

5.25

POST INSTALLED ANCHORS

A or G

2.25

6

3.00

POST-INSTALLED ANCHORS SHALL ONLY BE USED WHERE SPECIFIED ON THE CONSTRUCTION DOCUMENTS THE CONTRACTOR SHALL OBTAIN APPROVAL FROM THE ENGINEER-OF-RECORD PRIOR TO INSTALLING POST-INSTALLED ANCHORS IN PLACE OF MISSING OR MISPLACED CAST-IN-PLACE ANCHORS. CARE SHALL BE TAKEN IN PLACING POST-INSTALLED ANCHORS TO AVOID CONFLICTS WITH EXISTING REBAR. HOLES SHALL BE DRILLED AND CLEANED IN ACCORDANCE WITH THE MANUFACTURER'S WRITTEN INSTRUCTIONS. SUBSTITUTION REQUESTS FOR PRODUCTS OTHER THAN THOSE SPECIFIED BELOW SHALL BE SUBMITTED BY THE CONTRACTOR TO THE ENGINEER-OF-RECORD ALONG WITH CALCULATIONS THAT ARE PREPARED & SEALED BY A REGISTERED PROFESSIONAL ENGINEER. THE CALCULATIONS SHALL DEMONSTRATE THAT THE SUBSTITUTED PRODUCT IS CAPABLE OF ACHIEVING THE PERTINENT EQUIVALENT PERFORMANCE VALUES (MINIMUM) OF THE SPECIFIED PRODUCT USING THE APPROPRIATE DESIGN PROCEDURE AND/OR STANDARD(S) AS REQ'D BY THE BUILDING CODE. PROVIDE CONTINUOUS SPECIAL INSPECTION FOR ALL MECHANICAL AND ADHESIVE ANCHORS PER THE APPLICABLE EVALUATION REPORT. CONTACT MANUFACTURER'S REPRESENTATIVE FOR THE INITIAL TRAINING AND INSTALLATION OF ANCHORS AND FOR PRODUCT RELATED QUESTIONS AND AVAILABILITY

1.1. CONCRETE ANCHORS

- A. MECHANICAL ANCHORS SHALL HAVE BEEN TESTED AND QUALIFIED FOR USE IN ACCORDANCE WITH ACI 355.2 AND ICC-ES AC193 FOR CRACKED AND UNCRACKED CONCRETE RECOGNIT PRE-APPROVED MECHANICAL ANCHORS INCLUDE: - SIMPSON STRONG-TIE "TITEN-HD" (ICC-ES ESR-2713) - SIMPSON STRONG-TIE "STRONG-BOLT 2" (ICC-ES ESR-3037)
- B. ADHESIVE ANCHORS SHALL HAVE BEEN TESTED AND QUALIFIED FOR USE IN ACCORDANCE WITH ACI 355.4 AND ICC-ES AC308 FOR CRACKED AND UNCRACKED CONCRETE EXCOGNITION. PRE-APPROVED ADHESIVE ANCHORS INCLUDE: - SIMPSON STRONG-TIE "SET-XP" (ICC-ES ESR-2508) - SIMPSON STRONG-TIE "AT-XP" (IAPMO-ES ER-0263)
- HILTI HIT HY150 INJECTION ADHESIVE - EPCON CERAMIC 6 EPOXY ADHESIVE SUPPLIED BY ITW PAMS TARED HEAD - POWER-FAST EPOXY INJECTION GEL SUPPLIED BY POWER SASTENING
- C. POWDER AND GAS-ACTUATED FASTENERS SHALL HAVE BLEN TESTED AND QUALIFIED FOR USE IN ACCORDANCE WITH ICC-ES AC70. PRE-APPROVED. DWD.R ACTUATED FASTENERS INCLUDE: SIMPSON STRONG-TIE "POWER-DRIVEN FASTEN RS" (CC-ES ESR-2138) - SIMPSON STRONG-TIE "GAS-ACTUATED FASTENERS" (ICC-ES ESR-2811)

2. MASONRY ANCHORS

- 2.1 ANCHORAGE TO SOLID-GROUTED COLCRE
 - A. MECHANICAL ANCHORS SHALL HAND BEEN TESTED AND QUALIFIED FOR USE IN ACCORDANCE WITH ICC-ES AC01 OR AC106. PRE-APPROVED MECHANICAL ANCHORS INCLUDE: - SIMPSON STRONG-TIE "TITEN HD" (ICC-ES ESR-1056)
- SIMPSON STRONG-TIE "STRON G-BOLT 2" (IAMPO-ES ER-0240)
 SIMPSON STRONG-TIE "VEDOE-ALL" (ICC-ES ESR-1396)

 B. ADHESIVE ANCHORS & VALL HAVE BEEN TESTED AND QUALIFIED FOR USE IN ACCORDANCE WITH ICC-ES AC58. PRE-APPROVED MECHANICAL ANCHORS INCLUDE: - SIMPSON STROM: TIE "AT-XP" (IAMPO-ES ER-0281)
- SIMPSON STAC IG-"E "SET-XP" (IAMPO-ES ER-0265) HILTI HIT HY 67 II JECTION ADHESIVE - EPCON CERAMIC 6 EPOXY ADHESIVE SUPPLIED BY ITW RAMSET/RED HEAD
- FAS EPOXY INJECTION GEL SUPPLIED BY POWERS FASTENING

- EPCON CERAMIC 6 EPOXY ADHESIVE SUPPLIED BY ITW RAMSET/RED HEAD

- POWER-FAST EPOXY INJECTION GEL SUPPLIED BY POWERS FASTENING

- ANCHORAGE TO HOW CONCRETE MASONRY:
- 3.1 ADM SIVE ANCHORS WITH SCREEN TUBES SHALL BE TESTED AND QUALIFIED IN ACCORDANCE WITH E AC58 OR AC60, AS APPROPRIATE. THE APPROPRIATE SCREEN TUBE SHALL BE USED AS RIO MMENDED BY THE ADHESIVE MANUFACTURER. PRE-APPROVED ADHESIVE ANCHORS WITH

TUBES INCLUDE: SIMPSON STRONG-TIE "SET" (ICC-ES ESR-1772) - SIMPSON STRONG-TIE "AT" (ICC-ES ESR-1958) - HILTI HIT HY150 INJECTION ADHESIVE

ALL DRILLED & EPOXIED 5/8" THREADED RODS SHALL MAINTAIN A MINIMUM EDGE DISTANCE OF 1 3/4" AND CLEAR SPACING OF 4" O.C. (MAX.)

CAST-IN-PLACE CONCRETE

- ALL CONCRETE HAS BEEN DESIGNED IN ACCORDANCE WITH ACI 318 AND SHALL BE CONSTRUCTED IN ACCORDANCE WITH ACI 301.
- 2. UNLESS NOTED OTHERWISE, ALL CONCRETE SHALL HAVE A 28 DAY COMPRESSIVE STRENGTH OF 3000 PSI. REFER TO ARCHITECTURAL DRAWINGS FOR MOLDS. GROVES, ORNAMENTS, CLIPS OR GROUNDS REQUIRED
- TO BE ENCASED IN CONCRETE AND FOR LOCATION OF FLOOR FINISHES AND SLAB DEPRESSIONS. 4. CONSTRUCTION JOINT LOCATIONS SHALL BE APPROVED BY THE STRUCTURAL ENGINEER. NO HORIZONTAL
- CONSTRUCTION JOINTS ARE PERMITTED EXCEPT THOSE SHOWN ON THE STRUCTURAL DRAWINGS. DEFECTIVE AREAS IN CONCRETE INCLUDING, BUT NOT LIMITED TO, HONEY-COMBING, SPALLS, AND CRACKS WITH WIDTHS EXCEEDING O.O1 INCH SHALL BE REPAIRED. EXTENT OF DEFECTIVE AREA TO BE DETERMINED BY THE STRUCTURAL ENGINEER.

- 1. ALL HEADERS, BEAMS, POSTS, ETC. HAVE BEEN DESIGNED TO SUPPORT ROOF FRAMING MEMBERS AS SHOWN ON ROOF FRAMING PLAN. IT IS THE RESPONSIBILITY OF THE TRUSS MFG. TO NOTIFY E.O.R. OF ANY DISCREPANCY & PROVIDE FINAL TRUSS LAYOUT TO E.O.R. FOR STRUCTURAL PLAN REVISION IF LAYOUT VARIES FROM THAT SHOWN ON THIS PLAN SET.
- 1.1. ALL DECK JOISTS HEREIN SHOWN AS 16" O.C. OR GREATER ARE INTENDED FOR 2 X 6 OR 5/4 X 6 WOOD DECKING. IT IS THE CONTRACTORS RESPONSIBILITY, IF USING COMPOSITE DECKING TO INSTALL DECK JOISTS @ 12" O.C. OR AS REQUIRED BY MANUFACTURERS SPECIFICATIONS.
- STRUCTURAL GLUED LAMINATED TIMBER SHALL BE PRODUCED IN ACCORDANCE WITH THE AMERICAN INSTITUTE OF TIMBER CONSTRUCTION (AITC), MINIMUM ALLOWABLE BENDING STRESS SHALL BE 2,400 PSI (DRY CONDITIONS).
- PROVIDE DRESSED SEASONED LUMBER, S4S, WITH A MAXIMUM MOISTURE CONTENT OF 19% AT TIME OF DRESSING AS LISTED BELOW.
- 3.1. INTERIOR AND EXTERIOR LOAD-BEARING WALLS:

SOUTHERN PINE (S.P.), NO. 2 GRADE

MANUFACTURERS RECOMMENDATIONS.

- SPRUCE PINE FUR (SPF) U.N.O. 3.2. LINTELS, FLOOR JOISTS AND BEAMS:
- 3.3. WOOD IN CONTACT WITH CONCRETE OR MASONRY SHALL BE FOUNDATION GRADE PRESSURE-TREATED. USE GALVANIZED NAILS IN PRESSURE-TREATED WOOD. THE PROTECTIVE COATING ON LIGHT GAUGE STEEL CONNECTIONS IN CONTACT w/ PRESSURE-TREATED WOOD SHALL BE IN ACCORDANCE WITH THE CONNECTOR
- 4. ENGINEERED LUMBER PRODUCTS
- 4.1. PARALLEL STRAND LUMBER (PSL) SHALL HAVE THE FOLLOWING MINIMUM ALLOWABLE STRESSES AND PROPERTIES:
- ALLOWABLE BENDING STRESS COMPRESSION PERPENDICULAR TO GRAIN FCL = 750 PSI COMPRESSION PARALLEL TO GRAIN = 2900 PSI HORIZONTAL SHEAR $F_{V} = 290 \, PSI$ MODULUS OF ELASTICITY E = 2,000,000 PSI

4.2. LAMINATED VENEER LUMBER (LVL) SHALL HAVE THE FOLLOWING MINU

- STRESSES AND PROPERTIES: ALLOWABLE BENDING STRESS = 2600 PSI COMPRESSION PERPENDICULAR TO GRAIN $F_{C^{\perp}} = 750 \text{ PS}$ COMPRESSION PARALLEL TO GRAIN HORIZONTAL SHEAR MODULUS OF ELASTICITY
- 4.3. LAMINATED STRAND LUMBER (LSL) SHALL HAVE THE FOLLOWING MINIMUM ALLOWABLE STRESSES AND PROPERTIES: ALLOWABLE BENDING STRESS COMPRESSION PERPENDICULAR TO G COMPRESSION PARALLEL TO GRAIN = 1835 PSI HORIZONTAL SHEAR $F_V = 425 \, PSI$ MODULUS OF ELASTICITY = 1,300,000 PSI
- 4.4. GLULAM BEAMS (GLU) SHALL H HEFOLLOWING MINIMUM ALLOWABLE STRESSES AND PROPERTIES: ALLOWABLE BENDING STRE = 3000 PSCOMPRESSION PERPE R TO GRAIN = 805 PSI TENSION PARALLEL TO GRAIN = 1350 PSI
- MODULUS OF ELASTICITY = 2,100,000 PSI 4.5. PRESERVED & ULAI BEAMS (GLU) SHALL HAVE THE FOLLOWING MINIMUM ALLOWABLE STRESSES AND PROJERTIES: ALLOW BLE BENDING STRESS = 2400 PSI

= 300 PSI

- RESSION PERPENDICULAR TO GRAIN $F_{C\perp} = 740 \text{ PSI}$ HORIZENTAL SHEAR $F_V = 300 \text{ PSI}$ VODUZUS OF ELASTICITY E = 1,800,000 PSSTEJCTURAL PANELS
- OOR PANELS SHALL BE CONSTRUCTED WITH TONGUE AND GROOVE APA RATED 3/4" PLYWOOD. FLOOR PANELS SHALL BE GLUED AND NAILED w/ 8d RING SHANK NAILS @4". O.C. AT PANEL EDGES AND AT 6" O.C. IN THE FIELD.
- 5.2. WALL PANELS SHALL BE CONSTRUCTED WITH APA RATED SHEATHING, SHEATHING SHALL BE ATTACHED WITH 8d COMMON NAILS @3" O.C. AT PANEL EDGES AND 6" O.C. IN THE FIELD. ALL PANEL EDGES SHALL BE BLOCKED.
- 5.3. ROOF PANELS SHALL BE CONSTRUCTED WITH APA RATED SHEATHING. SHEATHING SHALL BE ATTACHED WITH 8d RING SHANK NAILS @ 3" O.C. AT PANEL EDGES AND AT 6" O.C. IN THE FIELD. ALL PANEL EDGES SHALL BE BLOCKED OR ATTACHED WITH SIMPSON
- PSCA PANEL SHEATHING CLIPS. 5.4. NAIL HEADS SHALL NOT PENETRATE THE OUTER SURFACE OF SHEATHING.
- 6. FABRICATED WOOD TRUSSES

HORIZONTAL SHEAR

- 6.1. DESIGN OF WOOD TRUSSES SHALL BE THE SOLE RESPONSIBILITY OF THE CONTRACTOR. SUBMIT SHOP DRAWINGS, DESIGN LOAD DATA, AND SUPPORT REACTIONS SEALED BY AN ENGINEER LICENSED IN THE PROJECT STATE, REVIEW OF SHOP DRAWINGS SHALL BE FOR CONFORMANCE WITH THE CONTRACT DOCUMENTS WITH REGARD TO TRUSS CONFIGURATION, AND THE CONTRACTOR'S INTERPRETATION OF DESIGN LOADS AND DETAILS. SUCH REVIEW SHALL NOT RELIEVE THE CONTRACTOR OF THE FULL RESPONSIBILITY FOR THE DESIGN OF THE TRUSSES OR TRUSS CONNECTIONS NOT SPECIFICALLY DETAILED IN THE CONTRACT DOCUMENTS.
- 6.2. ERECTION AND BRACING OF PREFABRICATED WOOD TRUSSES SHALL BE IN CONFORMANCE WITH THE RECOMMENDATIONS OF THE TRUSS MANUFACTURER AND THE TRUSS PLATE INSTITUTE'S "BRACING WOOD TRUSSES: COMMENTARY AND RECOMMENDATIONS".
- 6.3. SECURE EACH COMMON ROOF TRUSS/RAFTER TO TOP PLATE WITH SIMPSON H-10 OR H-7 HURRICANE CLIP AT ALL BEARING POINTS. USE SIMPSON H-7 AT GIRDER TRUSSES. PROVIDE A MINIMUM OF TWO STUDS UNDER GIRDER TRUSS END BEARING. 6.4. TRUSSES ON SITE PRIOR TO INSTALLATION SHALL BE STORED IN A VERTICAL POSITION
- WITH SUPPORT POINTS PROVIDED AT FINAL BEARING POINTS AND BRACED TO AVOID 6.5. INSTALLATION OF ALL TRUSSES SHALL BE DONE USING A SPREADER BAR WITH A THREE
- POINT VERTICAL PICK AND CARE IS TO BE USED IN LIFTING TO MINIMIZE HORIZONTAL 6.6. IMPROPER HANDLING OF THE TRUSSES AS NOTED ABOVE AND IN THE SPECIFICATIONS
- SHALL MEAN REMOVAL OF THE TRUSSES FROM THE JOB SITE. 6.7. TRUSS TO TRUSS CONNECTIONS SHALL BE VERIFIED BY THE TRUSS DESIGNER.
- 6.8. EXPOSED TRUSSES SHALL BE DELIVERED TO THE JOB SITE UNBLEMISHED AND SUITABLE FOR FIELD PAINTING.
- 6.9. CONTRACTOR TO REFER TO "STANDARD FOR HURRICANE RESISTANT CONSTRUCTION SSTD 10-99 FOR FRAMING REQUIREMENTS OF WOOD FRAMED WALL SYSTEMS, TABLE 305C AND FIGURE 306D. 6.10. ALL FLOOR TRUSS DESIGN LOADS SHALL BE PER TRUSS MANUFACTURER. THE LOADS
- REFERENCED WITHIN THE FOLLOWING "STRUCTURAL LOADS" SECTION REPRESENTS THE LOADS USED FOR THE DESIGN OF STRUCTURAL MEMBERS SUPPORTING FLOOR AND ROOF TRUSSES.
- 7. CONNECTIONS
- 7.1. CONNECTIONS FOR STRUCTURAL TIMBER SHALL BE GALVANIZED STRONG TIE CONNECTORS BY THE SIMPSON COMPANY OR APPROVED EQUAL. CONNECTORS SHALL FOLLOW MANUF. CORROSION PROTECTION RECOMMENDATIONS.
- 7.2. THE NUMBER OF FASTENERS PER CONNECTION SHALL BE THE MAX. ALLOWED FOR THAT PARTICULAR FASTENER.

STRUCTURAL LOADS:

SUPERIMPOSED DEAD LOADS (RESIDENTIAL CONSTRUCTION) FLOOR

PORCH 10 PSF ROOF 15 PSF

SUPERIMPOSED LIVE LOADS (RESIDENTIAL CONSTRUCTION)

ATTICS w/ STORAGE ATTICS w/o STORAGE HABITABLE ATTICS & BEDROO ALL OTHER ROOMS DECKS FLOOR 40 PSF


ROOF WIND LOADS AS

ND SPEED 109 MPF THEAL CATEGORY OSURE CATEGORY INTERNAL PRESSURE COEFFICIENT 0.18 ± PACT GLASS WINDOWS & DOORS

MAIN WIND FRAME RESISTING SYSTEM (MWFRS)					
	AREA	INTERIOR ZONE	END ZONE		
	WALLS	38.23 PSF	47.79 PSF		
	ROOF	± 32.69 PSF	± 40.86 PSF		

COMPONENTS AND CLADDING ROOF PRESSURES (PSF)								
	ZONE			+ GCpi		- GCpi		
R	OOF (ZONE	1)		30.44			-54.66	
R	OOF (ZONE	2)	30.44			-75.42		
ROOF (ZONE 3)		30.44		-75.42				
		COMPON	ENTS AND	CLADDING '	WALL PRES	SURES (PS	F)	
	0 SF	- 10 SF	10 SF	- 30 SF	30 SF	- 60 SF	60 SF	- 100 SF
ZONE	+ GCpi	- GCpi	+ GCpi	- GCpi	+ GCpi	- GCpi	+ GCpi	- GCpi
4	40.82	-44.28	40.82	-44.28	37.91	-41.37	36.07	-39.53
5	40.82	-54.66	40.82	-54.66	37.91	-48.83	36.07	-45.15

NOTE: ALL PRESSURES SHOWN ARE BASED UPON ASD DESIGN, WITH A LOAD FACTOR OF 0.6.

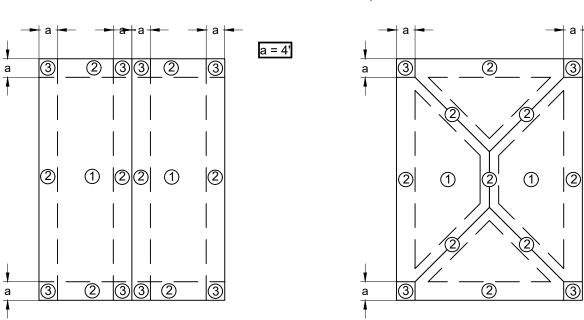

7°<Θ<=45°

HIPPED ROOF

CERTIFICATION

THE STRUCTURE SHOWN ON THESE PLANS IS DESIGNED IN ACCORDANCE WITH FLORIDA BUILDING CODE 8TH EDITION (2023).

E.O.R. = ENGINEER OF RECORD

N.T.S. = NOT TO SCALE

<u>ABBREVIATIONS</u> CONC. = CONCRETE WWM = WELDED WIRE MESH CONT. = CONTINUOUS CMU = CONCRETE MASONRY UNIT P.T. = PRESSURE TREATED N.T.S. = NOT TO SCALE BTW = BETWEEN SIM = SIMILAR

CONT. = CONTINUOUS

GABLED ROOF

BTM. = BOTTOM C.I.P. = CAST IN PLACE S.S. = STAINLESS STEEL TYP. = TYPICAL REQ'D = REQUIRED U.N.O. = UNLESS NOTED OTHERWISE LOC = LOCATION L.B.W. = LOAD BEARING WALL HCA = HEADED CONCRETE ANCHOR MFG. = MANUFACTURER

S	SHEARWALL/SHEATHING NAIL SCHEDULE (U.N.O.)					
WALLS	8d (0.131" x 2-1/2")	3" O.C. EDGE 6" O.C. FIELD				
ROOF	8d "RING SHANK" (0.131" X 2-1/2")	3" O.C. EDGE 6" O.C. FIELD				
TONG	JE & GROOVE SHEATHING, IF APPL	ICABLE (U.N.O.)				
WALLS	(2) 3" #9 DECK SREWS	EACH STUD CONN.				
ROOF	(2) 3" #9 DECK SREWS	EACH TRUSS/RAFTER CONN.				

877 North County Hwy 393 Santa Rosa Beach, FL 32459 850.267.0759 Phone 850.557.0076 Fax

www.dewberry.com

SOUTHEASTERN CONSULTING ENGINEERS, INC Southeastern Consulting Engineers, Inc. 120 North Highway 71 Wewahitchka, FL 32465 850.639.3860

四区



SCALE

REVISIONS

DRAWN BY APPROVED E CHECKED B

STRUCTURAL

PROJECT NO. 50171913

PER SECTION 471.003(2)(H), F.S., ALL MECHANICAL, ELECTRICAL, AND PLUMBING ARE EXEMPT FROM PROFESSIONAL ENGINEERING SERVICES FOR THIS PROJECT. IT IS THE RESPONSIBILITY OF THE CONTRACTOR TO PERMIT AND CONSTRUCT THE APPLICABLE SYSTEM IN ACCORDANCE WITH FLORIDA BUILDING CODE, LOCAL CODE REQUIREMENTS AND PROGRAMMATIC REQUIREMENTS. IT IS THE RESPONSIBILITY OF THE CONTRACTOR TO PERMIT THE PROJECT WITH ALL AUTHORITIES HAVING JURISDICTION (AHJ). INFORMATION SHOWN PROVIDES MINIMUM PROGRAMMATIC REQUIREMENTS AND ARE GENERAL IN NATURE. DRAWINGS ARE SCHEMATIC IN NATURE AND FINAL PERMITTING AND CONSTRUCTION OF THE SYSTEM IS THE RESPONSIBILITY OF THE CONTRACTOR. ALL EQUIPMENT AND PRODUCTS SHALL BE SELECTED BY THE CONTRACTOR. 2" KITCHEN SINK & DISHWASHER-FIRST FLOOR

GENERAL NOTES

PLUMBING NOTES:

- PLUMBING CONSTRUCTION DOCUMENTS SHALL BE SUBMITTED BY THE PLUMBING SUBCONTRACTOR FOR PERMITTING TO THE AUTHORITY HAVING JURISDICTION.
- PLUMBING CONTRACTOR SHALL BE LICENSED AND RESCONSIBLE TO MEET ALL APPLICABLE REQUIREMENTS OF THE FLORIDA BUILDING CODE AND THE LOCAL CODE REQUIREMENTS OF THE
- JURISDICTION WHERE THE PROJECT WILL BE LOCATED.


 ALL PLUMBING FIXTURES AND PIPING MATERIALS AND INSTALLATION SHALL CONFORM TO THE LOCAL
- PLUMBING CODES.
 INSULATE ALL PIPING AS REQUIRE BY THE FENRILA BUILDING CODE.
 USE WATER-CONSERVING FIXTURES MEETING THE FOLLOWING WATERSENSE REQUIREMENTS:
- TOILETS = 1.28 GPF SHOWER HEADS = 2.0 GPM

- b. SHOWER HEADS = 2.0 GPM
 c. KITCHEN FAUCETS = 2.0 GPM
 d. BATHROOM FAUCETS = 1K GPM
 e. WATER CLOSETS MUSICHANE A MINIMUM MAP RATING OF 600 GRAMS PER FLUSH.
 COORDINATE FIXTURES AND LOCATIONS WITH ARCHITECTURAL PLANS AND OWNER.
 PROVIDE SERVICE CONNECTED S TO THE LOCAL UTILITY THAT COMPLY WITH THE SERVICE AUTHORITY'S REQUIRED NTS
 COORDINATE HOT WATER NEATER LOCATION AND PROVIDE PLASTIC DRAIN/DRIP PAN WITH DRAIN TO THE BUILDING EXTERIOR IN A CONSPICUOUS LOCATION. WATER HEATER SHALL BE MINIMUM 50 GALLON CAPACITY AND ENERGY STAR LISTED.
 COORDINAY E HOSE BUS LOCATIONS (MINIMUM OF 2 EXTERIOR HOSE BIBBS SHALL BE PROVIDED). PROVIDE "10-DRA" SUPPLY/DRAIN AT WASHING MACHINE.
 PROVIDE ALCESS PANELS TO TUB/SHOWER PLUMBING LINES/VALVE.
 PERFORM ALL REQUIRED TESTS PRIOR TO INSTALLING PIPE INSULATION, BACKFILLING, OR INSTALLING DRYW ILL.

- PRO IDE ALL CLEAN-OUTS, EXPANSION TANKS, VACUUM BREAKERS, AND OTHER MISCELLANEOUS COMPLINENTS REQUIRED FOR A COMPLETE AND FUNCTIONAL SYSTEM WHETHER SHOWN ON DRIVINGS OR NOT.
- POVIDE SHUT-OFF VALVES TO ALL FIXTURES.
- ALL PENETRATIONS THROUGH THE ROOF SHALL BE FLASHED AND SEALED USING PREFORMED

AND GROUPS SHALL BE VENTED IN ACCORDANCE WITH THE CURRENT VERSION OF THE FLORIDA

- PLUMBING SUBCONTRACTOR SHALL PROVIDE AND INSTALL DRAIN PIPING FOR ALL HVAC EQUIPMENT. DISCHARGE TO GRADE. DO NOT CONNECT TO SANITARY PIPING. ALL DRAIN LINES SHALL HAVE WATER SEAL TRAPS AS REQUIRED BY CODE. ALL PLUMBING FIXTURES
- ALL SANITARY SEWER PIPING SHALL BE SOLID-CORE, SCHEDULE 40 PVC DWV PIPE WITH APPROPRIATE FITTINGS. MINIMUM SLOPE OF THE SANITARY SEWER PIPING SHALL BE MAINTAINED PER CODE. AVOID ROUTING PIPE THROUGH BUILDING FOOTINGS. WHERE CONFLICTS ARE UNAVOIDABLE, ROUTE PIPING
- A MINIMUM OF 12" BELOW FOOTING. HOT- AND COLD-WATER SUPPLY PIPING SHALL BE CPVC WITH APPROVED FITTINGS. PLUMBING CONSTRUCTION DRAWINGS SHALL INDICATE THE LOCATION OF CLEAN-OUTS AND
- CONNECTIONS TO EXISTING UTILITIES INCLUDING WATER AND SANITARY SEWER FOR REVIEW BY THE AUTHORITY HAVING JURISDICTION.
- KITCHEN SINK TO HAVE ENERGY STAR GARBAGE DISPOSAL. PLUMBER SHALL COORDINATE WITH
- ELECTRICIAN FOR INSTALLATION.
- HOT & COLD WATER PIPING AND SANITARY DRAIN TRAPS SHALL NOT BE INSTALLED IN ANY LOCATION SUBJECT TO FREEZING.

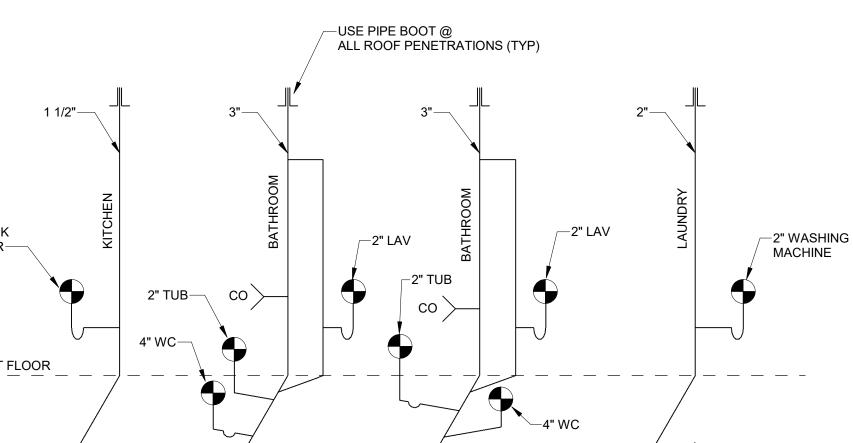

RISER DIAGRAM

4" → SLOPE

NOT TO SCALE

Dewberry

Dewberry Engineers Inc. 877 North County Hwy 393 Santa Rosa Beach, FL 32459 850.267.0759 Phone 850.557.0076 Fax www.dewberry.com



SEAL

SCALE

As indicated

No.	Description	Date
REVISIO	NS	
DRAWN BY		ETC
APPRO	VED BY	CLS

CHECKED BY

GENERAL INFORMATION 3BR WIDE

PROJECT NO.

P0.1

50171913

GENERAL NOTES

HVAC CONSTRUCTION DOCUMENTS SHALL BE SUBMITTED BY THE HVAC SUBCONTRACTOR FOR PERMITTING TO THE AUTHORITY HAVING JURISDICTION.

HVAC CONTRACTOR SHALL BE LICENSED AND RESPONSIBLE TO MEET ALL APPLICABLE REQUIREMENTS OF THE FLORIDA BUILDING CODE AND THE LOCAL CODE REQUIREMENTS OF THE JURISDICTION WHERE THE PROJECT WILL BE

THE HVAC DRAWINGS ARE SCHEMATIC IN NATURE. THE HVAC CONTRACTOR SHALL PROVIDE ALL EQUIPMENT AND COMPONENTS REQUIRED FOR A COMPLETE AND FUNCTIONAL SYSTEM WHETHER SHOWN ON THE DRAWINGS OR NOT. THESE COMPONENTS MAY INCLUDE, BUT SHALL TO BE LIMITED TO:

ALL AIR CONDITIONING EQUIPMENT **EXHAUST FANS** DUCTWORK INCLUDING SUPPLY RETURN **EXHAUST** VENTILATION AIR DISTRIBUTION DEVICES INCLUDING:

1. SUPPLY DIFFUSERS AND REGISTERS RETURN GRILLES DAMPERS

AIR FILTRATION (MERV 8 MINIMUM)
THERMOSTATS, IMERS, AND WIRING
EQUIPMENT SL. PORTS, HANGERS, AND BRACING

CONTENSATE DRAIN PANS, OVERFLOW SWITCHES, AND PIPING CONSTRUCTION DRAWINGS SHALL BE BASED ON THE LOCATION AND ORIENTATION OF THE PROPOSED SITE. HVAC SYSTEM SHALL BE SIZED BASED ON ACCA MANUAL J AND S, LATEST EDITION. CONTRACTOR SHALL PROVIDE

CALVILLION FOR EACH SITE. NITS SHALL BE MINIMUM OF 16 SEER.

LOUVER

ALL DUCTS AND PLENUMS SHALL BE MADE AIR TIGHT. SEAL ALL DUCT SEAMS USING TAPE AND MASTIC OVER JOINTS. NSTRUCT AND INSTALL DUCTWORK IN COMPLIANCE WITH THE FLORIDA BUILDING CODE, LATEST EDITION. MAXIMUM DUCT LEAKAGE SHALL NOT EXCEED 5% OF RATED AIFLOW, OR AS REQUIRED BY LOCAL CODES. PROTECT OPEN DUCTS DURING CONSTRUCTION TO MINIMIZE DUST AND DEBRIS USING BLUE MAX OR EQUAL DUCT

CONSTRUCT DUCTWORK FROM RIGID DUCT BOARD AND BRANCHES FROM FLEX DUCT TO THE LATEST SMACNA REQUIREMENTS FOR THE PRESSURE CLASS REQUIRED. MAXIMUM LENGTH OF FLEX DUCT SHALL BE 5'. THE HVAC CONTRACTOR SHALL DESIGN THE DUCT SYSTEM BASED ON ACCA MANUAL D, LATEST EDITION. INSULATE DUCTWORK AS REQUIRED BY FLORIDA BUILDING CODE BUT NOT LESS THAN R-6.

FLEXIBLE DUCTS SHALL BE EXTENDED FULLY. EXCESS DUCT MATERIAL SHALL BE LIMITED TO LESS THAN 5%. INSTALL FLEXIBLE DUCT PER MANUFACTURER'S RECOMMENDATIONS INCLUDING JOINING, SEALING, LIMITATIONS OF SAG, AND SUPPORTING.

INSTALL BALANCING DAMPERS AT EACH DUCT TAKE-OFF.

INSTALL FIRE AND SMOKE DAMPERS WHERE REQUIRED BY LOCAL CODES AND ASSEMBLY PENETRATIONS.

INSTALL SMOKE DETECTORS WHERE REQUIRED BY LOCAL CODES.

CONDENSATE DISPOSAL:

PLUMBING SUBCONTRACTOR SHALL PROVIDE A MEANS OF CONDENSATE DISPOSAL FOR EACH PIECE OF HVAC EQUIPMENT CONTAINING AN EVAPORATOR COIL.

CONDENSATE DISPOSAL SYSTEM SHALL BE DESIGNED AND INSTALLED IN ACCORDANCE WITH THE FLORIDA BUILDING CODE AND LOCAL CODES. PRIMARY AND SECONDARY CONDENSATE PIPING SHALL BE SCHEDULE 40 PVC.

PRIMARY CONDENSATE PIPING LOCATED WITHIN THE BUILDING ENVELOPE SHALL BE INSULATED USING 3/4" CLOSED

ALL CONDENSATE DISPOSAL PIPING SHALL BE TESTED DURING HVAC EQUIPMENT STARTUP.

SPLIT-SYSTEM HEAT PUMP EQUIPMENT:

HEAT PUMP AND AIR-HANDLING UNIT SHALL BE INSTALLED IN ACCORDANCE WITH THE FLORIDA BUILDING CODE AND

HEAT PUMP, AT A MINIMUM, SHALL BE LOCATED 2' ABOVE THE 100-YEAR FLOOD LEVEL AND SHALL BE SUPPORTED AND TIED DOWN AS REQUIRED BY THE FLORIDA BUILDING CODE USING APPROVED HURRICANE STRAPS.

THE MANUFACTURER'S RECOMMENDED CLEARANCES SHALL BE MAINTAINED ON ALL SIDES OF HEAT PUMP AND AIR-HANDLING UNITS.

HEAT PUMP AND AIR-HANDLING UNITS SHALL BE INSTALLED PER THE MANUFACTURER'S RECOMMENDATIONS AND IN COMPLIANCE WITH ALL EPA AND LOCAL REQUIREMENTS.

EQUIPMENT ACCESS SHALL NOT BE REDUCED BY REFRIGERANT PIPING, CONDENSATE DRAINS, OR OTHER

VENTILATION AIR AND EXHAUST AIR SYSTEMS:

EXHAUST DUCTS FOR BATHROOMS, POWDER ROOMS, AND KITCHEN HOODS SHALL TERMINATE AT THE BUILDING

EXTERIOR USING APPROVED ROOF CAPS, SIDEWALL CAPS, OR SOFFIT VENTS. TOILET EXHAUST FANS SHALL BE FURNISHED WITH BACKDRAFT DAMPERS.

TOILET EXHAUST FANS SHALL BE CONTROLLED BY MANUALLY OPERATED TIMERS.

DRYER EXHAUST DUCT SHALL BE ROUTED TO THE BUILDING EXTERIOR PER THE FLORIDA BUILDING CODE AND MANUFACTURER RECOMMENDATIONS. INSTALL BOOSTER FAN AS REQUIRED AND AS ALLOWED BY CODE. VENTILATION AIR DUCT SHALL BE CONNECTED TO THE RETURN AIR PLENUM.

VENTILATION AIR DUCT SHALL INCLUDE A MANUAL VOLUME DAMPER AND A NORMALLY CLOSED ISOLATION DAMPER

THE VENTILATION ISOLATION DAMPER SHALL BE WIRED TO OPEN WHENEVER THE ASSOCIATED AHU IS TURNED ON. VENTILATION AIR INTAKE SHALL BE LOCATED IN ACCORDANCE WITH THE FLORIDA BUILDING CODE, AND SHALL BE A MINIMUM OF 10 FEET FROM EXHAUST TERMINATIONS, A MINIMUM OF 10 FEET FROM PLUMBING VENTS, A MINIMUM OF 3 FEET FROM OPERABLE WINDOWS AND DOORS, AND A MINIMUM OF 3 FEET FROM PROPERTY LINES.

AIR HANDLING UNIT SCHEDULE						
				AUX HEATERS		

		ERVED MODEL SIZE EXT SP in Wg FAN TYPE V/PH/HZ				AUX HEATERS			
MARK	AREA SERVED			V/PH/HZ	STAGES	V/PH/HZ	REMARKS		
AHU-1	ENTIRE HOUSE	SEE REMARKS	-	FC	230/1/60	1	230/1/60	1,2,3	

- 1. MODEL TO BE SELECTED BY CONTRACTOR BASED ON ACCA MANUAL J CALCULATIONS.
- 2. PROVIDE SEVEN DAY PROGRAMMABLE THERMOSTAT, MERV 8 FILTER, AND ELECTRIC RESISTANCE HEAT.

3. MODEL SIZE TO BE BASED ON MANUAL J CALCULATION.

EXHAUST FAN SCHEDULE							
MARK	TYPE	CFM	SP in Wg	DRIVE	VOLTS/PH/HZ	REMARKS	
EF-1	CEILING	50	0.25	DIRECT	115/1/60	1,2,3,4	

- MODEL TO BE SELECTED BY CONTRACTOR.
- 2. PROVIDE BACKDRAFT DAMPER, INLET GRILLE, SPEED CONTROLLER, AND DISCHARGE WALL CAP OR ROOF JACK.
- WIRE TO WALL SWITCH FOR MANUAL CONTROL.
- 4. PROVIDE EXHAUST FAN WITH MANUALLY OPERATED TIMER.

HEAT PUMP SCHEDULE						
MARK	NOMINAL TONS	SYSTEM SERVED	V/PH/HZ	REMARKS		
HP-1	SEE REMARKS	AHU-1	208/230/1/60	1,2,3		

REMARKS:

- 1. MODEL TO BE SELECTED BY CONTRACTOR.
- 2. UNIT SHALL BE MINIMUM 16 SEER.
- 2. REQUIRED NOMINAL TONS FOR HEAT PUMP MUST MATCH THAT FOR AIR HANDLER UNIT.



Dewberry Engineers Inc. 877 North County Hwy 393 Santa Rosa Beach, FL 32459 850.267.0759 Phone 850.557.0076 Fax www.dewberry.com



SCALE

As indicated

1		


Description

REVISIONS		
DRAWN BY		ETO
APPROVED E	BY	CLS
CHECKED BY	,	CLS
DATE		

GENERAL INFORMATION 3BR WIDE

PROJECT NO. 50171913

M0.1

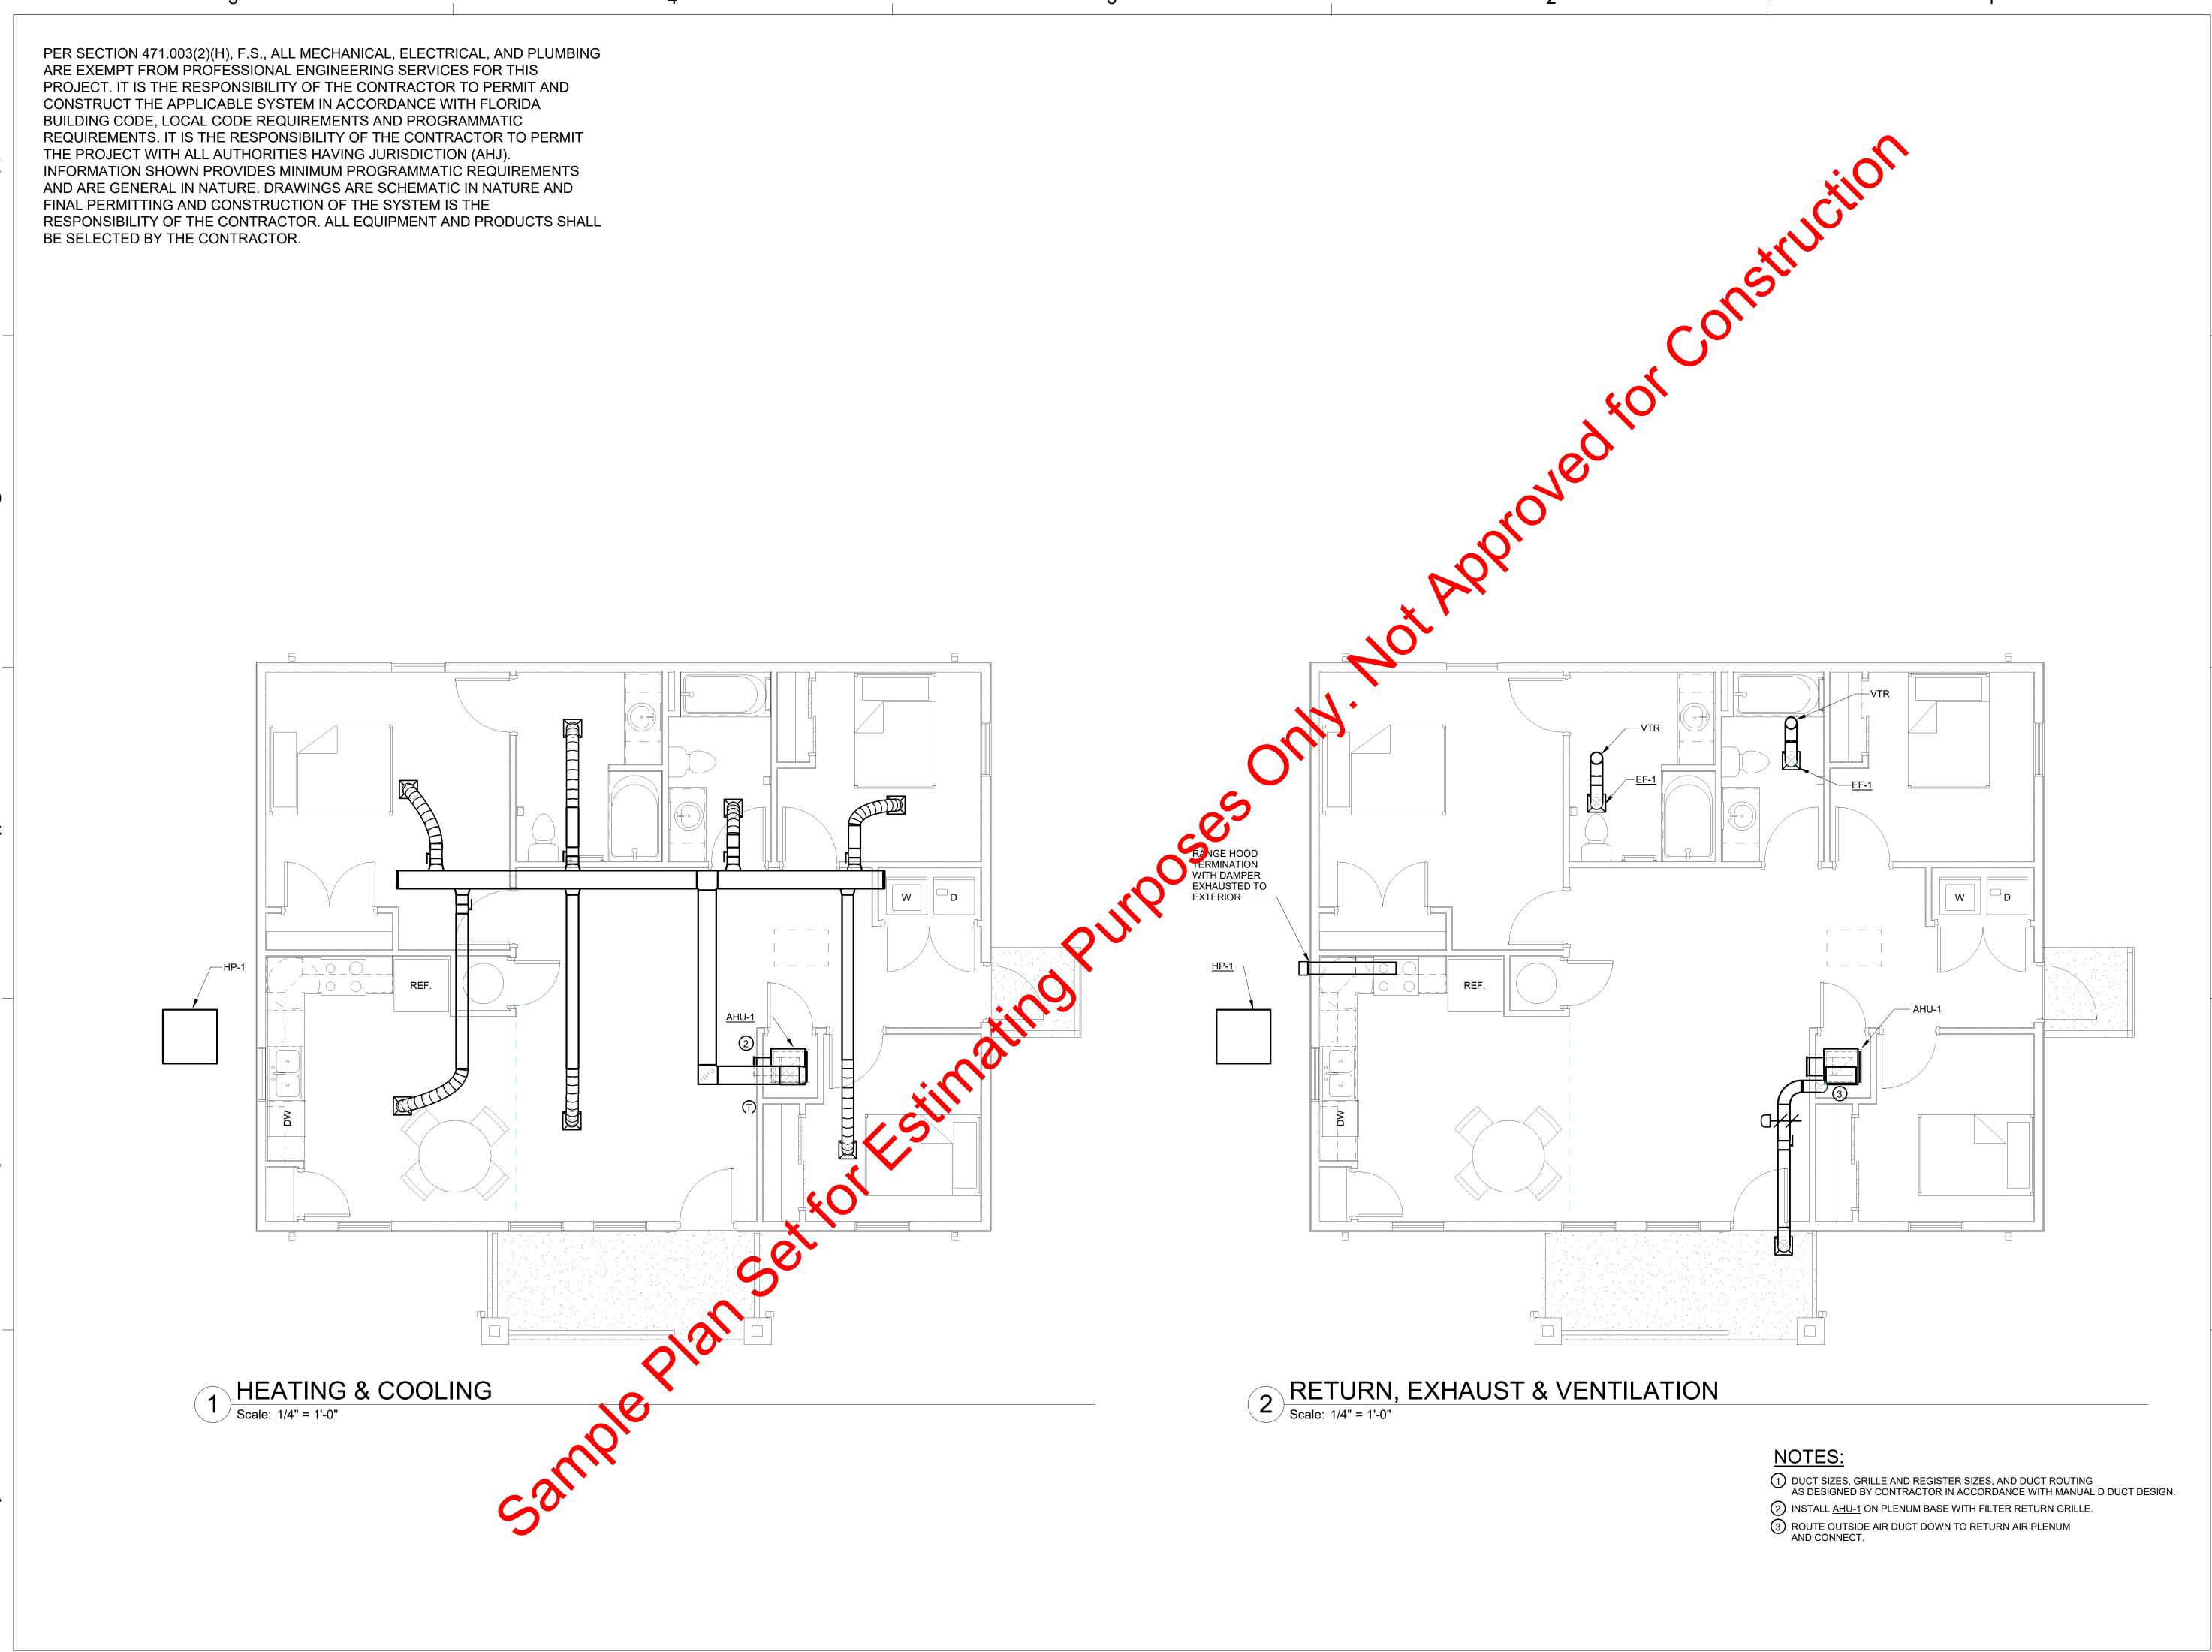

Dewberry Engineers Inc. 877 North County Hwy 393 Santa Rosa Beach, FL 32459 850.267.0759 Phone 850.557.0076 Fax www.dewberry.com

Rebuild Florida

SEAL

SCALE

1/4" = 1'-0"

No. Description Date

REVISIONS

DRAWN BY ETO

DRAWN BY ETO
APPROVED BY CLS
CHECKED BY CLS
DATE

TITLE

FLOOR PLANS 3BR WIDE


PROJECT NO.

M1.0

50171913


CONDUIT RUN CONCEALED ABOVE CEILINGS OR IN WALLS

LIGHT FIXTURE SCHEDULE							
TYPE	LAMP	CCT	NOTES				
Α	INTEGRATED LED	3000K	CEILING FAN WITH LIGHT, ENERGY STAR QUALIFIED				
В	INTEGRATED LED	3000K	SURFACE-MOUNTED KITCHEN FIXTURE, ENERGY STAR QUALIFIED				
С	LED	3000K	PENDANT,, ENERGY STAR QUALIFIED				
D	LED	3000K	BATHROOM VANITY, 2', ENERGY STAR QUALIFIED				
Е	INTEGRATED LED	3000K	WET-LISTED, NON-CONDUCTIVE, SHOWER DOWNLIGHT, ENERGY STAR QUALIFIED				
F	INTEGRATED LED	3000K	2' CLOSET LIGHT, ENERGY STAR QUALIFIED				
G	LED	3000K	KICHLER COSTAL, EXTER WALL-MOUNT, WET-LISTED OR EQUAL, ENERGY STAR QUALIFIED				

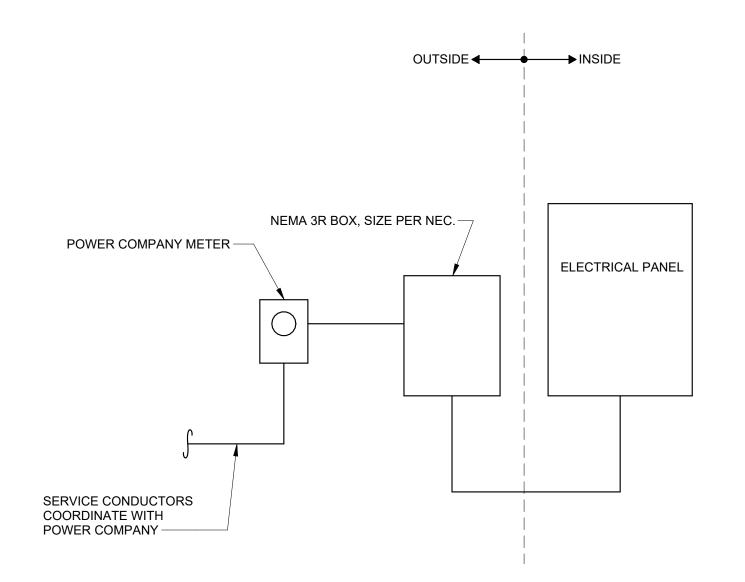

GENERATOR PRE-WIRE DIAGRAM (NOTE 24) NOT TO SCALE

3 BR WIDE

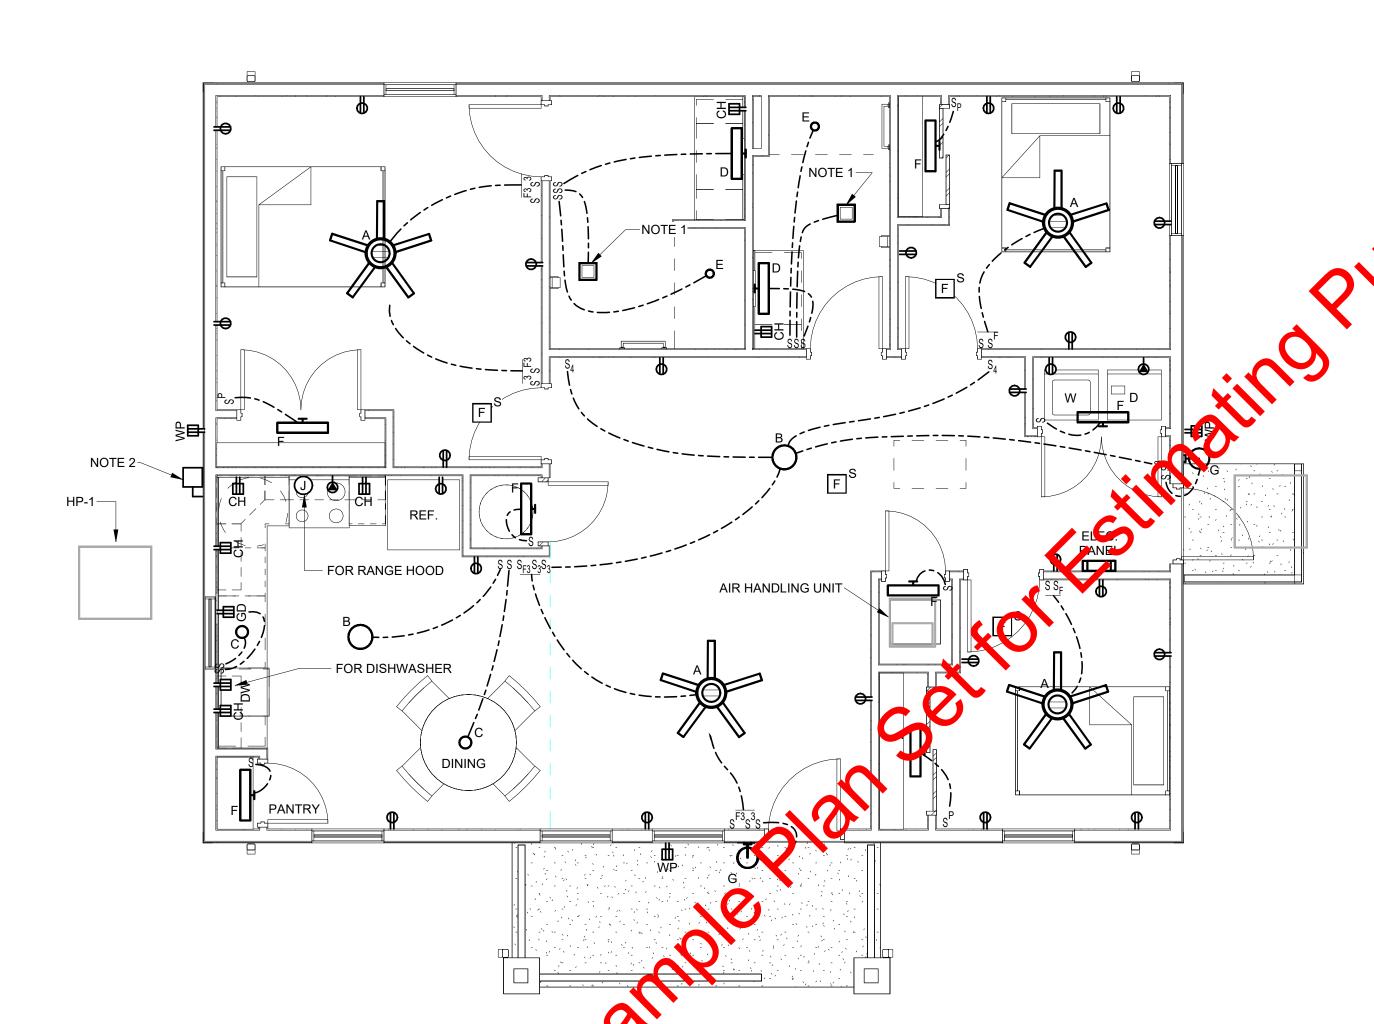

ELECTRICAL LEGEND

JUNCTION BOX

SAFETY SWITCH, (NEMA 1 INDOORS, NEMA 3R OUTDOORS)

RECEPTACLE, DUPLEX, NEMA 5-20R

RECEPTACLE, DUPLEX, NEMA 5-20R, GFI, WP INDICATES WEATHERPROOF, CH INDICATES COUNTER HEIGHT, GD INDICATES UNDER THE SINK FOR GARBAGE DISPOSAL

RECEPTACLE, SPECIAL

SWITCH

S'
SWITCH, 3/W

S'
SWITCH, 4/W

S'
SWITCH, FAN
S'
SWITCH WITH PILOT LIGHT

LIGHT FIXTURE, WALL MOUNTED

TIXTORE, SORI ACE MICORTED OR DOWNLIGHT

EXHAUST FAN WITH INTEGRAL LIGHT FIXTURE

CEILING FAN WITH INTEGRAL LIGHT FIXTURE

SMOKE & CARBON MONOXIDE DETECTOR, CEILING

NOTES (SHEET NO. E1.0)

- 1. COMBINATION LIGHT / EXHAUST FAN FIXTURE TO BE ENERGY STAR COMPLIANT. COORDINATE WITH MECHANICAL CONTRACTOR.
- 2. INSTALL (1) 220 DISCONNECT. MAINTAIN A 3 FT CLEARANCE_IN FRONT OF DISCONNECT

ELECTRICAL GENERAL NOTES

- 1. ELECTRICAL CONTRACTOR SHALL SIZE STRUCE, CONDUCTORS, FUSES, BREAKERS, AND SWITCHES IN ACCORDANCE WITH LOCAL BUILDING CODE, AN ELECTRICAL LOAD CALCULATION WILL BE REQUIRED FOR SERVICE SIZING.
- 2. PROVIDE SERVICE ENTRANCE CROUNDING IN ACCORDANCE WITH LOCAL BUILDING CODE.
- 3. ELECTRICAL CONTRACTOR SHALL COORDINATE WITH POWER COMPANY TO FULFILL REQUIREMENTS IN ESTABLISHING SERVICE. CONTRACTOR RESPONSIBLE FOR ALL ASSOCIATED FEES.
- 4. ALL WIRING SHALL E COPPER WITH ONE EXCEPTION ONLY. THE SERVICE ENTERANCE CONDUCTORS MAY USE COPPER OR ALL MID UM (SE OR USE). OTHERWISE, NO ALUMINUM WIRING SHALL BE USED.
- 5. SMOKE DETECTORS SHOWN SHALL BE COMBINATION SMOKE/CARBON MONOXIDE ALARMS. AND BE APPROVED AND LISTED IN AGCORDANCE WITH UL 217 AND 2034. THEY SHALL BE HARD WIRED WITH BATTERY BACK-UP. ALL DETECTORS WITHIN A UNIT SHALL BE INTERCONNECTED SUCH THAT ALL ALARM UPON ACTIVATION OF A SINGLED STECTOR.
- 6. LIGHT FIXTURES AND CEILING FANS SHALL BE ENERGY STAR QUALIFIED.
- PROVIDE ARC FAULT CIRCUIT INTERRUPTER (AFCI) PROTECTION WHERE REQUIRED BY CODE. PREFERRED COMPLIANCE PATH IS PROTECTION AT THE BRANCH CIRCUIT BREAKER LEVEL.

COORDINATION WITH OTHER TRADES: EXECUTE THE WORK IN FULL COOPERATION WITH OTHER CONSTRUCTION TRADES. PRIOR TO STARTING WORK, EXAMINE A COMPLETE SET OF CONSTRUCTION DOCUMENTS FOR ALL TRADES TO VERIFY COORDINATION, CHECK FOR INTERFERENCES, AND DETERMINE POINTS OF CONNECTIONS FOR EQUIPMENT. DUE TO STRUCTURAL CONDITIONS, MECHANICAL DUCT OR PIPING INTERFERENCE, OR OTHER REASONS, THE CONTRACTOR MAY DESIRE TO INSTALL THE WORK IN AN ALTERNATE MANNER FROM THAT SHOWN. SUCH CHANGES SHALL BE PRESENTED TO THE OWNER'S REPRESENTATIVE FOR APPROVAL BEFORE PROCEEDING.

- PROVIDE DATA (CAT-6) AND TELEVISION (RG-6 SHIELDED) RECEPTACLES IN ALL BEDROOMS AND (1) IN LIVING ROOM. PROVIDE ALL TERMINATIONS AND COVER PLATES TO MATCH POWER RECEPTACLE COVER PLATES.
- 0. LOCATIONS WHERE CONDUITS PENETRATE FIRE-RATED WALLS, FLOORS, OR CEILINGS SHALL BE FIREPROOFED USING A UL-LISTED METHOD TO MAINTAIN THE EXISTING RATING.
- 1. COORDINATE THE MOUNTING HEIGHT AND LOCATIONS OF THE ELECTRICAL DEVICES WITH ARCHITECTURAL ELEVATIONS AND GENERAL TRADES CONTRACTOR PRIOR TO ROUGH-IN. RECEPTACLES LOCATED WITHIN SIX (6) FEET OF SINK SHALL BE GROUND FAULT CIRCUIT INTERRUPTER (GFCI) TYPE RECEPTACLES. RECEPTACLES NOT READILY ACCESSIBLE THAT REQUIRE GFCI PROTECTION SHALL BE SO AT THE CIRCUIT BREAKER.
- 12. COORDINATE LOCATION OF CONDUITS, OUTLETS AND JUNCTION BOXES WITH MECHANICAL EQUIPMENT SO THAT OUTLETS AND JUNCTION BOXES ARE ACCESSIBLE FOR SERVICING AND HVAC DUCTWORK CAN BE CONNECTED DIRECTLY TO DIFFUSERS.
- 13. PERFORM ALL WORK IN ACCORDANCE WITH 2020 NATIONAL ELECTRICAL CODE (NEC) (OR WHICHEVER IS LATEST FLORIDA-ADOPTED EDITION OF THE NEC) AND ALL APPLICABLE LOCAL CODES.
- 14. FOR RECORD DRAWING REQUIREMENTS, REFER TO THE GENERAL CONDITIONS. MAINTAIN A DEDICATED SET OF DRAWINGS ON THE JOBSITE AND MARK ALL VARIATIONS TAKEN TO THE CONTRACT DRAWINGS. SEE PLANS FOR SUGGESTED LOCATIONS.
- 15. ALL ELECTRICAL EQUIPMENT SHALL BE INSTALLED SUCH THAT PROPER WORKING CLEARANCES ARE
- 16. COORDINATE WITH MECHANICAL TO PROVIDE APPROPRIATE CIRCUITS FOR HVAC AND PLUMBING EQUIPMENT. PROVIDE LOCAL DISCONNECT FOR EACH PIECE OF EQUIPMENT AND ENSURE WORKING CLEARANCE TO DISCONNECT IS MAINTAINED.
- 17. ALL WORK SHALL MEET APPLICABLE REQUIREMENTS OF THE FLORIDA RESIDENTIAL CODE 2023 EDITION (OR MOST RECENT) AND CHAPTER 4 [RE] RESIDENTIAL ENERGY EFFICIENCY OF FBC, ENERGY CONSERVATION 2023 (OR MOST RECENT)
- 18. ALL CONSTRUCTION WORK SHALL BE IN COMPLIANCE WITH ALL LOCAL CITY, COUNTY, STATE OF FLORIDA AND FEDERAL CODES. THE CONTRACTOR SHALL GIVE ALL NOTICES AND COMPLY WITH ALL LAWS, ORDINANCES, RULES, REGULATIONS, AND LAWFUL ORDERS OF ANY PUBLIC AUTHORITY BEARING PERFORMANCE OF THE
- 19. COMBINATION SMOKE /CARBON MONOXIDE DETECTORS SHALL BE PROVIDED IN AND OUTSIDE ALL SLEEPING AREAS. SEE PLANS FOR SUGGESTED LOCATIONS.
- 20. CONTRACTOR TO COORDINATE ALL UTILITIES INSTALLATION AND CONNECTION WITH LOCAL UTILITY COMPANY. AVOID ROUTING CONDUIT THROUGH BUILDING FOOTINGS. WHERE CONFLICTS ARE UNAVOIDABLE, ROUTE CONDUIT AT A MINIMUM OF 12" BELOW FOOTING.
- 21. ALL PENETRATIONS THROUGH FIRE RATED WALLS ARE TO BE SEALED WITH CODE APPROVED FIRESTOPPING
- 22. CONTRACTOR SHALL PROVIDE ALL ELECTRICAL FIXTURES, HARDWARE, AND ACCESSORIES IN A CONSISTENT
- CONTRACTOR SHALL PROVIDE ELECTRICAL LOAD CALCULATIONS AND ANY ADDITIONAL ELECTRICAL INFORMATION REQUESTED BY PERMIT DEPARTMENT NOT SHOWN IN DRAWINGS.
- 24. CONTRACTOR SHALL WIRE SERVICE CONDUCTORS THROUGH A JUNCTION BOX. THE INTENT IS THAT IF A FUTURE HOMEOWNER DESIRES TO INSTALL A BACKUP GENERATOR, THEY COULD REPLACE THE BOX WITH A SERVICE ENTRANCE AUTOMATIC TRANSFER SWITCH. PROVIDE CONTINUOUS SERVICE ENTRANCE CONDUCTORS THROUGH THE BOX WITH EXTRA LENGTH TO FACILITATE FUTURE CONNECTION. COORDINATE LOCATION BOX AND METER BASE WITH THE POWER COMPANY.

PER SECTION 471.003(2)(H), F.S., ALL MECHANICAL, ELECTRICAL, AND PLUMBING ARE EXEMPT FROM PROFESSIONAL ENGINEERING SERVICES FOR THIS PROJECT. IT IS THE RESPONSIBILITY OF THE CONTRACTOR TO PERMIT AND CONSTRUCT THE APPLICABLE SYSTEM IN ACCORDANCE WITH FLORIDA BUILDING CODE, LOCAL CODE REQUIREMENTS AND PROGRAMMATIC REQUIREMENTS. IT IS THE RESPONSIBILITY OF THE CONTRACTOR TO PERMIT THE PROJECT WITH ALL AUTHORITIES HAVING JURISDICTION (AHJ). INFORMATION SHOWN PROVIDES MINIMUM PROGRAMMATIC REQUIREMENTS AND ARE GENERAL IN NATURE. DRAWINGS ARE SCHEMATIC IN NATURE AND FINAL PERMITTING AND CONSTRUCTION OF THE SYSTEM IS THE RESPONSIBILITY OF THE CONTRACTOR. ALL EQUIPMENT AND PRODUCTS SHALL BE SELECTED BY THE CONTRACTOR.




www.dewberry.com



SEAL

SCALE

As indicated

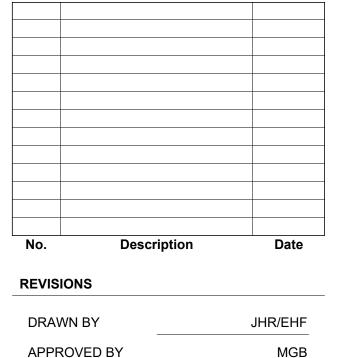

CHECKED BY MG

DATE

TITLE

ELECTRICAL PLAN 3 BR WIDE

PROJECT NO.

F1.0

50171913

REBUILD FLORIDA - HURRICANE HOUSING REPAIR AND REPLACEMENT

ADDRESS, CITY COUNTY, FLORIDA

FL-HI22-XXXXXX

4 BEDROOM / 2 BATH WIDE SLAB

PROJECT MANAGER

Dewberry Engineers Inc. 877 North County Hwy 393 Santa Rosa Beach, FL 32459 850.267.0759

ARCHITECTURAL

Dewberry Architects Inc.

Engineers, Inc.


STRUCTURAL

Hunter Baumgardner, PE Southeastern Consulting







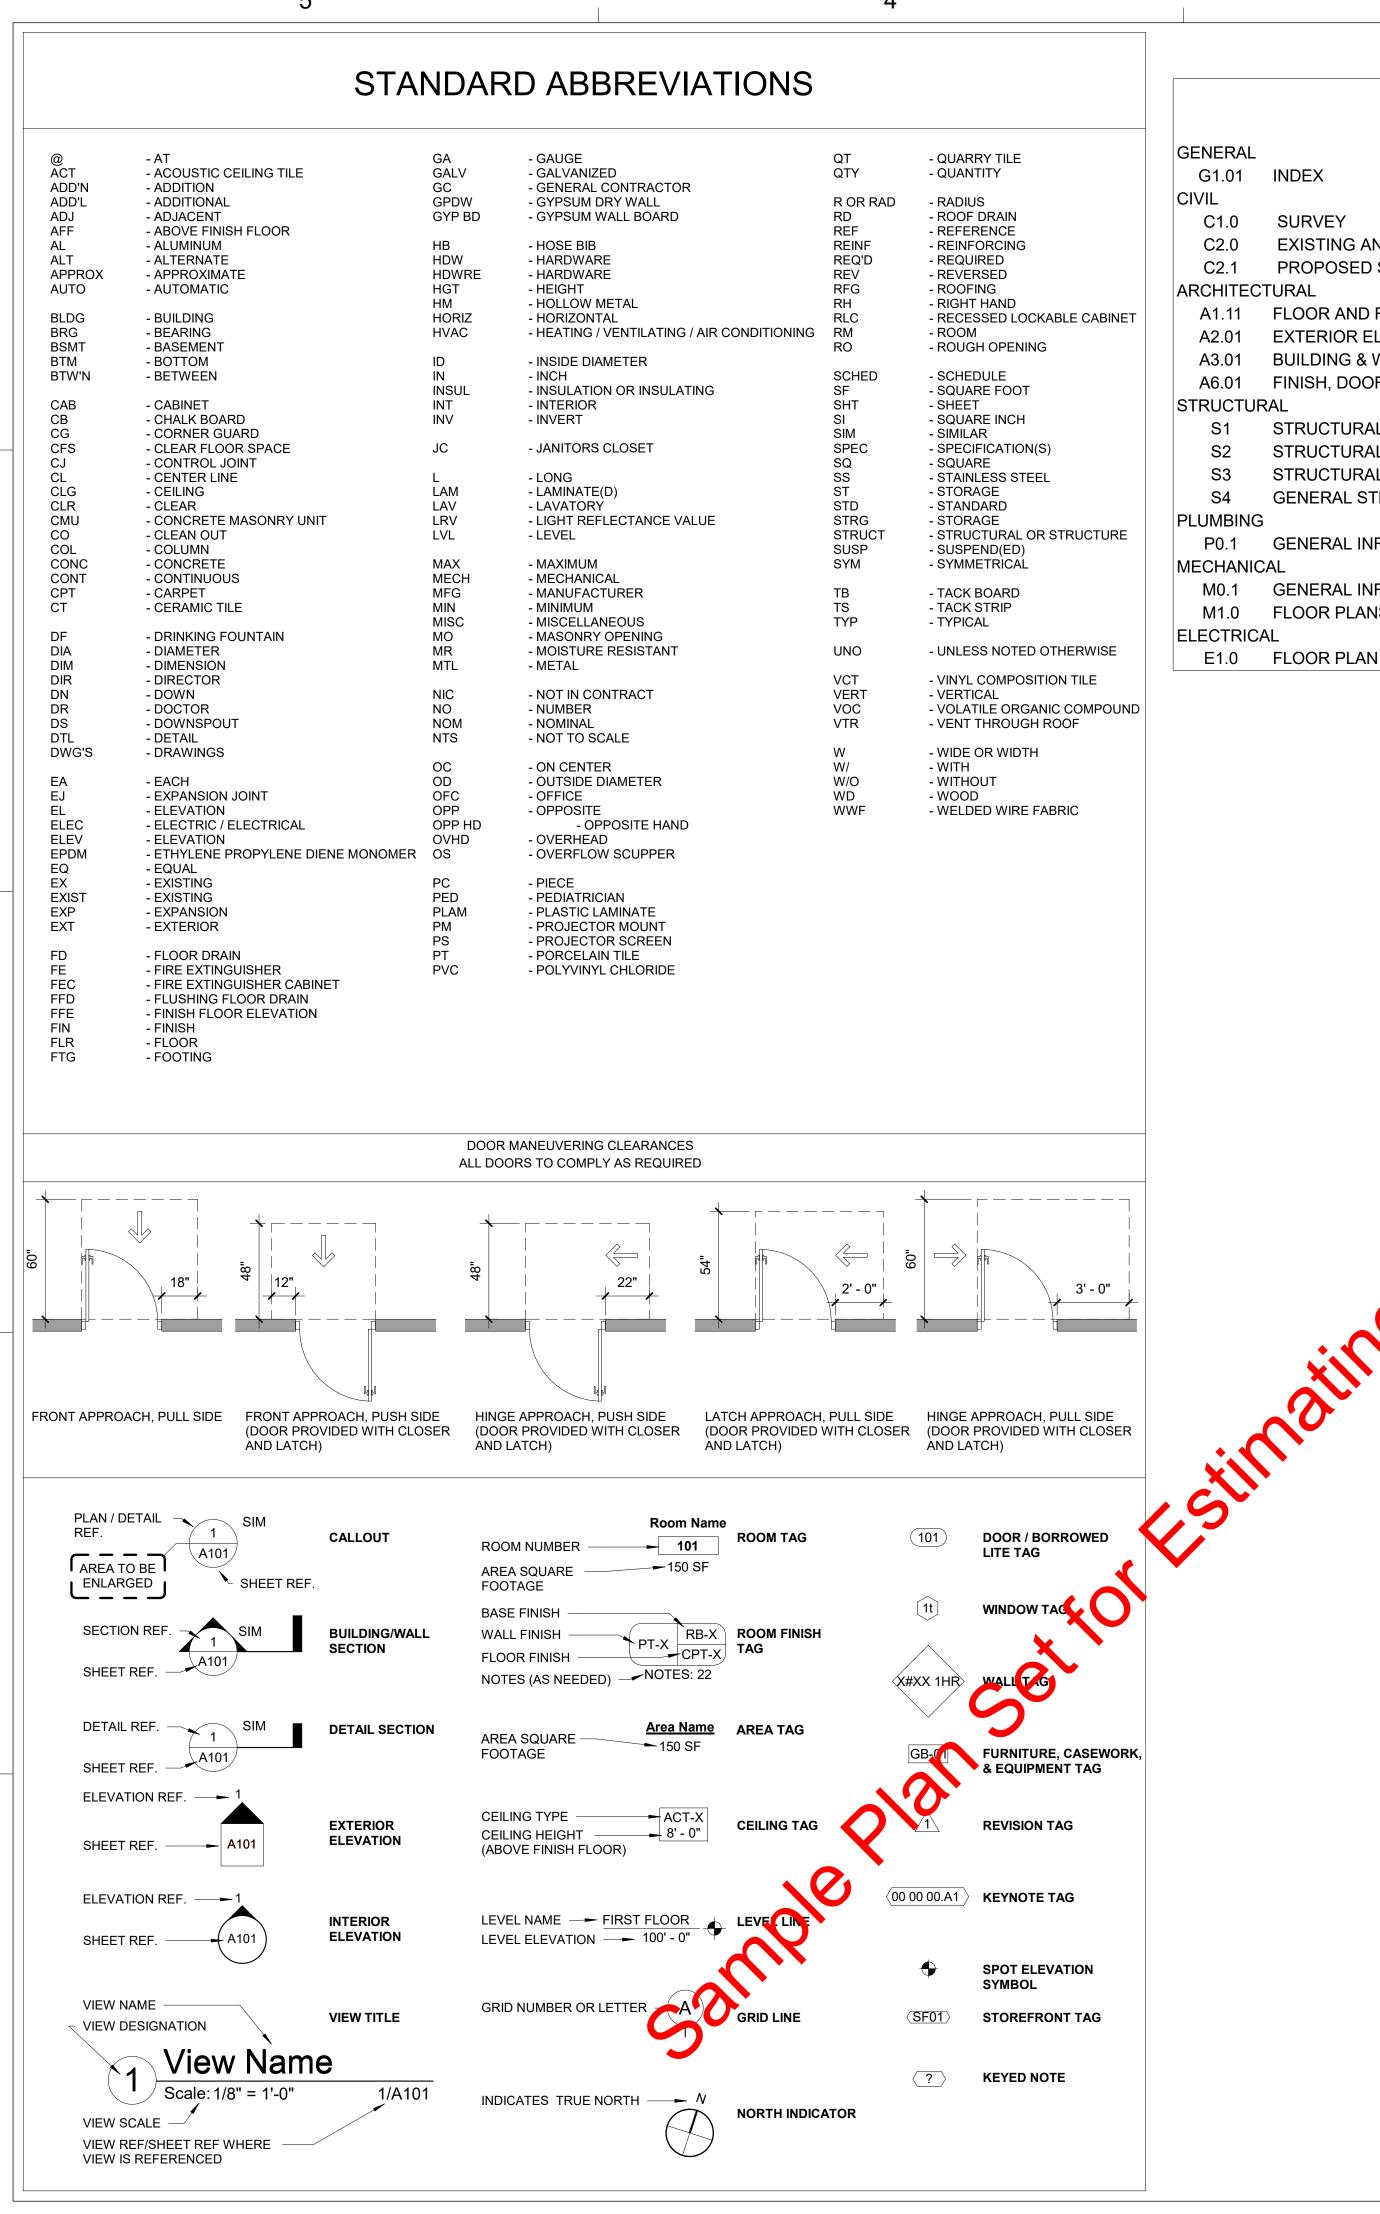

SHEET INDEX

INDEX

SURVEY EXISTING AND PROPOSED SITE OVERLAY PROPOSED SITE AND DRAINAGE PLAN

ARCHITECTURAL A1.11

FLOOR AND ROOF PLANS **EXTERIOR ELEVATIONS BUILDING & WALL SECTIONS AND INTERIOR ELEVATIONS**

FINISH, DOOR, & WINDOW SCHEDULES **STRUCTURAL** STRUCTURAL PLAN VIEWS

STRUCTURAL DETAILS STRUCTURAL DETAILS **GENERAL STRUCTURAL NOTES**

GENERAL INFORMATION

MECHANICAL GENERAL INFORMATION FLOOR PLANS

GENERAL CONSTRUCTION NOTES

INSTALLATION OF THE WORK.

OR REGULATIONS TAKE PRECEDENCE.

WORK, UNLESS DIRECTED OTHERWISE.

ND BENCHMARK CERTIFICATE.

DISCONNECT UTILITIES AS REQUIRED.

A. BUILDING DATA

SEISMIC DESIGN CATEGORY : TBD (FIGURE R301.2.2(2))

B. ENERGY SUMMARY

: 1,460 SF : 117 SF

: 1,577 SF

: NEW CONSTRUCTION

: SINGLE FAMILY RESIDENTIAL

: 19'-8" (+ HEIGHT OF PIERS IF APPLICABLE)

REQUIRED

R-38

R-13

R-13

R-0

0.4

0.25

TYPE OF WORK

FIRE ALARM

SPRINKLERS

STANDPIPES

FIRE DISTRICT

RISK CATEGORY

BUILDING HEIGHT

CLIMATE ZONE

TABLE R402.1.2

CEILING

FLOOR SLAB

SHGC

IECC REQUIREMENTS:

THERMAL ENVELOPE

MAXIUMUM U-FACTOR

NEW BUILDING AREA

GROSS

CONSTRUCTION TYPE

FLOOD HAZARD AREA

FIRE/SMOKE RATED WALLS

CONDITIONED

UNCONDITIONED

WALLS ABOVE GRADE (WOOD FRAMED)

FENESTRATION REQUIREMENTS

FURNISH ALL MATERIALS, EQUIPMENT, AND LABOR NECESSARY TO

INSTALL ALL EQUIPMENT AND MATERIALS IN STRICT ACCORDANCE

DETAILS ARE INTENDED TO SHOW END RESULT OF DESIGN, MINOR MODIFICATIONS MAY BE REQUIRED TO SUIT JOB DIMENSIONS OR

WORK SHOWN OR REFERRED TO ON ANY DRAWING SHALL BE PROVIDED AS THOUGH SHOWN ON ALL RELATE. DRAWINGS.

EVERY EFFORT HAS BEEN MADE TO PROVIDE THE COMPLETE

DISCREPANCIES, PRICE THE MORE EXPENSIVE OR EXTENSIVE

GENERAL CONTRACTOR SHALL PROVIDE AT THE JOB SITE A FULL SET OF CONSTRUCTION DOCUMENTS ANNOTATED WITH THE

LATEST REVISIONS AND CLARIFICATIONS FOR THE USE BY ALL.

ALL PERMIT INSPECTIONS, AND/OR CERTIFICATES FROM THE

HE CONTRACTOR SHALL VERIFY THE MINIMUM FINISH FLOOR

THE CONTRACTOR SHALL HAVE THE WORK SITE CLEANED ON A

DAILY BASIS. THE DISPOSAL OF ANY WASTE SHALL BE OFF SITE

COORDINATE WITH UTILITY PROVIDERS TO LOCATE, CAP, AND/OR

EVATION WITH THE CITY/PARISH FEMA BASE FLOOD ELEVATION

PPROVAL FROM THE STATE FIRE MARSHAL IF REQUIRED.

LITY TO CALL FOR LOCAL INSPECTIONS AND OBTAIN

THE INTENT OF THESE DOCUMENTS. IN THE EVENT OF

APPROPR ATE AGENCIES. IT IS THE CONTRACTOR'S

AND IN A MANNER PRESCRIBED UNDER THE LAW.

SCOPE OF WORK. MINOR OMISSIO S AND DISCREPANCIES IN THE DRAWINGS SHALL NOT DIMINISH THE EXPECTATION OF A COMPLETED FACILITY AND IMPROVEMENTS IN ACCORDANCE WITH

INCLUDING DETAILS AND LABOR NECESSARY FOR SUCCESSFUL

SPECIFICALLY INDICATED OTHERWISE OR WHERE LOCAL CODE

AFFECT ALL INSTALLATIONS INDICATED ON THE DRAWINGS.

WITH MANUFACTURERS' RECOMMENDATIONS UNLESS

IT IS THE RESPONSIBILITY OF THE CONTRACTOR TO VERIFY AND THE CONTRACTOR SHALL VISIT THE JOB SITE TO REVIEW THE COMPLY WITH ALL BUILDING CODE, MUNICIPAL CODE AND HOME SCOPE OF WORK AND CONFIRM THAT THE WORK MAY BE OWNER ASSOCIATION (HOA) REQUIREMENTS. ACCOMPLISHED AS SHOWN.

RAZE EXISTING STRUCTURE AS REQUIRED, PROPERLY DISPOSING PLANS ARE NOT TO BE SCALED AND ARE INTENDED TO BE A DIAGRAMMATIC OUTLINE, UNLESS OTHERWISE NOTED.

REQUIRED.

OF DEBRIS WITH A LEGAL DUMPSTER ON SITE. EMOVE SIDEWALKS, DRIVEWAYS, AND OTHER FLATWORK ON SITE

PEMOVE EXISTING SHRUBS, TREE ROOTS, ETC WHERE NEW FLATWORK, DRAINLINES, AND HOUSE SLABS WILL BE LOCATED AS

COORDINATE TREE REMOVAL WITH MUNICPALITY. PROTECT TREES

FILL HOLES CAUSED BY REMOVAL OF EXISTING OBSTRUCTIONS WITH SOIL SIMILAR TO EXISTING ADJACENT SOILS.

SLOPE ALL CONCRETE PAVING AWAY FROM BUILDING AT MINIMUM

SLOPE ALL CONCRETE WALKS AWAY FROM BUILDING AT MINIMUM

SLOPE ALL FINAL GRADING AWAY FROM BUILDING TO ENSURE POSITIVE DRAINAGE TO AREA DRAINS OR CULVERTS, NOT TO ADJACENT PROPERTIES.

ALL DRIVEWAY AND SIDEWALKS SHALL MEET LOCAL DEPARTMENT OF PUBLIC WORKS STANDARD DETAILS IF APPLICABLE.

23. THE CONTRACTOR SHALL COORDINATE ALL UTILITIES INSTALLATION AND CONNECTION WITH LOCAL UTILITY COMPANY.

GENERAL CON RACTOR SHALL COORDINATE, APPLY, AND PAY FOR 24. CONTRACTOR SHALL PROVIDE CLEAN OUT LOCATIONS, TIE-IN LOCATIONS, AND WATER AND SEWER LINE LOCATIONS ON SITE TO PERMIT DEPARTMENT FOR REVIEW.

> LAY NEW SOD AROUND PERIMETER OF FOUNDATION A MINIMUM OF 8 FEET. STABILIZE OTHER DISTURBED SOILS BY OTHER APPROPRIATE METHODS.

CONTRACTOR SHALL PROVIDE ALL PLUMBING FIXTURES, ELECTRICAL FIXTURE, DOOR HARDWARE, BATHROOM HARDWARE, AND BATHROOM ACCESSORIES IN A CONSISTENT MATERIAL FINISH.

APPLIANCES SHALL BE ENERGY STAR CERTIFIED - CLOTHES WASHER, CLOTHES DRYER, RANGE HOOD, DISHWASHER, REFRIGERATOR. SUPPLY HOSES TO WATER USING FIXTURES AND APPLIANCES MUST BE ARMORED PEX OR METAL (NOT COPPER).

ALL EXTERIOR PAINT TO MEET LIGHT REFLECTANCE VALUE (LRV) OF

PER FBC APPENDIX F, PASSIVE RADON-RESISTANT CONSTRUCTION: PROVIDE 6 MIL VAPOR BARRIER UNDER SLAB ON GRADE. 2" PRESSURE-SENSITIVE VINYL TAPE ALL JOINTS.

SEAL AND CAULK ALL SLAB PENETRATIONS WITH MASTIC OR SLABS AND FOUNDATIONS SHALL BE CONSTRUCTED USING A SLAB EDGE DETAIL THAT ELIMINATES CRACKS THAT COULD

CONNECT THE HOUSE INTERIOR TO SUBSLAB SOIL. MONOLITHIC SLAB CONSTRUCTION USED WHERE POSSIBLE ALL CONTRACTION JOINTS SHALL BE CLEANED AND SEALED AGAINST SOIL-GAS ENTRY BY USE OF AN APPROVED SEALANT.

WORK SPACES FORMED INTO A SLAB SHALL BE SEALED GAS-TIGHT. EXPOSED SOIL SHALL BE COMPACTED AND FULLY COVERED WITH A SOLVENT-BASED PLASTIC ROOF CEMENT OR OTHER APPROVED ELASTOMERIC MATERIAL TO A MIN.

WHERE PENETRATING PIPES ARE SLEEVED, THEY SHALL BE SEALED BY JOINT SEALANT OR APPROVED ALTERNATIVE VAPOR BARRIER NOT REQUIRED FOR PIER CONSTRUCTION WHEN BOTTOM OF FLOOR JOISTS ARE GREATER THAN 18" FROM GRADE

C. BUILDING CODE SUPPORTING DATA

APPLICABLE CODE

R304.2

/ PROVIDED

/ R-19

/ R-19

/ R-0

/ R-38 BLOWN

OR / (2) R-19 BLANKET

:2023 FLORIDA BUILDING CODE, RESIDENTIAL 2023 FLORIDA BUILDING CODE, ENERGY CONSERVATION 2018 WOOD FRAME CONSTRUCTION MANUAL **AMERICANS WITH DISABILITIES ACT GUIDELINES**

ENCLOSED SPACE UNDER STAIRS THAT IS ACCESSED BY A DOOR OR ACCESS PANEL SHALL HAVE WALLS, UNDER-STAIR SURFACE AND ANY SOFFITS PROTECTED ON THE ENCLOSED SIDE WITH 1/2-INCH GYPSUM BOARD

IN COMBUSTIBLE CONSTRUCTION, FIREBLOCKING SHALL BE PROVIDED TO CUT OFF BOTH VERTICAL AND HORIZONTAL CONCEALED DRAFT OPENINGS AND TO FORM AN EFFECTIVE FIRE BARRIER BETWEEN STORIES, AND BETWEEN A TOP STORY AND THE

HABITABLE ROOMS SHALL HAVE AN AGGREGATE GLAZING AREA OF NOT LESS THAN 8 PERCENT OF THE FLOOR AREA OF SUCH ROOMS

HABITABLE ROOMS SHALL HAVE A ROOM AREA OF NOT LESS THAN 70 SQUARE FEET EXCEPTION: KITCHENS

HABITABLE ROOMS SHALL BE NOT LESS THAN 7 FEET IN ANY HORIZONTAL DIMENSION **EXCEPTION: KITCHENS** BASEMENTS, HABITABLE ATTICS, AND EVERY SLEEPING ROOM SHALL HAVE NOT LESS

THAN ONE OPERABLE EMERGENCY ESCAPE AND RESCUE OPENING EMERGENCY ESCAPE AND RESCUE OPENINGS SHALL HAVE A NET CLEAR OPENING OF NOT LESS THAN 5.7 SQUARE FEET

NOT LESS THAN ONE EGRESS DOOR SHALL BE PROVIDED FOR EACH DWELLING UNIT, AND SHALL PROVIDE A CLEAR WIDTH OF NOT LESS THAN 32 INCHES.

THERE SHALL BE A LANDING OR FLOOR ON EACH SIDE OF EACH EXTERIOR DOOR. THE WIDTH OF THE LANDING SHALL BE NOT LESS THAN THE DOOR SERVED. LANDINGS SHALL HAVE A DIMENSION OF NOT LESS THAN 36 INCHES MEASURED IN THE DIRECTION OF TRAVEL

THE WIDTH OF A HALLWAY SHALL BE NOT LESS THAN 3 FEET

A FLIGHT OF STAIRS SHALL NOT HAVE A VERTICAL RISE LARGER THAN 12 FEET 7 INCHES BETWEEN FLOOR LEVELS OR LANDINGS

THE MAXIMUM RISER HEIGHT SHALL BE 7 3/4 INCHES

THE TREAD DEPTH SHALL BE NOT LESS THAN 10 INCHES

SMOKE ALARMS SHALL BE INSTALLED IN EACH SLEEPING ROOM, OUTSIDE EACH SEPARATE SLEEPING AREA IN THE IMMEDIATE VICINITY OF THE BEDROOMS, NOT LESS THAN 3 FEET HORIZONTALLY FROM THE DOOR OR OPENING OF A BATHROOM THAT CONTAINS A BATHTUB OR SHOWER, AND ON EACH ADDITIONAL STORY.

BUILDINGS SHALL BE PROVIDED WITH APPROVED ADDRESS IDENTIFICATION. THE ADDRESS IDENTIFICATION SHALL BE LEGIBLE AND PLACED IN A POSITION THAT IS VISIBLE FROM THE STREET OR ROAD FRONTING THE PROPERTY. EACH CHARACTER SHALL BE NOT LESS THAN 4 INCHES IN HEIGHT

THE UNDER-FLOOR SPACE BETWEEN THE BOTTOM OF THE FLOOR JOISTS AND THE EARTH UNDER ANY BUILDING SHALL HAVE VENTILATION OPENINGS THROUGH FOUNDATION WALLS OR EXTERIOR WALLS. THE MINIMUM NET AREA OF VENTILATION OPENINGS SHALL BE NOT LESS THAN 1 SQUARE FOOT FOR EACH 150 SQUARE FEET OF UNDER-FLOOR SPACE AREA. ONE SUCH VENTILATING OPENING SHALL BE WITHIN 3 FEET OF EACH CORNER OF THE BUILDING

SCALE

As indicated

Dewberry

877 North County Hwy 393

850.267.0759 Phone

850.557.0076 Fax

www.dewberry.com

Santa Rosa Beach, FL 32459

Description REVISIONS **DRAWN BY** SEH APPROVED BY LWH **CHECKED BY** ANS


50171913

SHEET NO.


PROJECT NO.


DATE

TITLE

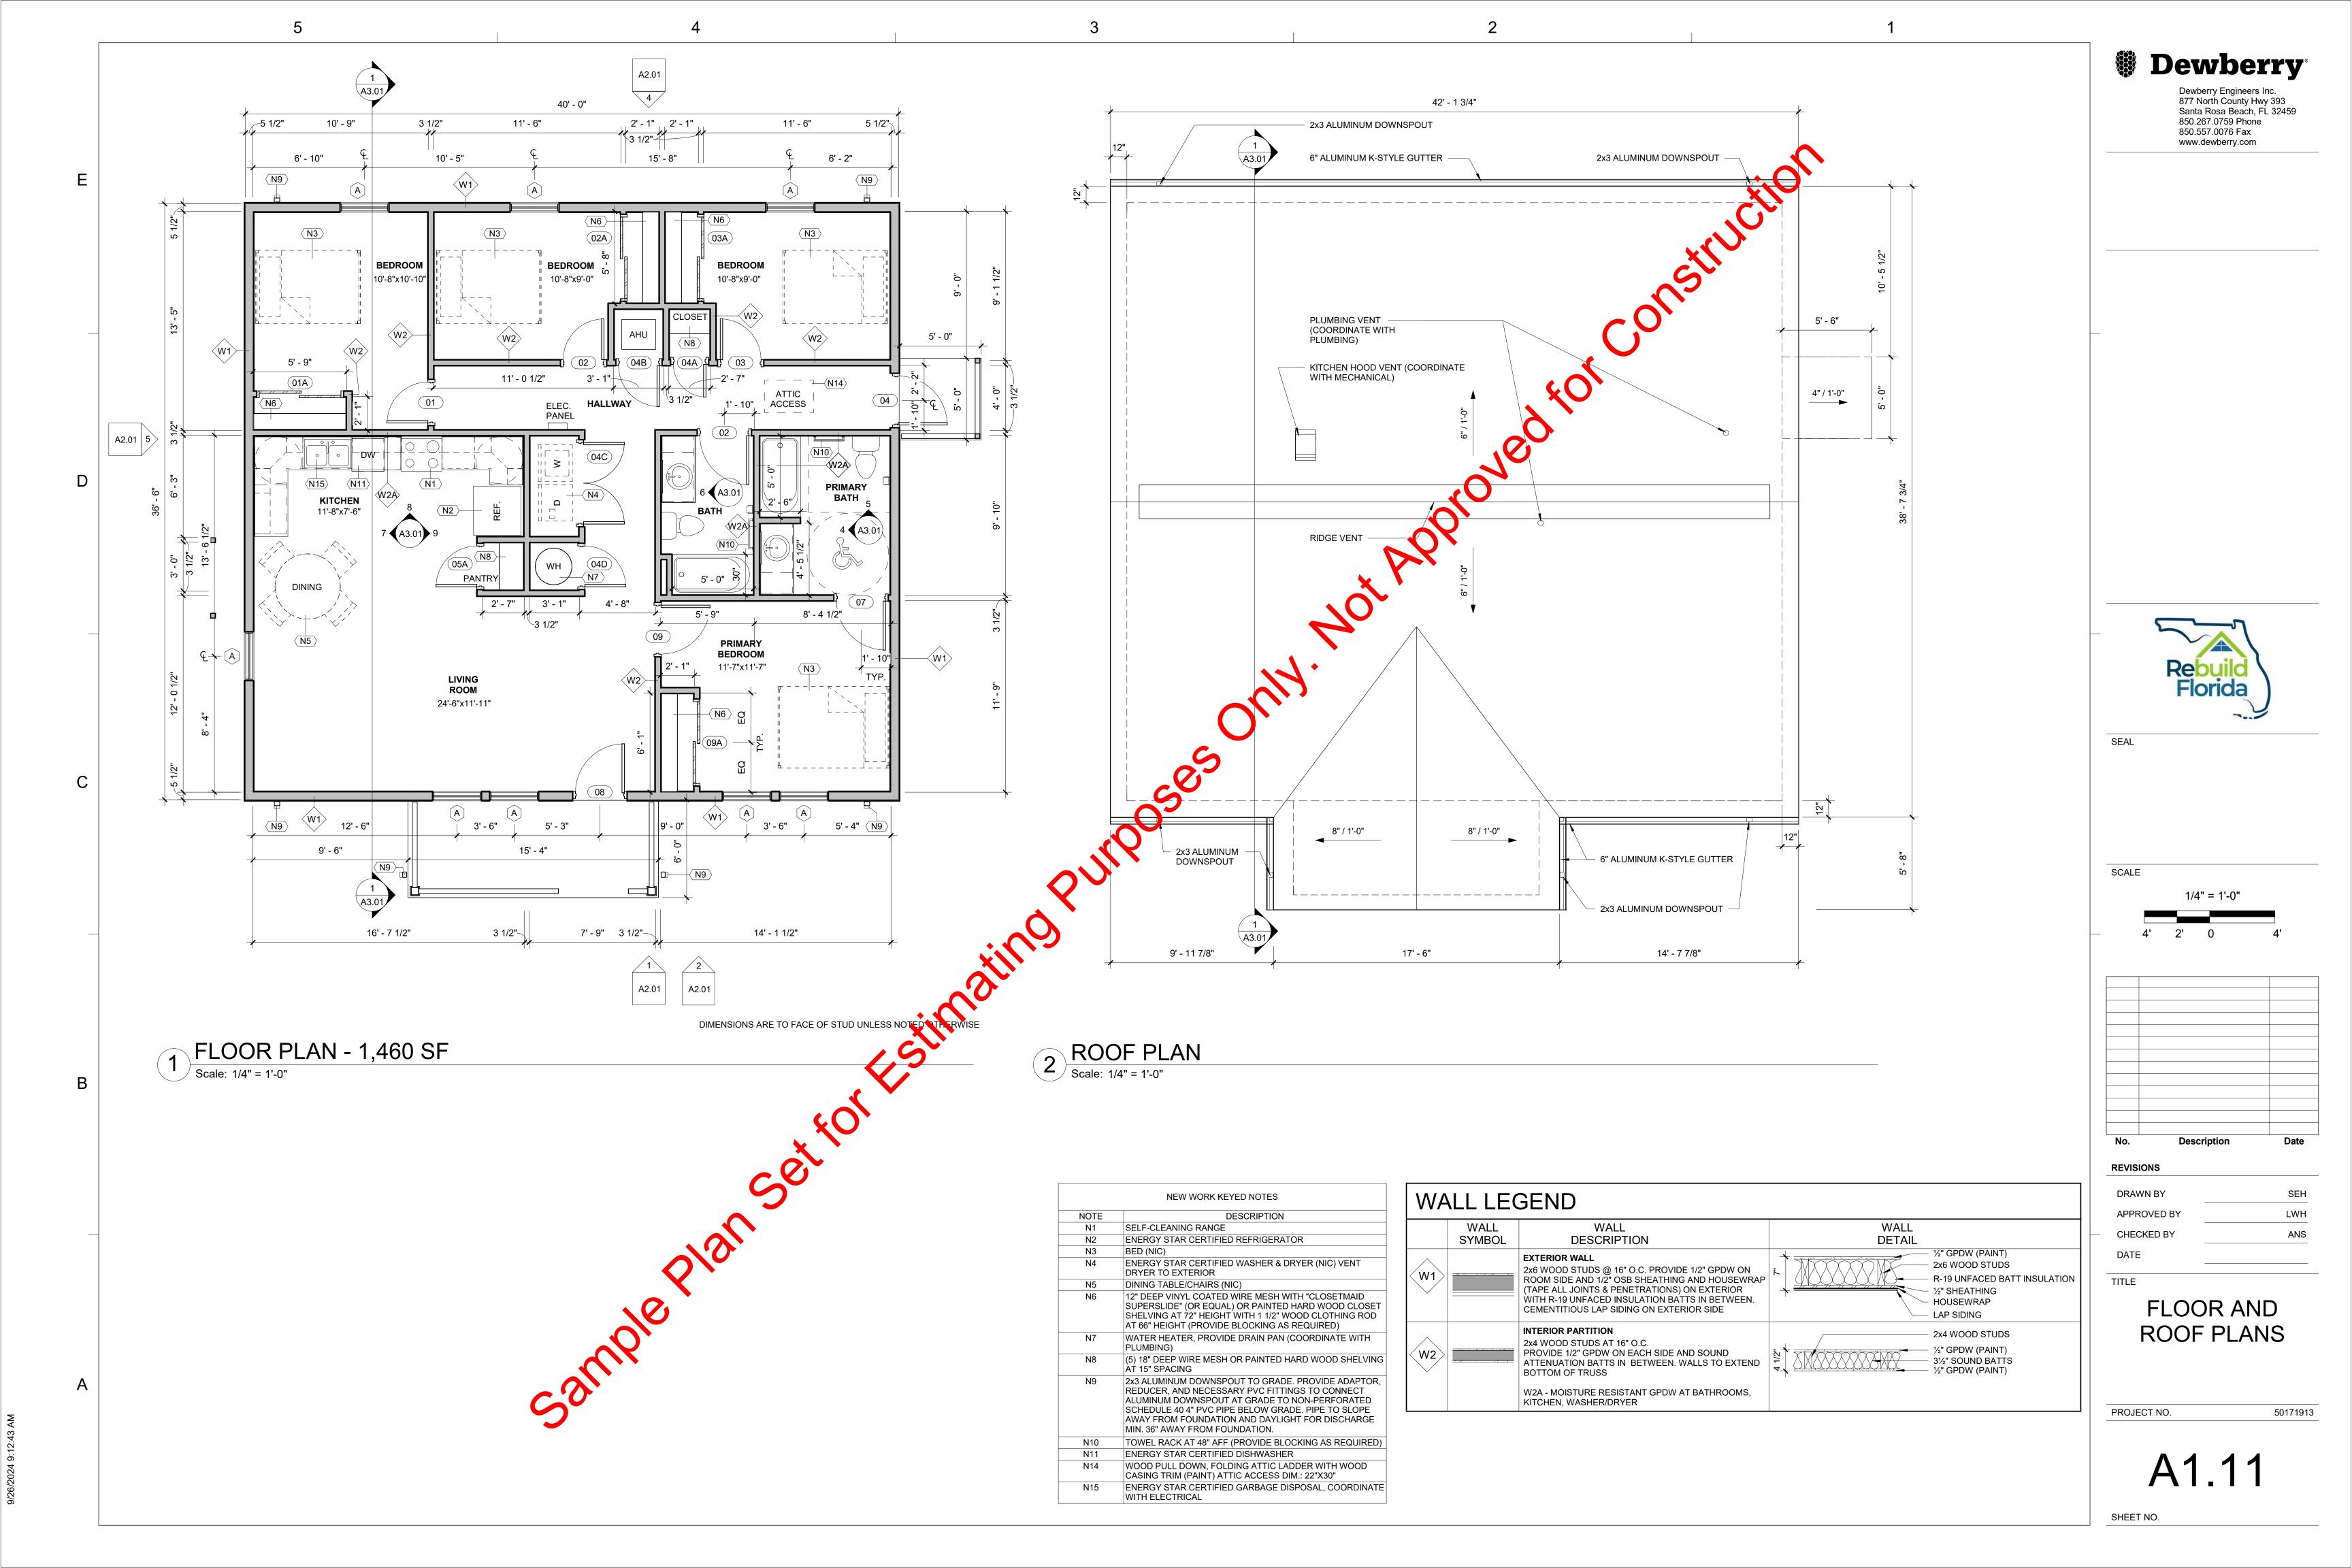



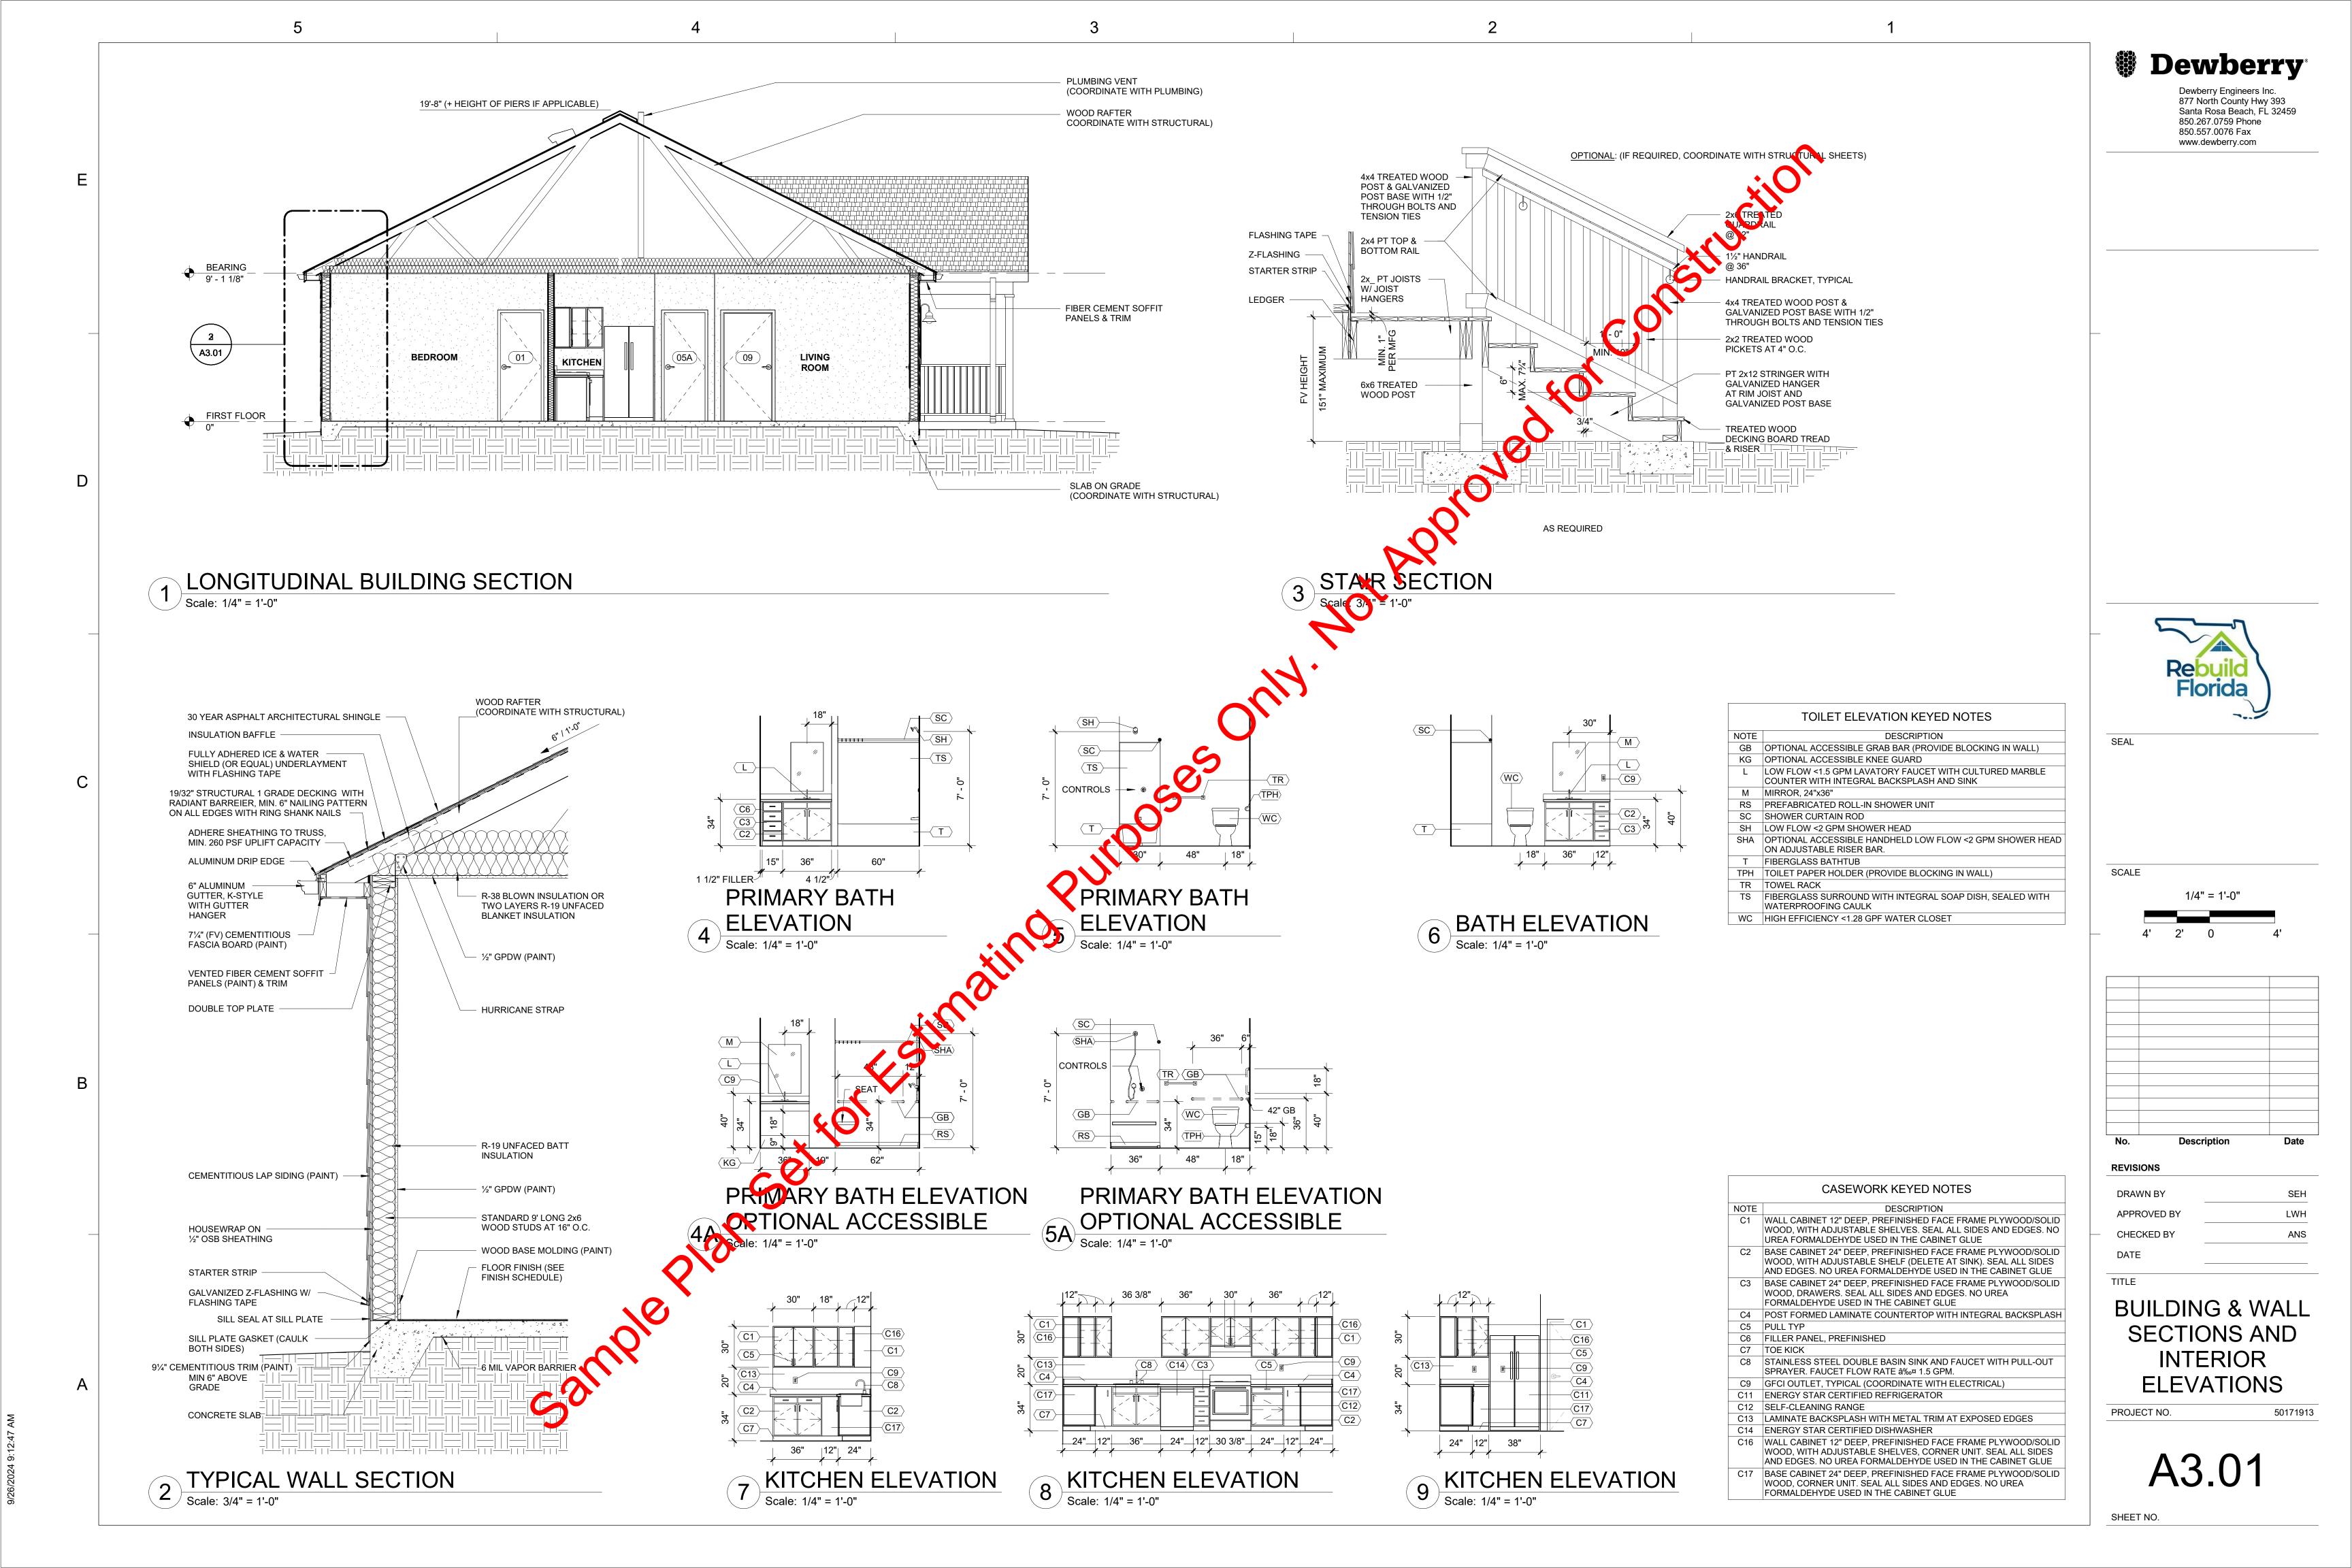

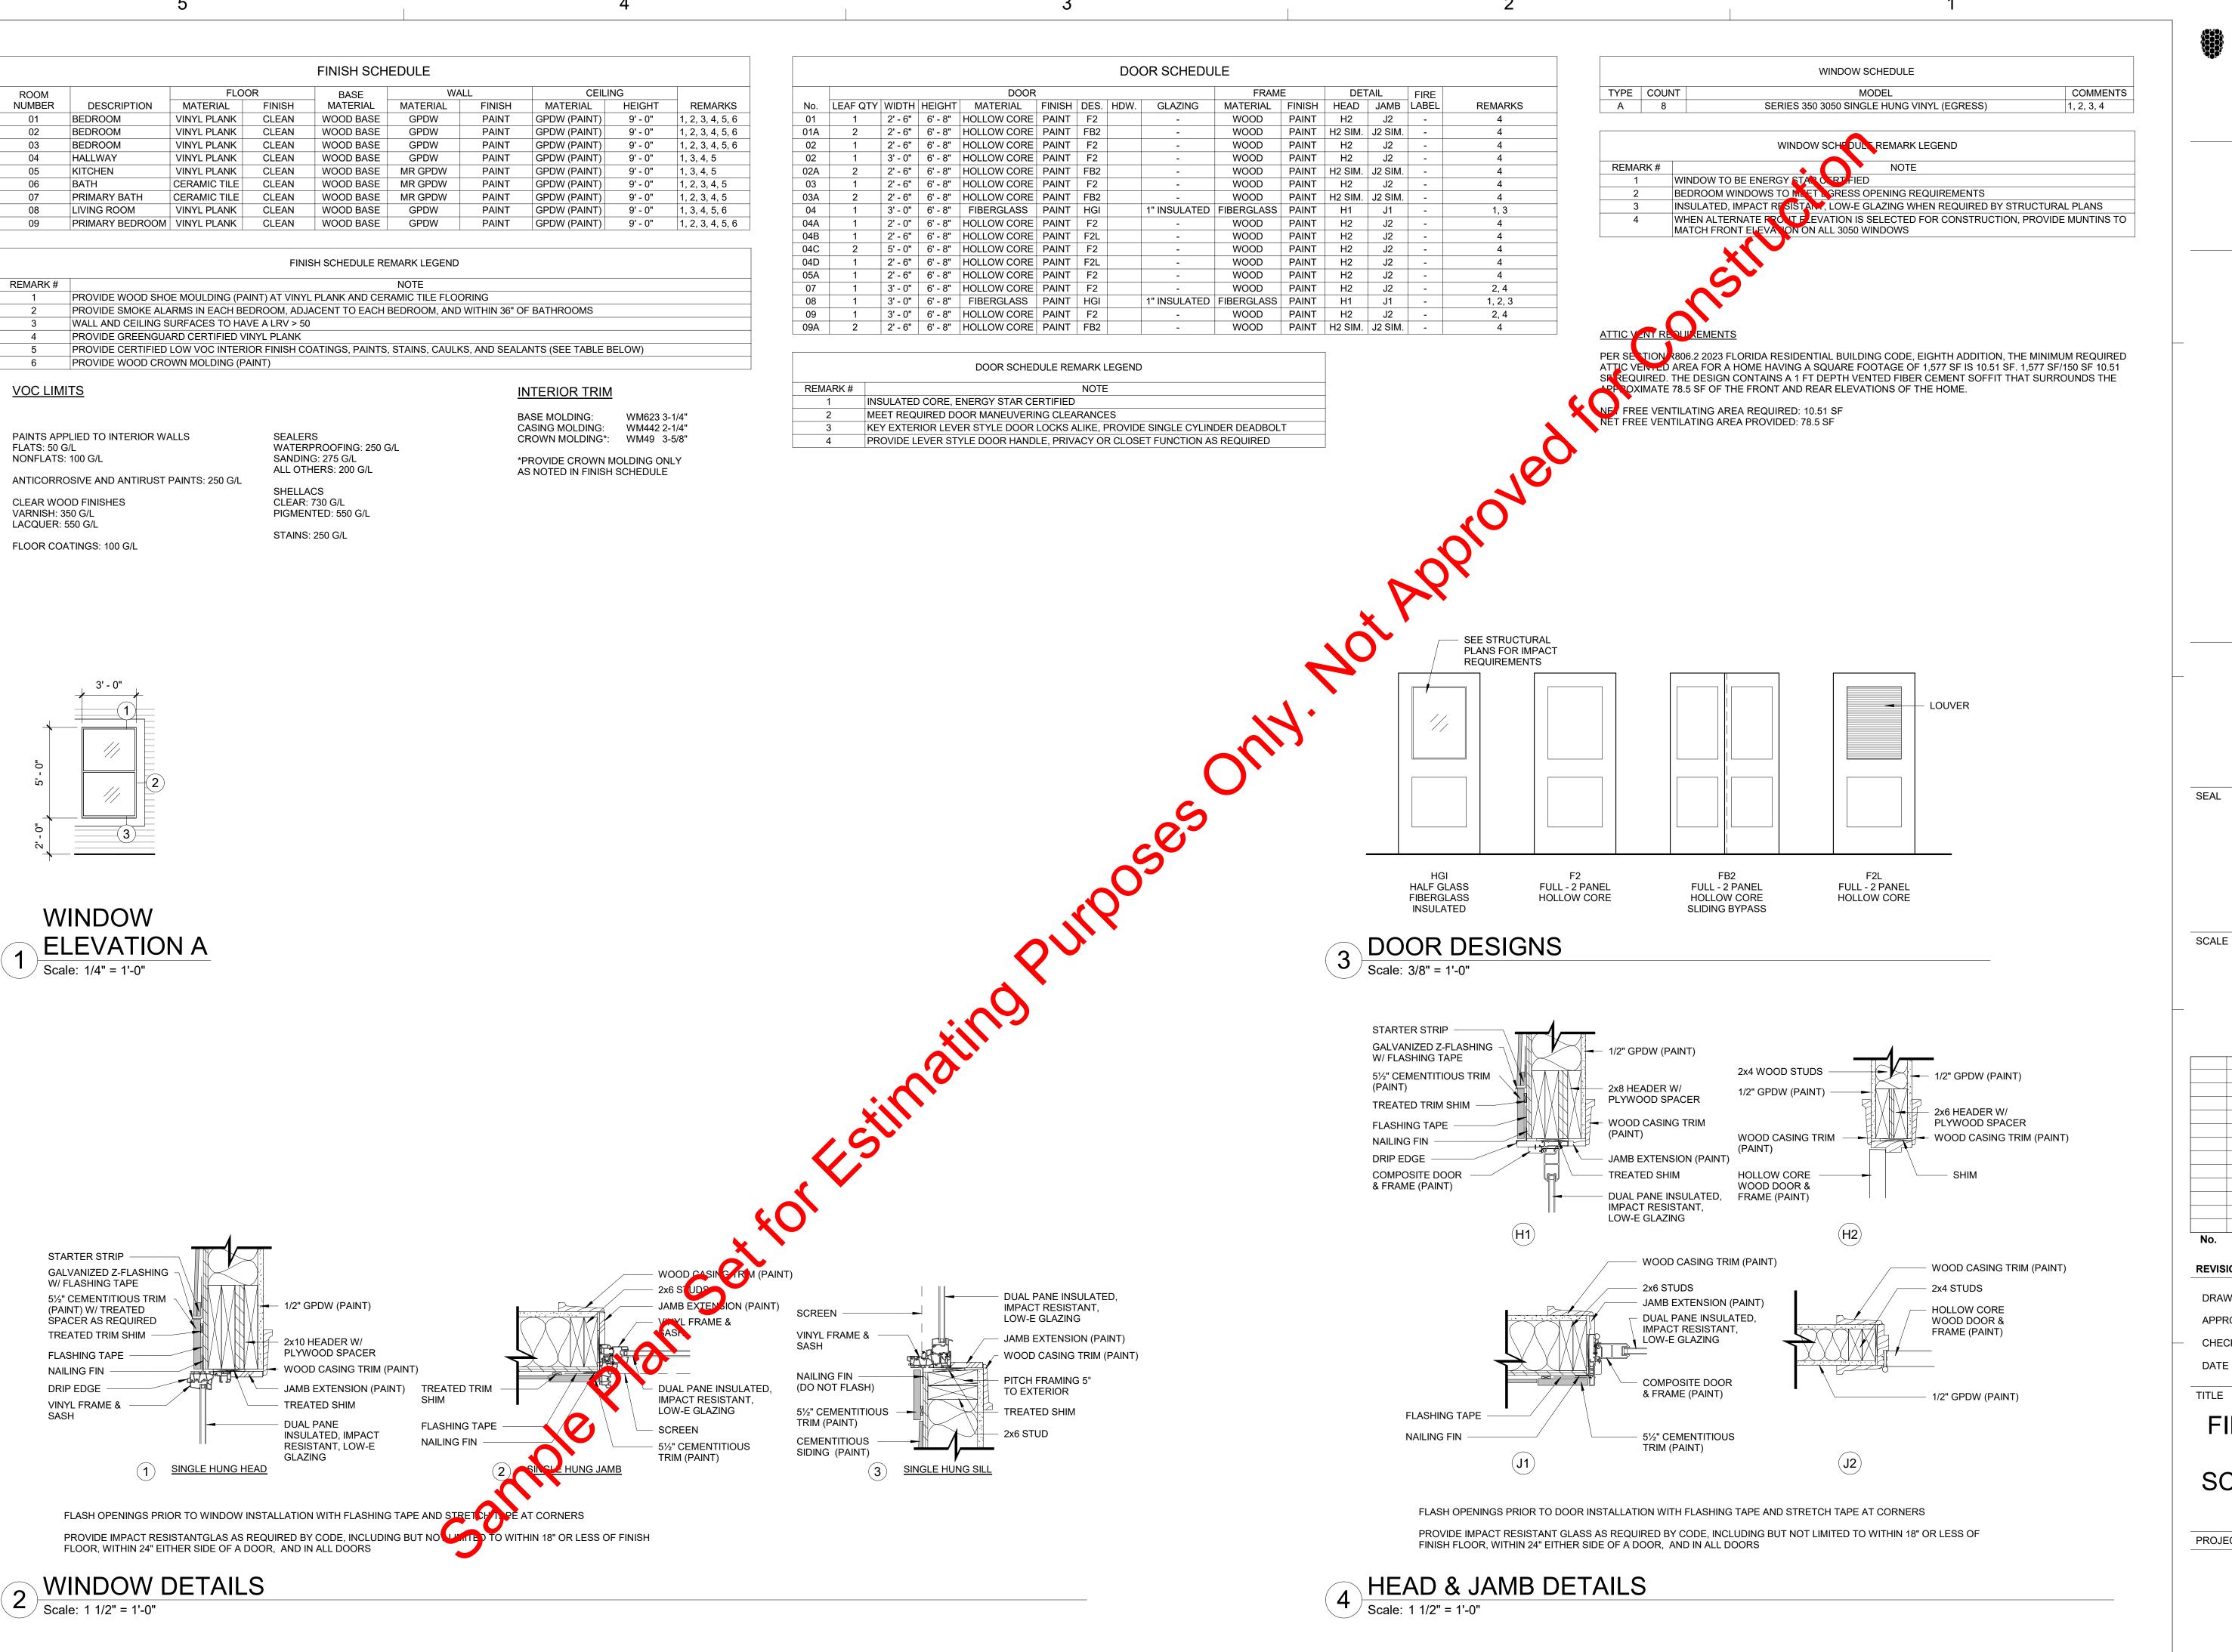

Dewberry Engineers Inc. 877 North County Hwy 393 Santa Rosa Beach, FL 32459 850.267.0759 Phone 850.557.0076 Fax www.dewberry.com

As indicated

Description REVISIONS

DRAWN BY SEH APPROVED BY CHECKED BY ANS DATE


FINISH, DOOR, &


WINDOW **SCHEDULES AND DETAILS**

50171913

PROJECT NO.

A6.01

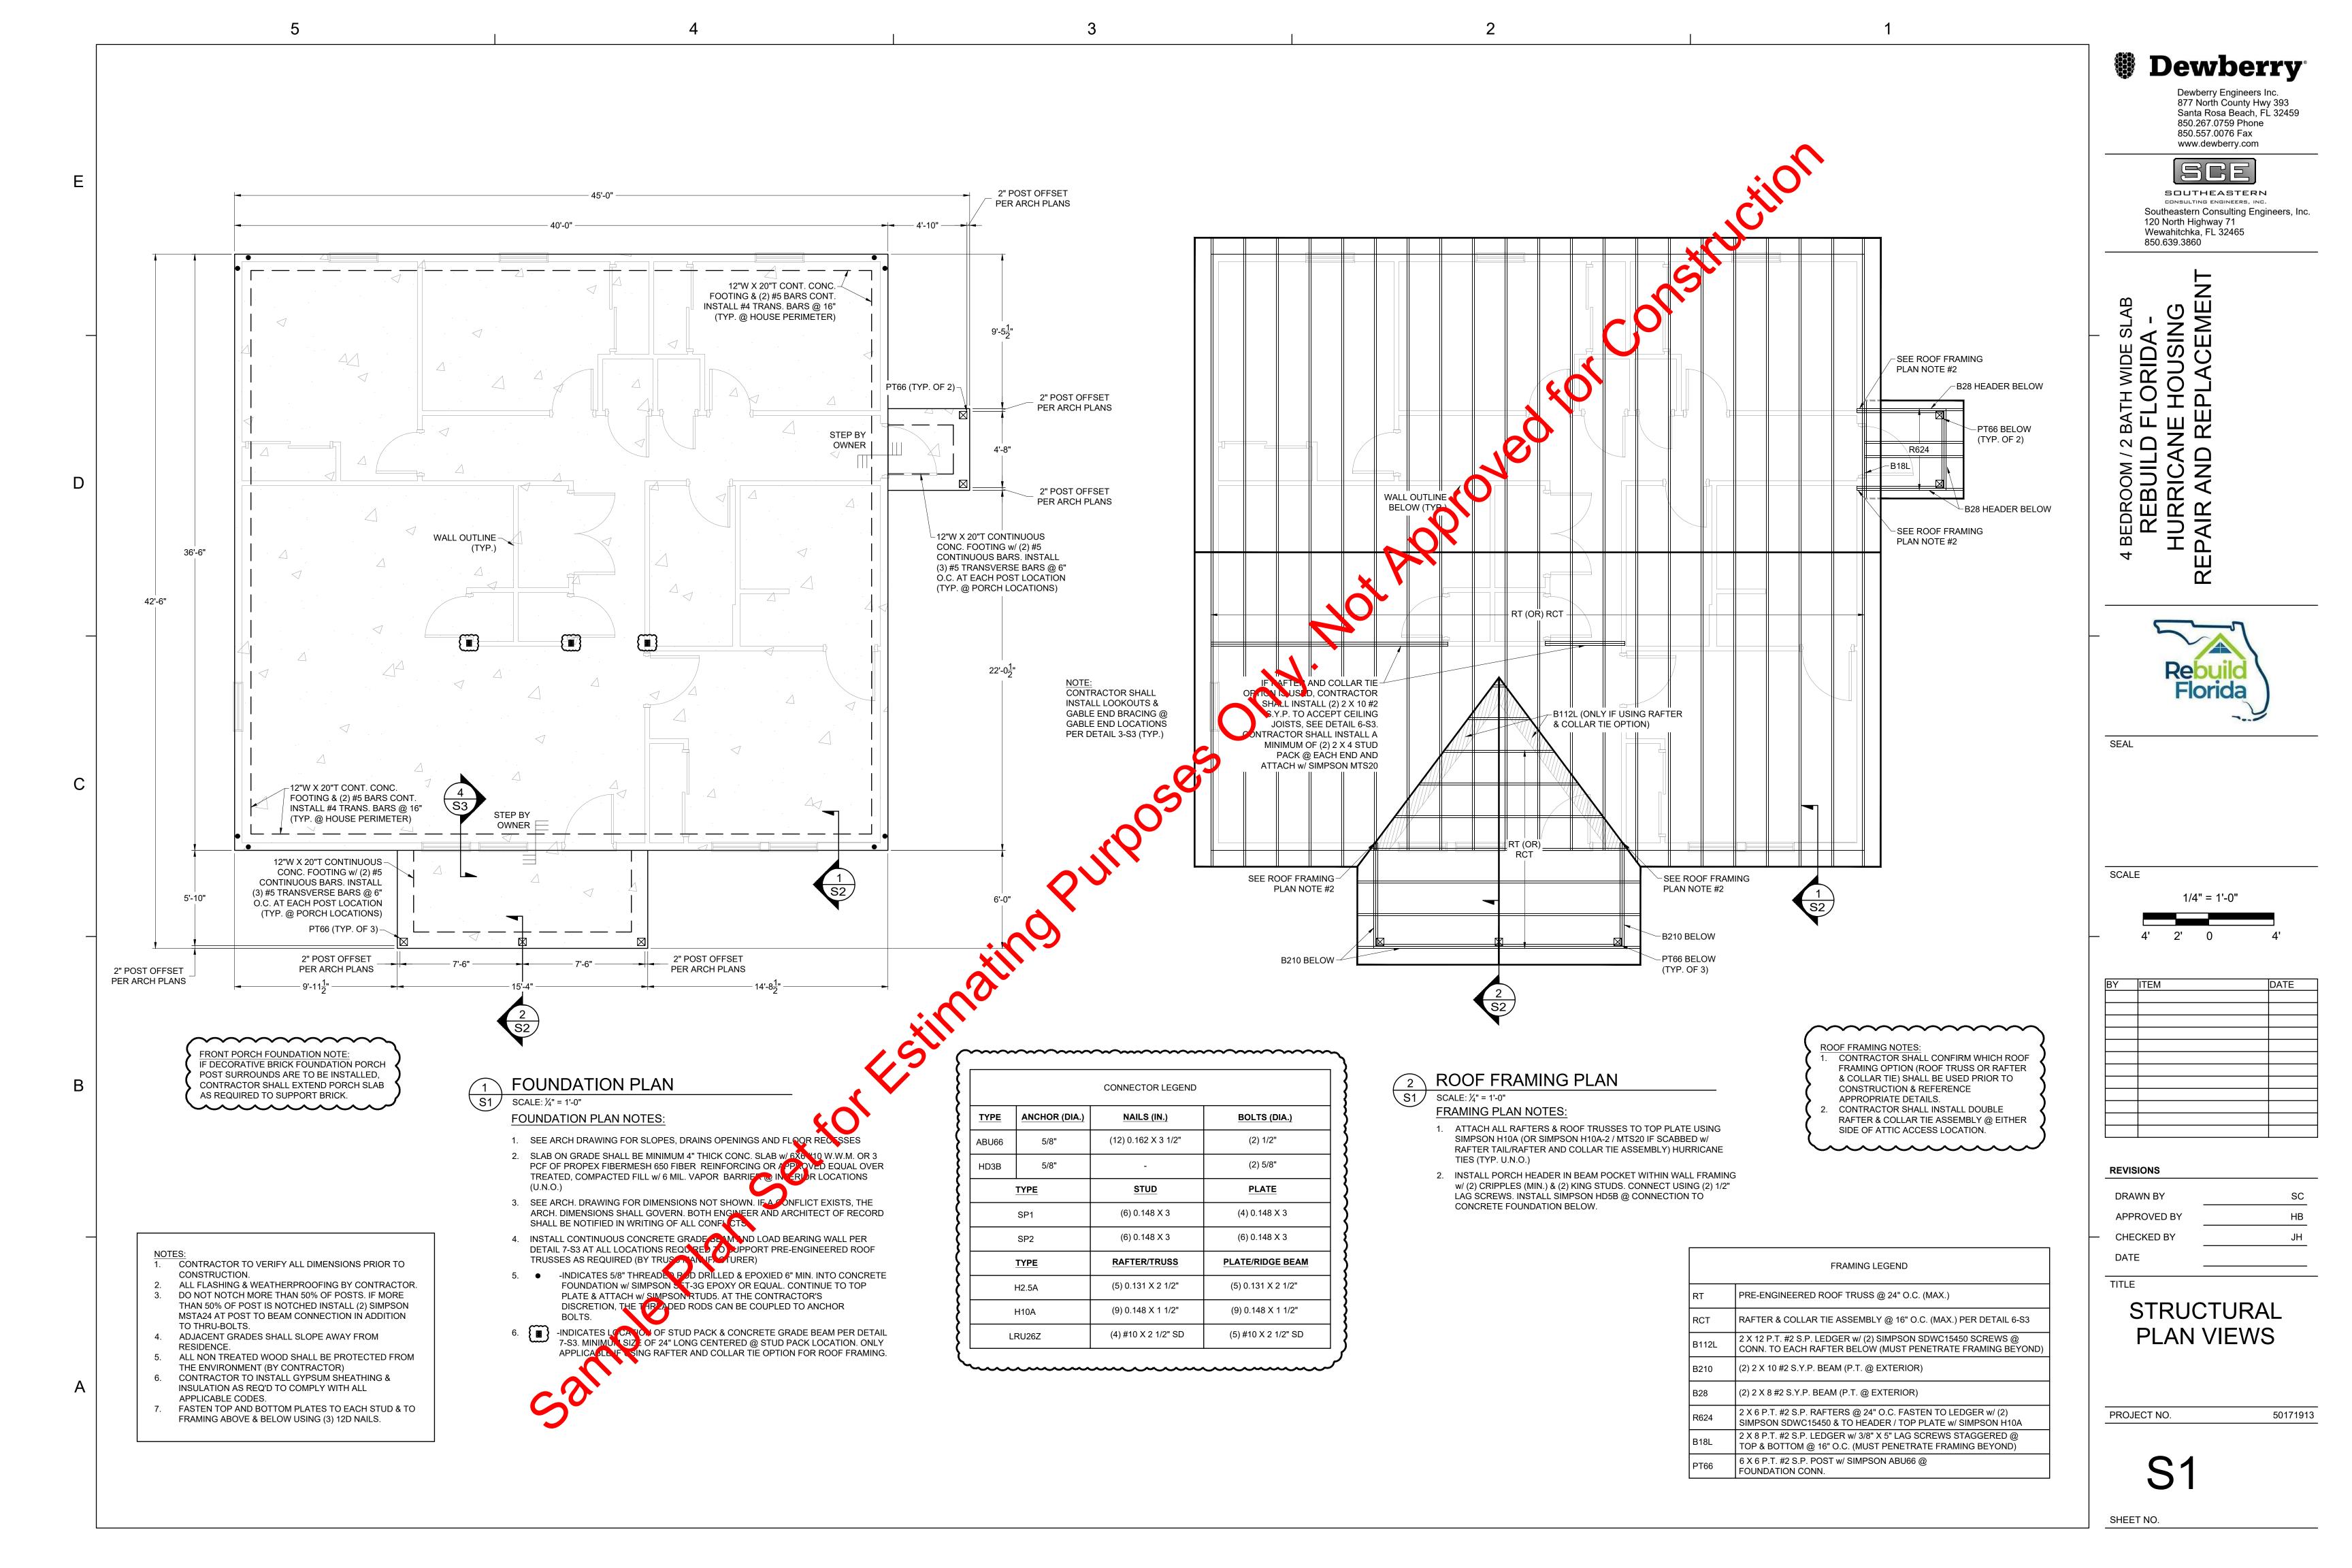

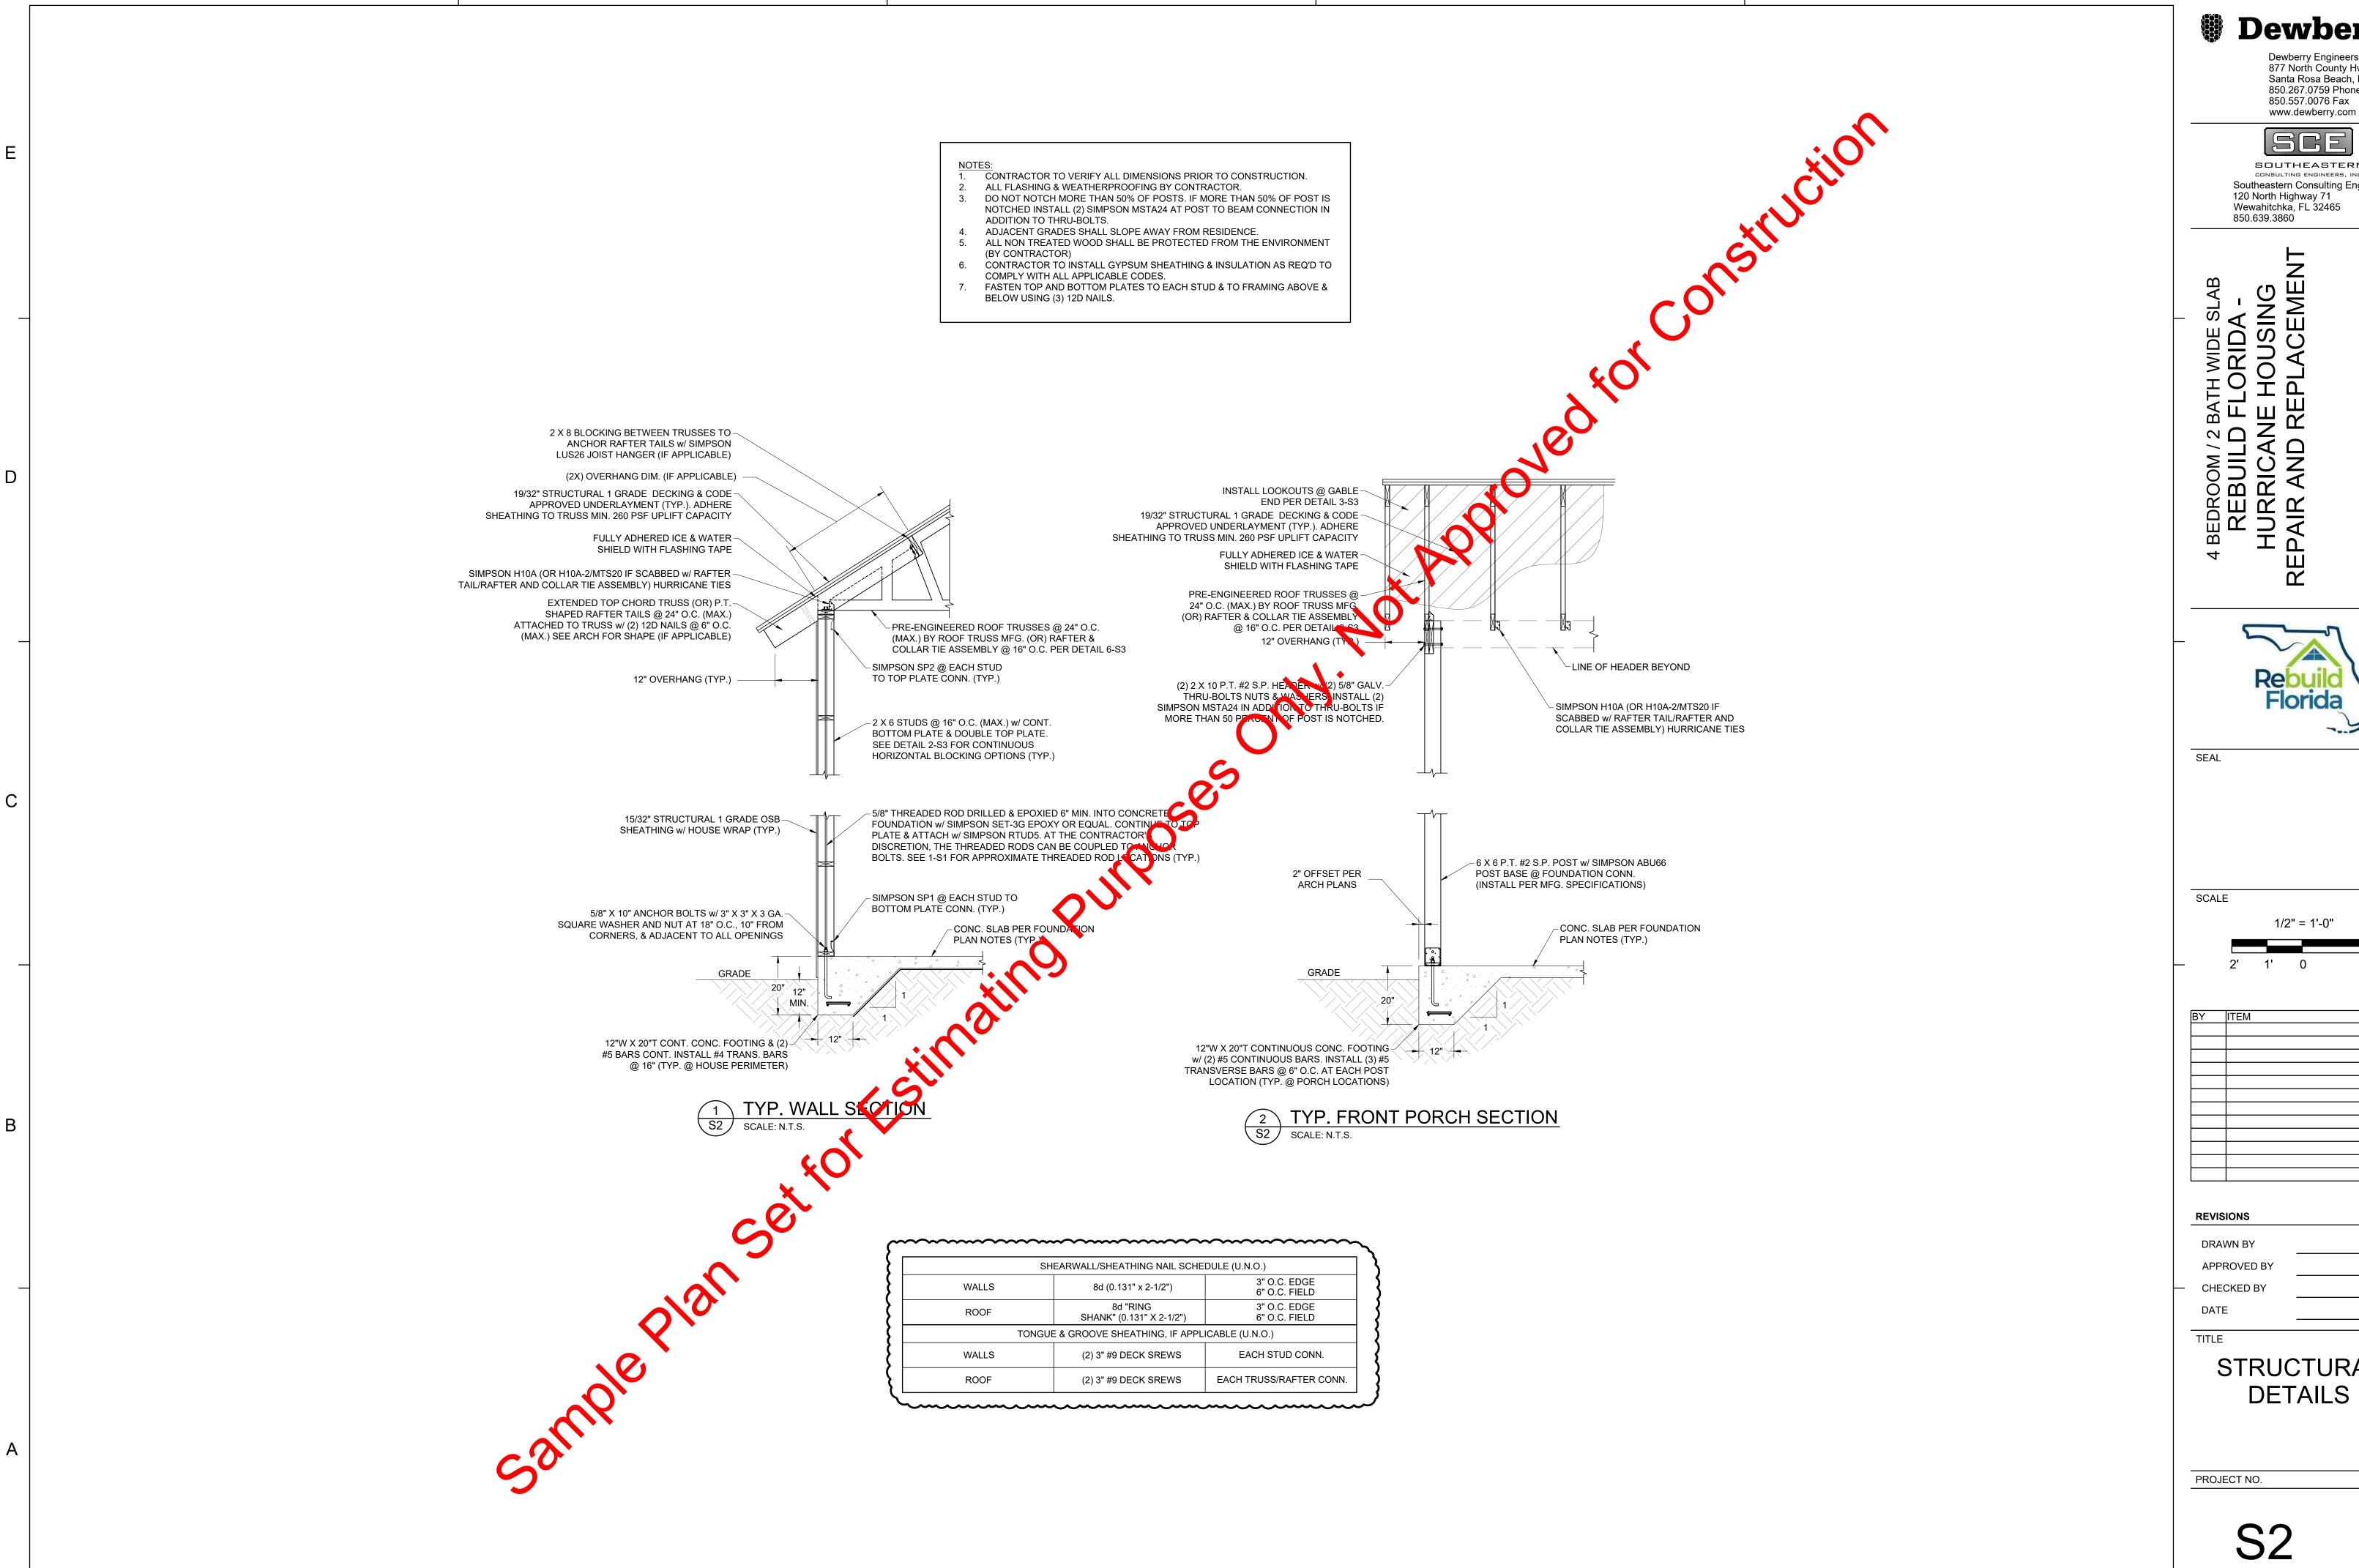

Dewberry Engineers Inc. 877 North County Hwy 393 Santa Rosa Beach, FL 32459 850.267.0759 Phone 850.557.0076 Fax


SOUTHEASTERN CONSULTING ENGINEERS, INC. Southeastern Consulting Engineers, Inc. Wewahitchka, FL 32465



	BY	ITEM	DATE
	·		
· '			<u>"</u>

STRUCTURAL **DETAILS**

50171913

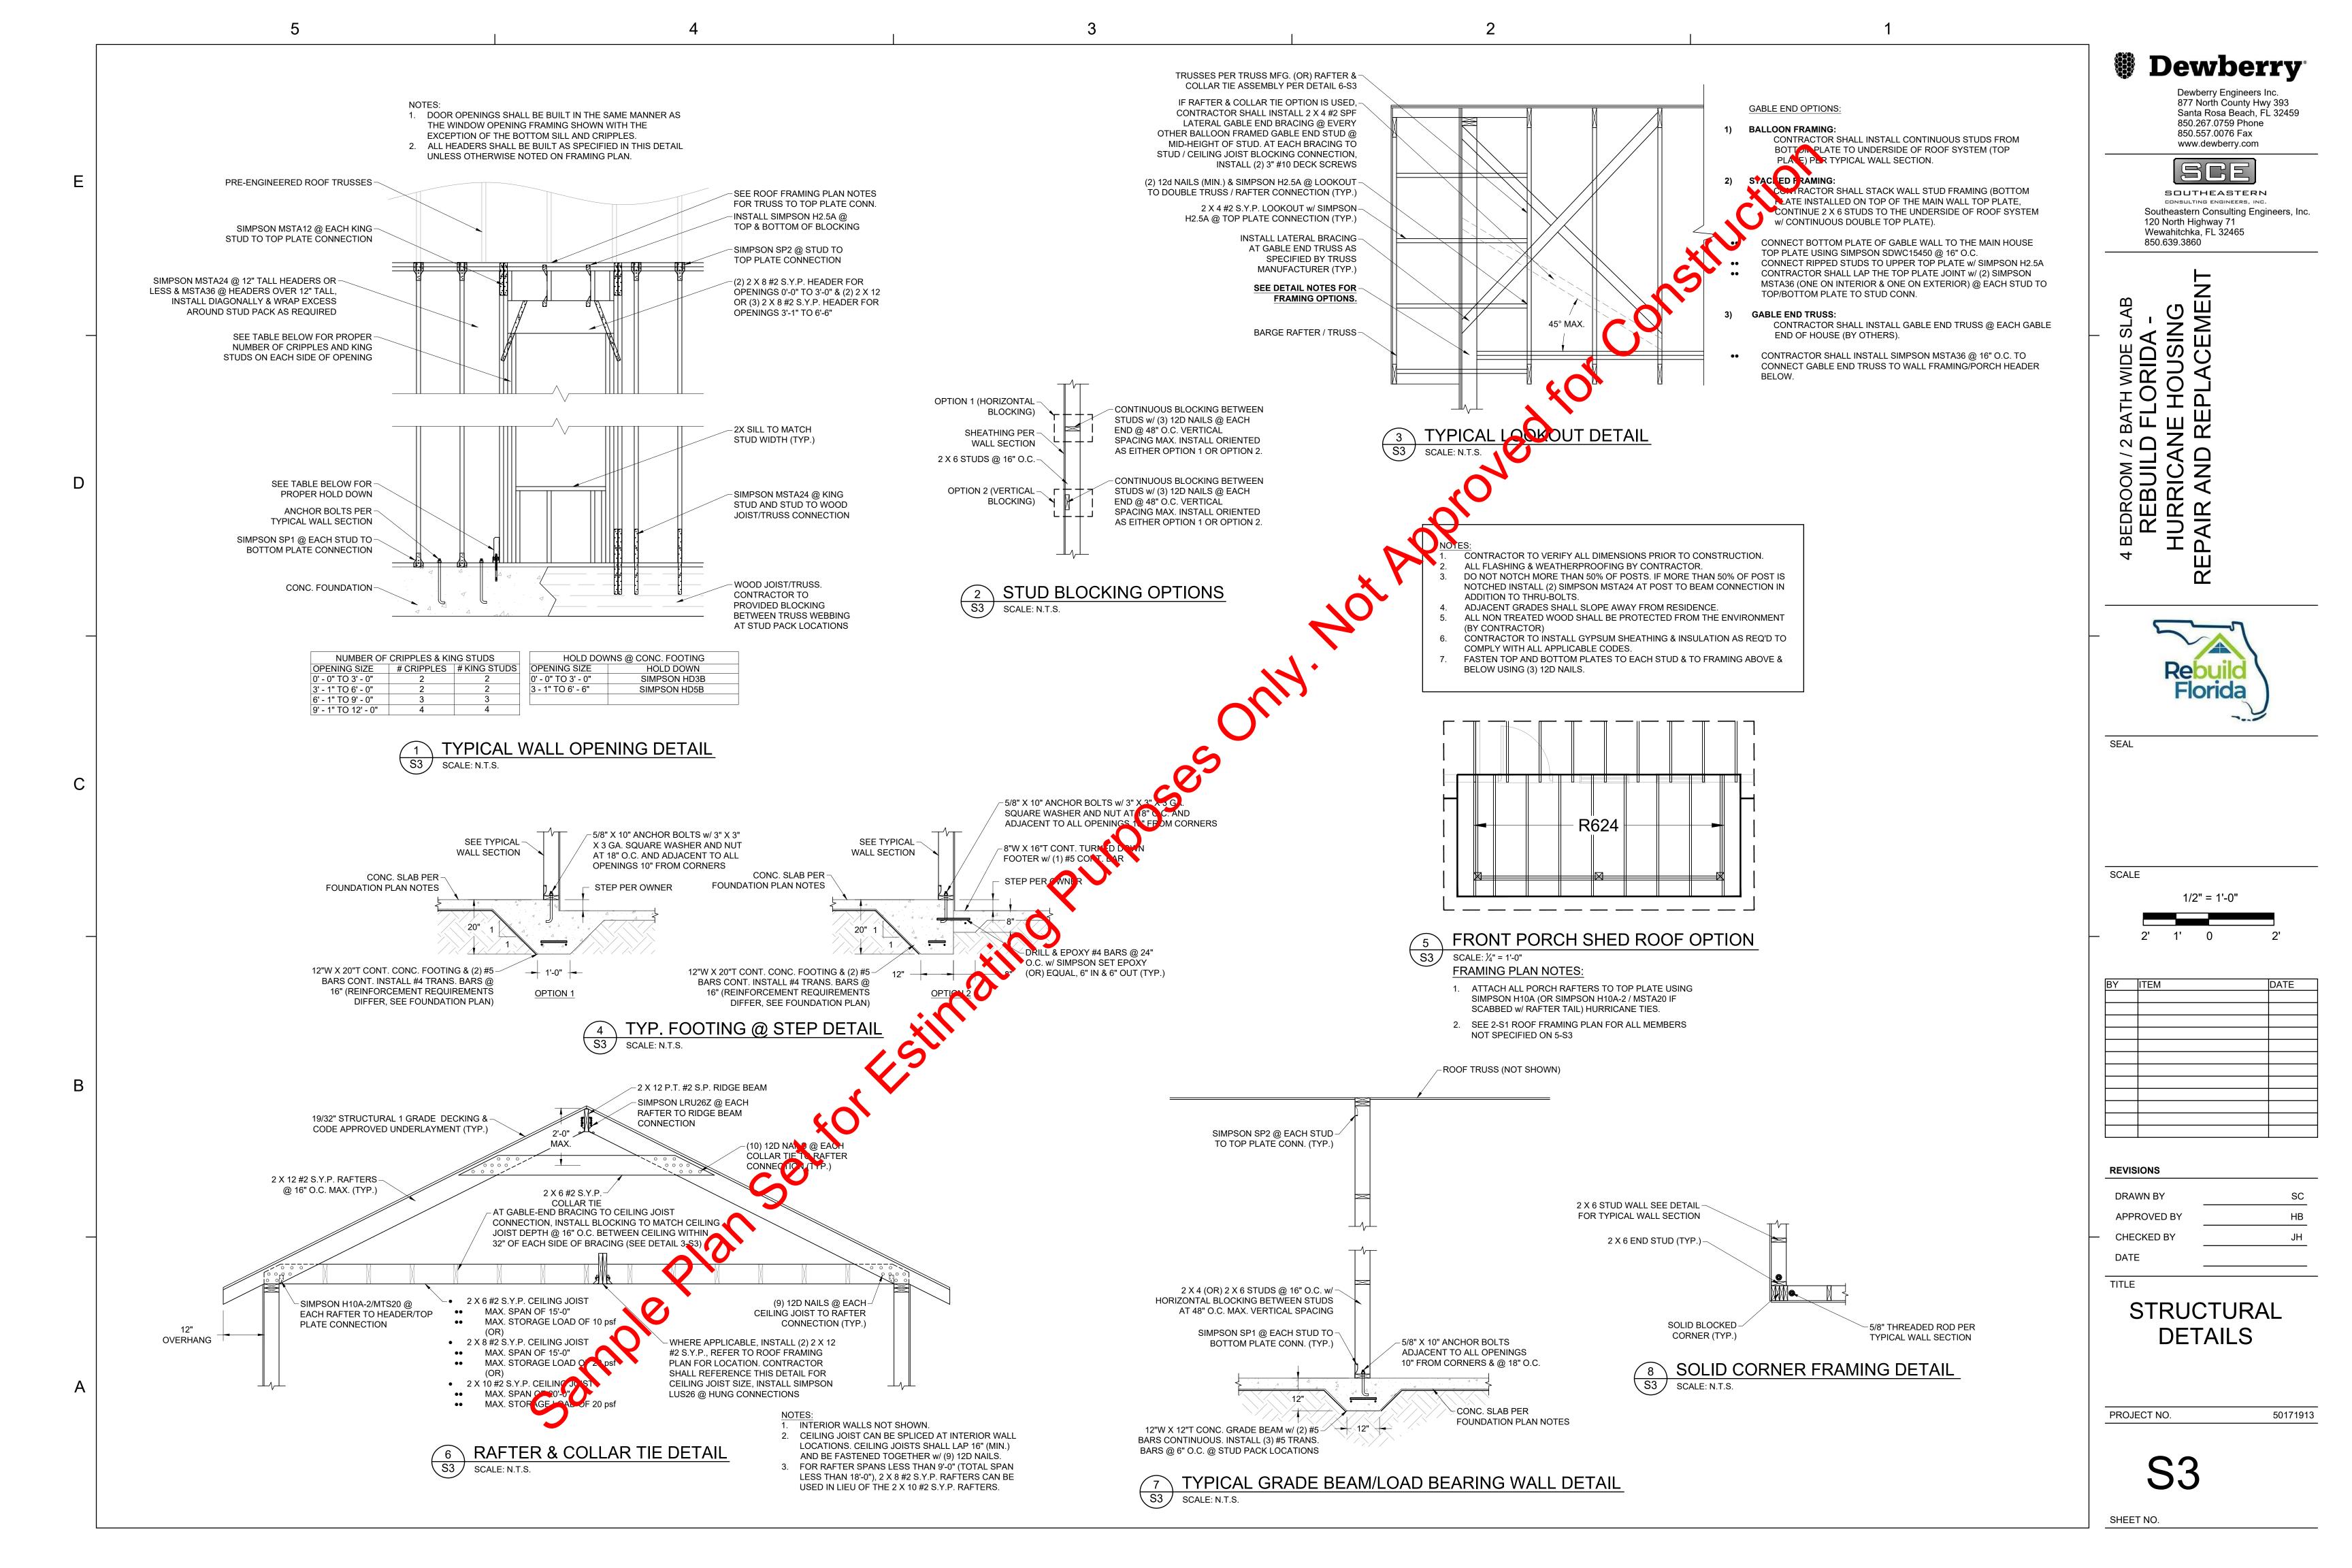

GENERAL

- THE OWNER/CONTRACTOR SHALL VERIFY AND BE RESPONSIBLE FOR ALL FINAL DIMENSIONS, PRIOR TO START THE CONTRACTOR SHALL COORDINATE ARCHITECTURAL, MECHANICAL, ELECTRICAL, PLUMBING, AND CIVIL WORKS DOCUMENTS WITH THE STRUCTURAL CONTRACT DOCUMENTS. NOTIFICATION SHALL BE MADE TO THE ENGINEER OF RECORD OF ANY CONFLICT AND/OR OMISSIONS.
- $3.\quad$ FOR DIMENSIONS NOT SHOWN ON THE STRUCTURAL CONTRACT DOCUMENTS, SEE THE $\,$ ARCHITECTURAL PLANS.
- 4. THE CONTRACTOR SHALL VERIFY EXISTING SITE CONDITIONS, DIMENSIONS, AND ELEVATIONS PRIOR TO STARTING WORK THE ENGINEER SHALL BE NOTIFIED IN WRITING OF ANY DISCREPANCIES IN EXISTING SITE CONDITIONS, DIMENSIONS, OR ELEVATIONS TO THOSE SHOWN IN THE STRUCTURAL CONTRACT DOCUMENTS.
- THE REVIEW OF SUBMITTALS AND/OR SHOP DRAWINGS BY THE ENGINEER DOES NOT RELIEVE THE CONTRACTOR OF THE SOLE RESPONSIBILITY TO REVIEW AND CHECK SHOP DRAWINGS PRIOR TO SUBMITTAL TO THE ENGINEER. THE CONTRACTOR REMAINS SOLELY RESPONSIBLE FOR ERRORS AND OMISSIONS ASSOCIATED WITH THE PREPARATION OF SHOP DRAWINGS AS THEY PERTAIN TO MEMBER SIZES, DETAILS, AND DIMENSIONS SPECIFIED IN THE CONTRACT DOCUMENTS. THE CONTRACTOR ALSO SHALL BE RESPONSIBLE FOR MEANS, METHOD, TECHNIQUES, SEQUENCES, AND PROCEDURES OF CONSTRUCTION INCLUDING BUT NOT LIMITED TO DEMOLITION PROCEDURES AND TEMPORARY SHORING.
- THE CONTRACTOR IS SOLELY RESPONSIBLE FOR THE DESIGN, CONSTRUCTION, AND ERECTION OF SAFE AND ADEQUATE BRACING, SHORING, TEMPORARY SUPPORTS, ETC. REQUIRED FOR STABILITY OF THE STRUCTURE DURING ALL INTERMEDIATE STAGES OF CONSTRUCTION AND/OR DEMOLITION.
- IN NO CASE SHALL STRUCTURAL ALTERATIONS OR WORK AFFECTING A STRUCTURAL MEMBER BE MADE, UNLESS APPROVED BY THE ENGINEER OF RECORD IN WRITING.
- NO PROVISION OF ANY REFERENCED STANDARD SPECIFICATION, MANUAL OR CODE (WHETHER OR NOT SPECIFICALLY INCORPORATED BY REFERENCE IN THE CONTRACT DOCUMENTS) SHALL BE EFFECTIVE TO CHANGE THE DUTIES AND RESPONSIBILITIES OF OWNER, CONTRACTOR, ENGINEER, SUPPLIER, OR ANY OF THEIR CONSULTANTS, AGENTS, OR EMPLOYEES FROM THOSE SET FORTH IN THE CONTRACT DOCUMENTS. NOR SHALL IT BE EFFECTIVE TO ASSIGN TO THE STRUCTURAL ENGINEER OF RECORD OR ANY OF THE STRUCTURAL ENGINEER OF RECORD'S CONSULTANTS, AGENTS, OR EMPLOYEES ANY DUTY OR AUTHORITY TO SUPERVISE OR DIRECT THE FURNISHING OR PERFORMANCE OF THE WORK OR ANY DUTY OR AUTHORITY TO UNDERTAKE RESPONSIBILITIES CONTRARY TO THE PROVISIONS OF THE CONTRACT
- CONTRACT DOCUMENTS INCLUDE, BUT ARE NOT LIMITED TO, THE STRUCTURAL DOCUMENTS (DRAWINGS AND SPECIFICATIONS), BUT DO NOT INCLUDE SHOP DRAWINGS, VENDOR DRAWINGS, OR MATERIAL PREPARED AND SUBMITTED BY THE CONTRACTOR
- 10. REFERENCE TO STANDARD SPECIFICATIONS OF ANY TECHNICAL SOCIETY, ORGANIZATION, OR ASSOCIATION OR TO CODES OF LOCAL OR STATE AUTHORITIES, SHALL MEAN THE LATEST STANDARD, CODE, SPECIFICATION OR TENTATIVE SPECIFICATION ADOPTED AT THE DATE OF TAKING BIDS, UNLESS SPECIFICALLY STATED OTHERWISE
- 11. CONTRACT DOCUMENTS SHALL GOVERN IN THE EVENT OF A CONFLICT WITH THE CODE OF PRACTICE OR SPECIFICATIONS OF ACI, PCI, AISC, SJI OR OTHER STANDARDS. WHERE A CONFLICT OCCURS WITHIN THE CONTRACT DOCUMENTS, THE STRICTEST REQUIREMENT SHALL GOVERN.
- 12. MATERIAL, WORKMANSHIP, AND DESIGN SHALL CONFORM TO THE REFERENCED BUILDING CODE.
- 13. CONTRACTOR SHALL OBTAIN AND COORDINATE EDGE OF SLAB DIMENSIONS, OPENING LOCATIONS AND DIMENSIONS, DEPRESSED SLAB LOCATIONS AND EXTENTS, SLAB SLOPES, CURB LOCATIONS, AND CMU WALL LOCATIONS. ARCHITECT/STRUCTURAL ENGINEER SHALL BE NOTIFIED OF ANY DISCREPANCY OR OMISSION.
- 14. CONTRACTOR HAS SOLE RESPONSIBILITY FOR MEANS, METHODS, SAFETY, TECHNIQUES, SEQUENCES, AND PROCEDURES OF CONSTRUCTION.
- 15. CONTRACTOR HAS SOLE RESPONSIBILITY TO COMPLY WITH ALL OSHA REGULATIONS.
- 16. REPRODUCTION OF STRUCTURAL DRAWINGS FOR SHOP DRAWINGS IS NOT PERMITTED. ELECTRONIC DRAWING FILES WILL NOT BE PROVIDED TO THE CONTRACTOR.
- 17. SUBMIT SHOP DRAWINGS WHICH ADEQUATELY DEPICT THE STRUCTURAL ELEMENTS AND CONNECTIONS SHOWN IN THE CONTRACT DOCUMENTS. SHOP DRAWINGS SHALL BE SEALED BY ENGINEER LICENSED IN THE PROJECT STATE. REVIEW OF SHOP DRAWINGS SHALL BE FOR CONFORMANCE WITH THE CONTRACT DOCUMENTS REGARDING ARRANGEMENT AND SIZES OF MEMBERS AND THE CONTRACTOR'S INTERPRETATION OF THE DESIGN LOADS AND CONTRACT DOCUMENT DETAILS. REVIEW OF SUBMITTALS OR SHOP DRAWINGS BY THE ARCHITECT/STRUCTURAL ENGINEER DOES NOT RELIEVE THE CONTRACTOR OF THE SOLE RESPONSIBILITY TO REVIEW AND CHECK ALL SUBMITTALS AND SHOP DRAWINGS BEFORE SUBMITTING TO THE STRUCTURAL ENGINEER. REVIEW OF SUBMITTALS OR SHOP DRAWINGS BY THE ARCHITECT/STRUCTURAL ENGINEER DOES NOT RELIEVE THE CONTRACTOR OF FULL RESPONSIBILITY FOR COMPLIANCE WITH THE CONTRACT DOCUMENTS. CONTRACTOR REMAINS SOLELY RESPONSIBLE FOR ERRORS AND OMISSIONS ASSOCIATED WITH THE PREPARATION OF SHOP DRAWINGS AS THEY PERTAIN TO MEMBER SIZES, DETAILS, AND DIMENSIONS SPECIFIED IN THE CONTRACT DOCUMENTS. SHOP DRAWINGS SHALL BE SEALED BY ENGINEER LICENSED IN PROJECT STATE.
- 18. WHERE A SECTION OR DETAIL IS SHOWN OR DETAILED FOR ONE CONDITION, IT SHALL APPLY TO ALL SIMILAR AND LIKE CONDITIONS. DETAILS LABELED "TYPICAL" ON THE STRUCTURAL DRAWINGS APPLY TO ALL SITUATIONS OCCURRING ON THE PROJECT THAT ARE THE SAME OR SIMILAR. THE CONTRACTOR SHALL CONSIDER ALL OF THE CONTRACT DOCUMENTS IN DETERMINING SIMILAR AND LIKE CONDITIONS.
- 19. ALL FLASHING AND WATERPROOFING BY CONTRACTOR.
- 20. ALL ADA REQUIREMENTS SHALL BE ADHERED (IF APPLICABLE) TO AND MAY NOT BE SHOWN ON THESE PLANS IN ITS ENTIRETY.
- 21. PLANS DO NOT INCLUDE ANY FIRE ESCAPE PLAN, FIRE SPRINKLER, OR FIRE RELATED DESIGN ASPECTS, U.N.O. OWNER/CONTRACTOR SHALL PROVIDE APPLICABLE FIRE PROTECTION DESIGN/DOCUMENTS NOT SHOWN ON THIS PLAN
- 22. OWNER/CONTRACTOR SHALL BE RESPONSIBLE FOR ALL THRESHOLD INSPECTION REQUIREMENTS (IF APPLICABLE).
- 23. ATTACH STAIR STRINGERS & LANDING FRAMING TO STAIRWELL STUD FRAMING w/ (2) SIMPSON SDWC15600 @ 16" O.C.
- 24. INSTALL LATERAL BRACING AT GABLE END TRUSS AS SPECIFIED BY TRUSS MANUFACTURER

CODE DESIGN

WIND LOADS: SEE TABLE

ESTIMATED DEFLECTIONS (IN INCHES) ARE AS FOLLOWS: LIVE LOAD DEAD + LIVE LOAD ROOF MEMBERS: L/240 OR < 1" L/180 FLOOR MEMBERS: L/360 OR $< \frac{1}{2}$ " L/240

WHERE, L = SPAN LENGTH (IN INCHES) BETWEEN CENTERLINES OF SUPPORTS. (FOR CANTILEVERS, L IS TWICE THE LENGTH OF THE CANTILEVER.)

FOUNDATION

- FOUNDATION DESIGN IS BASED ON AN ASSUMED ALLOWABLE BEARING PRESSURE OF 2000 PSF. STRUCTURAL ENGINEER IS NOT RESPONSIBLE FOR SUBSURFACE CONDITIONS ENCOUNTERED IN THE FIELD DIFFERENT FROM THOSE ASSUMED
- ALL FOUNDATION BEARING SOIL SHALL BE COMPACTED TO 98% STANDARD PROCTOR OR 95% MODIFIED PROCTOR AS SPECIFIED BY AASHTO T-99 AND AASHTO T-180, RESPECTIVELY.
- UNLESS OTHERWISE NOTED, ALL CONSTRUCTION JOINTS SHALL BE CONSTRUCTED w/ 3/4" X 3/4" (MIN.) KEY WAY. ALL SURFACES SHALL BE CLEANED BEFORE PLACEMENT OF ADJACENT CONCRETE. CONTRACTION JOINTS / SAW CUTS SHALL BE INSTALLED AT 10' O.C. EACH WAY OR NO GREATER THAN 30 TIMES THE SLAB THICKNESS (LESSER OF THE TWO) AND SHALL BE A MINIMUM OF 1/8" WIDE AND TO A DEPTH OF 25% OF THE SLAB THICKNESS (MIN.) UNLESS OTHERWISE NOTED. ALL CONCRETE SLABS LOCATED WITHIN VE FLOOD ZONES SHALL BE SCORED IN 25 SQ. FT. SECTIONS (MAXIMUM). REFER TO F.D.E.P. PERMIT DRAWINGS FOR ALL CONCRETE SLABS LOCATED SEAWARD OF THE COASTAL CONSTRUCTION CONTROL LINE.
- 4. STRUCTURAL TESTING/INSPECTION AGENCY SHALL CERTIFY THE BEARING MEDIUM BEFORE STARTING CONSTRUCTION. NO FOOTINGS SHALL BE PLACED IN WATER.
- ANY SOIL CONDITION ENCOUNTERED DURING EXCAVATION THAT IS CONTRARY TO THE CONDITIONS USED FOR DESIGN OF
- FOOTINGS AS OUTLINED IN THESE NOTES OR ON THE DRAWINGS SHALL BE BROUGHT TO THE ATTENTION OF THE ARCHITECT OR ENGINEER OF RECORD BEFORE PROCEEDING.
- BACK FILL BOTH SIDES OF FOUNDATION WALLS AT SAME TIME TO PREVENT OVERTURNING.

CONCRETE MASONRY

- CONCRETE MASONRY WORK SHALL CONFORM TO ACI 530, BUILDING CODE REQUIREMENTS FOR MASONRY STRUCTUR AND ACI 530.1, SPECIFICATION FOR MASONRY STRUCTURES.
- MINIMUM COMPRESSIVE STRENGTH OF CONCRETE MASONRY SHALL BE F'M = 1,500 PSI.
- MORTAR SHALL COMPLY WITH THE BUILDING CODE REQUIREMENTS FOR CONCRETE MASONRY AND SHALI FOLLOWING TYPE:

WALLS BELOW GRADE TYPE M OR S

- I. CONCRETE MASONRY UNITS SHALL BE GROUTED WITH 2,500 PSI COARSE GROUT AS SHOWN IN THE DOCUMENTS. GROUT SHALL CONFORM TO ASTM C476.
- PROVIDE HORIZONTAL JOINT REINFORCEMENT WITH NO. 9 GAGE LONGITUDINAL WIRES AT 16" VERTICALLY, UNLESS NOTED OTHERWISE. PROVIDE SPECIAL ACCESSORIES FOR CORNERS, INTERSECTIONS, ETC.
- MINIMUM VERTICAL WALL REINFORCEMENT SHALL BE #5 @32" UNLESS NOTED OTHERWISE.
- 7. DEFECTIVE AREAS IN CONCRETE INCLUDING, BUT NOT LIMITED TO, HONEY-COMBING, SPALLS, AND CRACKS WITH WIDTHS EXCEEDING 0.01 INCH SHALL BE REPAIRED. EXTENTS OF DEFECTIVE AREA TO BE DETERMINED BY THE STRUCTURAL
- 8. REINFORCING DOWELS MUST BE TIED IN PLACE PRIOR TO POURING FOOTING. "WET-STICKING" IS NOT ALLOWED.

- REINFORCING STEEL SHALL CONFORM TO ASTM A615, GRADE 60, UNLESS NOTED OTHERWISE
- WELDED WIRE FABRIC SHALL CONFORM TO ASTM A185 AND HAVE MINIMUM SIDE AND END LAPS OF 8".FOR ALL MONOLITHIC FOOTINGS, A DOUBLE LAYER OF WELDED WIRE FABRIC SHALL BE INSTALLED WITHIN 3'-0" OF ALL FOOTINGS (3" CLEAR OF OUTSIDE PERIMETER OF FOOTING)
- REINFORCING STEEL SHALL ONLY BE WELDED OR TACK-WELDED IF IT CONFORMS TO ASTM A706, AND AWS D1.4. REINFORCING SHALL NOT BE WELDED NOR TACK-WELDED UNLESS APPROVED BY THE STRUCTURAL
- SUBMIT SHOP DRAWINGS WHICH ADEQUATELY DEPICT THE REINFORCING BAR SIZES AND PLACEMENT WRITTEN DESCRIPTION OF REINFORCEMENT WITHOUT ADEQUATE SECTIONS, ELEVATIONS, AND DETAILS IS NOT ACCEPTABLE.
- PROVIDE DOWELS FROM FOUNDATIONS THE SAME SIZE AND NUMBER AS THE VERTICAL WALL OR COLUMN REINFORCING, UNLESS NOTED OTHERWISE. REINFORCING DOWELS MUST BE TIED IN PLACE PRIOR TO POURING FOOTING. "WET-STICKING" IS NOT ALLOWED.
- PLACE REINFORCEMENT AS FOLLOWS, UNLESS NOTED OTHERWISE

PERMANENTLY EXPOSED TO EARTH


6.1. CAST-IN-PLACE (NON POST-TENSIONED) CONCRETE REINFORCEMENT COVER

CAST AGAINST THE EARTH EXPOSED TO EARTH OR WEATHER: FOR BARS LARGER THAN A NO. 5 BAR 2" CLEAR 1 ½" CLEAR NO. 5 BARS OR SMALLER 1 3/4" CLEAR COLUMN TIES

- 6.2. MASONRY REINFORCING STEEL SHALL BE PLACED IN THE CENTER OF CMU CELLS, UNLESS NOTED OTHERWISE.
- REINFORCEMENT SHALL BE SPLICED ONLY AT LOCATIONS SHOWN OR NOTED IN THE STRUCTURAL DOCUMENTS, EXCEPT REINFORCEMENT MARKED "CONTINUOUS" CAN BE SPLICED AT LOCATIONS DETERMINED BY CONTRACTOR. SPLICES AT OTHER LOCATIONS SHALL BE APPROVED IN WRITING BY THE STRUCTURAL ENGINEER. REINFORCING STEEL SPLICES SHALL BE AS FOLLOWS, UNLESS NOTED OTHERWISE:

MINIMUM LAP SPLICE LENGTH (IN.) - 3000 PSI CONCRETE								
	No. 3	No. 4	No. 5	No. 6	No. 7	No. 8		
	22	29	36	43	63	72		
	MINIMUN	I LAP SPLICE L	ENGTH (IN.) -	1500 PSI NORM	1AL WEIGHT CI	MU		
6-in CMU WALL	19	25	39	81	NA	NA		
8-in CMU WALL	19	25	31	57	79	113		
12-in CMU WALL	19	25	31	53	61	75		

RECOMMENDED END HOOKS ANCHORAGE LENGTH (IN.) - 3000 PSI CONCRETE								
	No. 3	No. 4	No. 5	No. 6	No. 7	No. 8		
D	2.25	3.00	3.75	4.50	5.25	6.00		
A or G	6	8	10	12	14	16		

 

POST INSTALLED ANCHORS POST-INSTALLED ANCHORS SHALL ONLY BE USED WHERE SPECIFIED ON THE CONSTRUCTION DOCUMENTS. THE CONTRACTOR SHALL OBTAIN APPROVAL FROM THE ENGINEER-OF-RECORD PRIOR TO INSTALLING POST-INSTALLED ANCHORS IN PLACE OF MISSING OR MISPLACED CAST-IN-PLACE ANCHORS. CARE SHALL BE

TAKEN IN PLACING POST-INSTALLED ANCHORS TO AVOID CONFLICTS WITH EXISTING REBAR. HOLES SHALL BE DRILLED AND CLEANED IN ACCORDANCE WITH THE MANUFACTURER'S WRITTEN INSTRUCTIONS. SUBSTITUTION REQUESTS FOR PRODUCTS OTHER THAN THOSE SPECIFIED BELOW SHALL BE SUBMITTED BY THE CONTRACTOR TO THE ENGINEER-OF-RECORD ALONG WITH CALCULATIONS THAT ARE PREPARED & SEALED BY A REGISTERED PROFESSIONAL ENGINEER. THE CALCULATIONS SHALL DEMONSTRATE THAT THE SUBSTITUTED PRODUCT IS CAPABLE OF ACHIEVING THE PERTINENT EQUIVALENT PERFORMANCE VALUES (MINIMUM) OF THE SPECIFIED PRODUCT USING THE APPROPRIATE DESIGN PROCEDURE AND/OR STANDARD(S) AS REQ'D BY THE BUILDING CODE. PROVIDE CONTINUOUS SPECIAL INSPECTION FOR ALL MECHANICAL AND ADHESIVE ANCHORS PER THE APPLICABLE EVALUATION REPORT. CONTACT MANUFACTURER'S REPRESENTATIVE FOR THE INITIAL TRAINING AND INSTALLATION OF ANCHORS AND FOR

1.1. CONCRETE ANCHORS

PRODUCT RELATED QUESTIONS AND AVAILABILITY.

- A. MECHANICAL ANCHORS SHALL HAVE BEEN TESTED AND QUALIFIED FOR USE IN ACCORD ACI 355.2 AND ICC-ES AC193 FOR CRACKED AND UNCRACKED CONCRETE RECOGN PRE-APPROVED MECHANICAL ANCHORS INCLUDE: - SIMPSON STRONG-TIE "TITEN-HD" (ICC-ES ESR-2713)
- SIMPSON STRONG-TIE "STRONG-BOLT 2" (ICC-ES ESR-3037) B. ADHESIVE ANCHORS SHALL HAVE BEEN TESTED AND QUALIFIED FOR USE IN ACTORDANCE WITH ACI 355.4 AND ICC-ES AC308 FOR CRACKED AND UNCRACKED CONCRETE NECOGNITION. PRE-APPROVED ADHESIVE ANCHORS INCLUDE: - SIMPSON STRONG-TIE "SET-XP" (ICC-ES ESR-2508)
- SIMPSON STRONG-TIE "AT-XP" (IAPMO-ES ER-0263) - HILTI HIT HY150 INJECTION ADHESIVE - EPCON CERAMIC 6 EPOXY ADHESIVE SUPPLIED BY ITW PAMET/RED HEAD - POWER-FAST EPOXY INJECTION GEL SUPPLIED BY POVERS FASTENING
- C. POWDER AND GAS-ACTUATED FASTENERS SHALL HART BYEN TESTED AND QUALIFIED FOR USE IN ACCORDANCE WITH ICC-ES AC70. PRE-APPROVED TOWLER ACTUATED FASTENERS INCLUDE: - SIMPSON STRONG-TIE "POWER-DRIVEN FASTERERS VICC-ES ESR-2138) - SIMPSON STRONG-TIE "GAS-ACTUATED FASTENERS" (ICC-ES ESR-2811)

2. MASONRY ANCHORS

- 2.1 ANCHORAGE TO SOLID-GROUTED COLCRE M SONRY:
- A. MECHANICAL ANCHORS SHALL HAVE BEEN TESTED AND QUALIFIED FOR USE IN ACCORDANCE WITH ICC-ES AC01 OR AC106. PRE-APPROJED MECHANICAL ANCHORS INCLUDE: - SIMPSON STRONG-TIE "TITE -HD" (ICC-ES ESR-1056)
- SIMPSON STRONG-TIE "STRONG-BOLT 2" (IAMPO-ES ER-0240)
 SIMPSON STRONG-TIE "WELGE-ALL" (ICC-ES ESR-1396)
- B. ADHESIVE ANCHORS HALL AVE BEEN TESTED AND QUALIFIED FOR USE IN ACCORDANCE WITH ICC-ES AC58. PRE-APPR VED MECHANICAL ANCHORS INCLUDE:
 - SIMPSON STROGG-TIE "AT-XP" (IAMPO-ES ER-0281)
- SIMPSON STRONG TIE "SET-XP" (IAMPO-ES ER-0265) HILTI HIT H (15) NJECTION ADHESIVE
- EPCON CERVIN 6 EPOXY ADHESIVE SUPPLIED BY ITW RAMSET/RED HEAD POVER ANT EPOXY INJECTION GEL SUPPLIED BY POWERS FASTENING
- ANCHORAGE TO HOW OW CONCRETE MASONRY:
- 3.1 ADESIVE ANCHORS WITH SCREEN TUBES SHALL BE TESTED AND QUALIFIED IN ACCORDANCE WITH S AC58 OR AC60, AS APPROPRIATE. THE APPROPRIATE SCREEN TUBE SHALL BE USED AS MENDED BY THE ADHESIVE MANUFACTURER. PRE-APPROVED ADHESIVE ANCHORS WITH

SIMPSON STRONG-TIE "SET" (ICC-ES ESR-1772) SIMPSON STRONG-TIE "AT" (ICC-ES ESR-1958)

- HILTI HIT HY150 INJECTION ADHESIVE - EPCON CERAMIC 6 EPOXY ADHESIVE SUPPLIED BY ITW RAMSET/RED HEAD - POWER-FAST EPOXY INJECTION GEL SUPPLIED BY POWERS FASTENING
- ALL DRILLED & EPOXIED 5/8" THREADED RODS SHALL MAINTAIN A MINIMUM EDGE DISTANCE OF 1 3/4" AND CLEAR SPACING OF 4" O.C. (MAX.)

CAST-IN-PLACE CONCRETE

- ALL CONCRETE HAS BEEN DESIGNED IN ACCORDANCE WITH ACI 318 AND SHALL BE CONSTRUCTED IN
- 2. UNLESS NOTED OTHERWISE, ALL CONCRETE SHALL HAVE A 28 DAY COMPRESSIVE STRENGTH OF 3000 PSI. 3. REFER TO ARCHITECTURAL DRAWINGS FOR MOLDS, GROVES, ORNAMENTS, CLIPS OR GROUNDS REQUIRED
- TO BE ENCASED IN CONCRETE AND FOR LOCATION OF FLOOR FINISHES AND SLAB DEPRESSIONS. 4. CONSTRUCTION JOINT LOCATIONS SHALL BE APPROVED BY THE STRUCTURAL ENGINEER. NO HORIZONTAL

CONSTRUCTION JOINTS ARE PERMITTED EXCEPT THOSE SHOWN ON THE STRUCTURAL DRAWINGS.

DEFECTIVE AREAS IN CONCRETE INCLUDING, BUT NOT LIMITED TO, HONEY-COMBING, SPALLS, AND CRACKS WITH WIDTHS EXCEEDING O.O1 INCH SHALL BE REPAIRED. EXTENT OF DEFECTIVE AREA TO BE DETERMINED BY THE STRUCTURAL ENGINEER.

- 1. ALL HEADERS, BEAMS, POSTS, ETC. HAVE BEEN DESIGNED TO SUPPORT ROOF FRAMING MEMBERS AS SHOWN ON ROOF FRAMING PLAN. IT IS THE RESPONSIBILITY OF THE TRUSS MFG. TO NOTIFY E.O.R. OF ANY DISCREPANCY & PROVIDE FINAL TRUSS LAYOUT TO E.O.R. FOR STRUCTURAL PLAN REVISION IF LAYOUT VARIES FROM THAT SHOWN ON THIS PLAN SET.
- 1.1. ALL DECK JOISTS HEREIN SHOWN AS 16" O.C. OR GREATER ARE INTENDED FOR 2 X 6 OR 5/4 X 6 WOOD DECKING. IT IS THE CONTRACTORS RESPONSIBILITY, IF USING COMPOSITE DECKING TO INSTALL DECK JOISTS @ 12" O.C. OR AS REQUIRED BY MANUFACTURERS
- STRUCTURAL GLUED LAMINATED TIMBER SHALL BE PRODUCED IN ACCORDANCE WITH THE AMERICAN INSTITUTE OF TIMBER CONSTRUCTION (AITC). MINIMUM ALLOWABLE BENDING STRESS SHALL BE 2,400 PSI (DRY CONDITIONS).
- PROVIDE DRESSED SEASONED LUMBER, S4S, WITH A MAXIMUM MOISTURE CONTENT OF 19%
- 3.1. INTERIOR AND EXTERIOR LOAD-BEARING WALLS: SPRUCE PINE FUR (SPF) U.N.O.

SOUTHERN PINE (S.P.), NO. 2 GRADE.

3.2. LINTELS, FLOOR JOISTS AND BEAMS:

AT TIME OF DRESSING AS LISTED BELOW.

- 3.3. WOOD IN CONTACT WITH CONCRETE OR MASONRY SHALL BE FOUNDATION GRADE PRESSURE-TREATED. USE GALVANIZED NAILS IN PRESSURE-TREATED WOOD. THE PROTECTIVE COATING ON LIGHT GAUGE STEEL CONNECTIONS IN CONTACT W/ PRESSURE-TREATED WOOD SHALL BE IN ACCORDANCE WITH THE CONNECTOR MANUFACTURERS RECOMMENDATIONS.
- 4. ENGINEERED LUMBER PRODUCTS
- 4.1. PARALLEL STRAND LUMBER (PSL) SHALL HAVE THE FOLLOWING MINIMUM ALLOWABLE STRESSES AND PROPERTIES:

ALLOWABLE BENDING STRESS COMPRESSION PERPENDICULAR TO GRAIN $F_{C\perp} = 750 \text{ PSI}$ COMPRESSION PARALLEL TO GRAIN $F_{all} = 2900 \, PSI$ $F_V = 290 PSI$ MODULUS OF ELASTICITY E = 2,000,000 PSI

4.2. LAMINATED VENEER LUMBER (LVL) SHALL HAVE THE FOLLOWING MIN

STRESSES AND PROPERTIES: $F_B = 2600 PSI$ ALLOWABLE BENDING STRESS COMPRESSION PERPENDICULAR TO GRAIN For = 750 PSCOMPRESSION PARALLEL TO GRAIN HORIZONTAL SHEAR

COMPRESSION PARALLEL TO GRAIN

HORIZONTAL SHEAR

HORIZONTAL SHEAF

- MODULUS OF ELASTICITY 2.000.000 PSI 4.3. LAMINATED STRAND LUMBER (LSL) SHALL HAVE THE FOLLOWING MINIMUM ALLOWABLE STRESSES AND PROPERTIES: ALLOWABLE BENDING STRESS COMPRESSION PERPENDICULAR TO GRAM
- MODULUS OF ELASTICITY E = 1,300,000 PSI4.4. GLULAM BEAMS (GLU) SHALL HAVE THE FOLLOWING MINIMUM ALLOWABLE STRESSES AND PROPERTIES: ALLOWABLE BENDING COMPRESSION PERPENDICULAR TO GRAIN = 805 PSI TENSION PARALLEL TO GRAIN = 1350 PSI

 $F_V = 425 \, PSI$

= 300 PSI

- MODULUS OF ELASTICITY E = 2,100,000 PSI4.5. PRESERVED GEVILAM BEAMS (GLU) SHALL HAVE THE FOLLOWING MINIMUM ALLOWABLE STRESSEY ALLO PROPERTIES:
- ALLOWABLE BENDING STRESS COMPLESSION PERPENDICULAR TO GRAIN $F_{C^{\perp}} = 740 \text{ PSI}$ $F_V = 300 PSI$ HORIZONTAL SHEAR US OF ELASTICITY E = 1,800,000 PSSTRUCTURAL PANELS
- OOR PANELS SHALL BE CONSTRUCTED WITH TONGUE AND GROOVE APA RATED 3/4" PLYWOOD. FLOOR PANELS SHALL BE GLUED AND NAILED w/ 8d RING SHANK NAILS @4" O.C. AT PANEL EDGES AND AT 6" O.C. IN THE FIELD.
- 5.2. WALL PANELS SHALL BE CONSTRUCTED WITH APA RATED SHEATHING. SHEATHING SHALL BE ATTACHED WITH 8d COMMON NAILS @3" O.C. AT PANEL EDGES AND 6" O.C. IN
- THE FIELD. ALL PANEL EDGES SHALL BE BLOCKED. 5.3. ROOF PANELS SHALL BE CONSTRUCTED WITH APA RATED SHEATHING. SHEATHING SHALL BE ATTACHED WITH 8d RING SHANK NAILS @ 3" O.C. AT PANEL EDGES AND AT 6" O.C. IN THE FIELD. ALL PANEL EDGES SHALL BE BLOCKED OR ATTACHED WITH SIMPSON
- PSCA PANEL SHEATHING CLIPS. 5.4. NAIL HEADS SHALL NOT PENETRATE THE OUTER SURFACE OF SHEATHING.
- 6. FABRICATED WOOD TRUSSES
- 6.1. DESIGN OF WOOD TRUSSES SHALL BE THE SOLE RESPONSIBILITY OF THE CONTRACTOR, SUBMIT SHOP DRAWINGS, DESIGN LOAD DATA, AND SUPPORT REACTIONS SEALED BY AN ENGINEER LICENSED IN THE PROJECT STATE. REVIEW OF SHOP DRAWINGS SHALL BE FOR CONFORMANCE WITH THE CONTRACT DOCUMENTS WITH REGARD TO TRUSS CONFIGURATION, AND THE CONTRACTOR'S INTERPRETATION OF DESIGN LOADS AND DETAILS. SUCH REVIEW SHALL NOT RELIEVE THE CONTRACTOR OF THE FULL RESPONSIBILITY FOR THE DESIGN OF THE TRUSSES OR TRUSS
- CONNECTIONS NOT SPECIFICALLY DETAILED IN THE CONTRACT DOCUMENTS. 6.2. ERECTION AND BRACING OF PREFABRICATED WOOD TRUSSES SHALL BE IN CONFORMANCE WITH THE RECOMMENDATIONS OF THE TRUSS MANUFACTURER AND THE TRUSS PLATE INSTITUTE'S "BRACING WOOD TRUSSES: COMMENTARY AND RECOMMENDATIONS"
- 6.3. SECURE EACH COMMON ROOF TRUSS/RAFTER TO TOP PLATE WITH SIMPSON H-10 OR H-7 HURRICANE CLIP AT ALL BEARING POINTS. USE SIMPSON H-7 AT GIRDER TRUSSES.
- PROVIDE A MINIMUM OF TWO STUDS UNDER GIRDER TRUSS END BEARING. 6.4. TRUSSES ON SITE PRIOR TO INSTALLATION SHALL BE STORED IN A VERTICAL POSITION WITH SUPPORT POINTS PROVIDED AT FINAL BEARING POINTS AND BRACED TO AVOID
- 6.5. INSTALLATION OF ALL TRUSSES SHALL BE DONE USING A SPREADER BAR WITH A THREE POINT VERTICAL PICK AND CARE IS TO BE USED IN LIFTING TO MINIMIZE HORIZONTAL BENDING.
- 6.6. IMPROPER HANDLING OF THE TRUSSES AS NOTED ABOVE AND IN THE SPECIFICATIONS SHALL MEAN REMOVAL OF THE TRUSSES FROM THE JOB SITE.
- 6.7. TRUSS TO TRUSS CONNECTIONS SHALL BE VERIFIED BY THE TRUSS DESIGNER. 6.8. EXPOSED TRUSSES SHALL BE DELIVERED TO THE JOB SITE UNBLEMISHED AND SUITABLE FOR FIELD PAINTING.
- 6.9. CONTRACTOR TO REFER TO "STANDARD FOR HURRICANE RESISTANT CONSTRUCTION SSTD 10-99 FOR FRAMING REQUIREMENTS OF WOOD FRAMED WALL SYSTEMS, TABLE 305C AND FIGURE 306D.
- 6.10. ALL FLOOR TRUSS DESIGN LOADS SHALL BE PER TRUSS MANUFACTURER. THE LOADS REFERENCED WITHIN THE FOLLOWING "STRUCTURAL LOADS" SECTION REPRESENTS THE LOADS USED FOR THE DESIGN OF STRUCTURAL MEMBERS SUPPORTING FLOOR AND ROOF TRUSSES.
- CONNECTIONS
- 7.1. CONNECTIONS FOR STRUCTURAL TIMBER SHALL BE GALVANIZED STRONG TIE CONNECTORS BY THE SIMPSON COMPANY OR APPROVED EQUAL. CONNECTORS SHALL FOLLOW MANUF. CORROSION PROTECTION RECOMMENDATIONS.
- 7.2. THE NUMBER OF FASTENERS PER CONNECTION SHALL BE THE MAX. ALLOWED FOR THAT PARTICULAR FASTENER.

STRUCTURAL LOADS:

SUPERIMPOSED DEAD LOADS (RESIDENTIAL CONSTRUCTION): FLOOR PORCH 10 PSF

15 PSF SUPERIMPOSED LIVE LOADS (RESIDENTIAL CONSTRUCTION) ATTICS w/ STORAGE ATTICS w/o STORAGE HABITABLE ATTICS & BEDRO 40 PSF ALL OTHER ROOMS 40 PSF DECKS 60 PSF

FLOOR ROOF 20 PSF


124 MPH SURE CATEGORY ITERNAL PRESSURE COEFFICIENT 0.18 ± ▲IMPACT GLASS WINDOWS & DOORS


MAIN WIND FRAME RESISTING SYSTEM (MWFRS)						
AREA	INTERIOR ZONE	END ZONE				
WALLS	38.64 PSF	48.30 PSF				
ROOF	± 32.69 PSF	± 40.86 PSF				

40 PSF

COMPONENTS AND CLADDING ROOF PRESSURES (PSF)								
ZONE			+ GCpi			- GCpi		
ROOF (ZONE 1)			26.98			-58.12		
ROOF (ZONE 2)				26.98			-92.71	
ROOF (ZONE 3)				26.98		110.01		
		COMPON	ENTS AND	CLADDING \	WALL PRES	SURES (PS	F)	
	0 SF	- 10 SF	10 SF - 30 SF 30 S		30 SF	- 60 SF	60 SF - 100 SF	
ZONE	+ GCpi	- GCpi	+ GCpi	- GCpi	+ GCpi	- GCpi	+ GCpi	- GCpi
4 40.82 -44.28		40.82	-44.28	37.91	-41.37	36.07	-39.53	
5	40.82	-54.66	40.82	-54.66	37.91	-48.83	36.07	-45.15

NOTE: ALL PRESSURES SHOWN ARE BASED UPON ASD DESIGN, WITH A LOAD FACTOR OF 0.6.

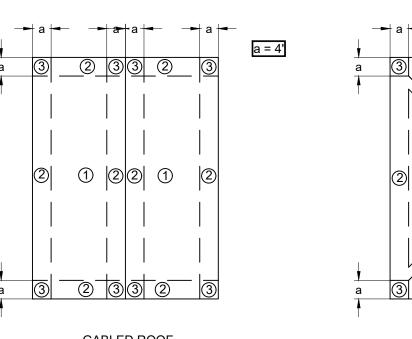

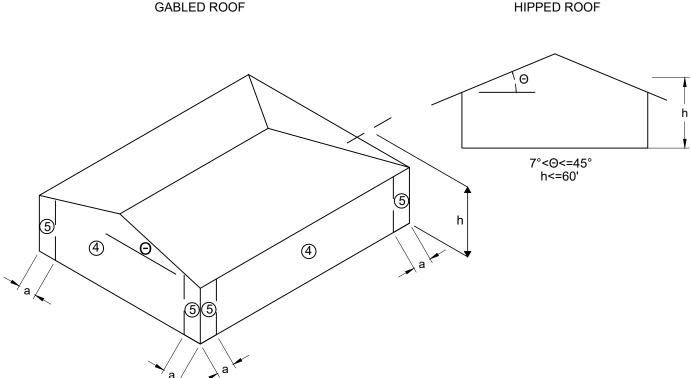

THE STRUCTURE SHOWN ON THESE PLANS IS DESIGNED IN ACCORDANCE WITH FLORIDA BUILDING CODE 8TH EDITION (2023).

E.O.R. = ENGINEER OF RECORD

ABBREVIATIONS

CONC. = CONCRETE WWM = WELDED WIRE MESH CONT. = CONTINUOUS CMU = CONCRETE MASONRY UNIT P.T. = PRESSURE TREATED N.T.S. = NOT TO SCALE BTW = BETWEEN SIM = SIMILAR

> CONT. = CONTINUOUS ~~~~~

N.T.S. = NOT TO SCALE BTM. = BOTTOM C.I.P. = CAST IN PLACE S.S. = STAINLESS STEEL TYP. = TYPICAL REQ'D = REQUIRED U.N.O. = UNLESS NOTED OTHERWISE LOC = LOCATION L.B.W. = LOAD BEARING WALL

HCA = HEADED CONCRETE ANCHOR MFG. = MANUFACTURER

SHEARWALL/SHEATHING NAIL SCHEDULE (U.N.O.) 3" O.C. EDGE WALLS 8d (0.131" x 2-1/2") 6" O.C. FIELD 3" O.C. EDGE 8d "RING SHANK" (0.131" X 2-1/2") 6" O.C. FIELD TONGUE & GROOVE SHEATHING, IF APPLICABLE (U.N.O.) WALLS (2) 3" #9 DECK SREWS EACH STUD CONN. EACH TRUSS/RAFTER CONN (2) 3" #9 DECK SREWS

877 North County Hwy 393 Santa Rosa Beach, FL 32459 850.267.0759 Phone 850.557.0076 Fax www.dewberry.com

SOUTHEASTERN CONSULTING ENGINEERS, INC Southeastern Consulting Engineers, Inc. 120 North Highway 71 Wewahitchka, FL 32465 850.639.3860

 O OM C



SCALE

SEAL

REVISIONS DRAWN BY APPROVED B

STRUCTURAL **GENERAL NOTES**

PROJECT NO. 50171913


SHEET NO.

CHECKED B

PER SECTION 471.003(2)(H), F.S., ALL MECHANICAL, ELECTRICAL, AND PLUMBING **GENERAL NOTES** ARE EXEMPT FROM PROFESSIONAL ENGINEERING SERVICES FOR THIS PROJECT. IT IS THE RESPONSIBILITY OF THE CONTRACTOR TO PERMIT AND **PLUMBING NOTES:** CONSTRUCT THE APPLICABLE SYSTEM IN ACCORDANCE WITH FLORIDA BUILDING CODE, LOCAL CODE REQUIREMENTS AND PROGRAMMATIC FOR PERMITTING TO THE AUTHORITY HAVING JURISDICTION.
PLUMBING CONTRACTOR SHALL BE LICENSED AND RESPONSIBLE TO MEET ALL APPLICABLE
REQUIREMENTS OF THE FLORIDA BUILDING CODE AND THE LOCAL CODE REQUIREMENTS OF THE
JURISDICTION WHERE THE PROJECT WILL BE LOCATED. REQUIREMENTS. IT IS THE RESPONSIBILITY OF THE CONTRACTOR TO PERMIT THE PROJECT WITH ALL AUTHORITIES HAVING JURISDICTION (AHJ). INFORMATION SHOWN PROVIDES MINIMUM PROGRAMMATIC REQUIREMENTS ALL PLUMBING FIXTURES AND PIPING MATERIALS AND ASTALLATION SHALL CONFORM TO THE LOCAL AND ARE GENERAL IN NATURE. DRAWINGS ARE SCHEMATIC IN NATURE AND PLUMBING CODES. INSULATE ALL PIPING AS REQUIRE BY THE FLORIDA WILDING CODE.
USE WATER-CONSERVING FIXTURES MEETING THE FOLLOWING WATERSENSE REQUIREMENTS: FINAL PERMITTING AND CONSTRUCTION OF THE SYSTEM IS THE TOILETS = 1.28 GPF RESPONSIBILITY OF THE CONTRACTOR. ALL EQUIPMENT AND PRODUCTS SHALL b. SHOWER HEADS = 2.0 GPM
c. KITCHEN FAUCETS = 2.0 GPM
d. BATHROOM FAUCETS = 1.5 CPM
e. WATER CLOSETS MUST LINVE A MINIMUM MAP RATING OF 600 GRAMS PER FLUSH.
COORDINATE FIXTURES AND LICCHONS WITH ARCHITECTURAL PLANS AND OWNER.
PROVIDE SERVICE CONNECTIONS TO THE LOCAL UTILITY THAT COMPLY WITH THE SERVICE AUTHORITY'S REQUIREMENTS.
COORDINATE HOT WATER HISATER LOCATION AND PROVIDE PLASTIC DRAIN/DRIP PAN WITH DRAIN TO THE BUILDING EXTER OR IN A CONSPICUOUS LOCATION. WATER HEATER SHALL BE MINIMUM 50 GALLON CAPACATY AND ENERGY STAR LISTED.
COORDINATE LOSE BOB LOCATIONS (MINIMUM OF 2 EXTERIOR HOSE BIBBS SHALL BE PROVIDED). PROVIDE "NO-DRIP" SUPPLY/DRAIN AT WASHING MACHINE.
PROVIDE ACCESS LANELS TO TUB/SHOWER PLUMBING LINES/VALVE.
PERFORMALL REQUIRED TESTS PRIOR TO INSTALLING PIPE INSULATION, BACKFILLING, OR INSTALLING SHOWER HEADS = 2.0 GPM BE SELECTED BY THE CONTRACTOR. PERFORMALL REQUIRED TESTS PRIOR TO INSTALLING PIPE INSULATION, BACKFILLING, OR INSTALLING DRYWALL PROVIDE A LL CLEAN-OUTS, EXPANSION TANKS, VACUUM BREAKERS, AND OTHER MISCELLANEOUS COMPONENTS REQUIRED FOR A COMPLETE AND FUNCTIONAL SYSTEM WHETHER SHOWN ON DRAWINGS OR NOT. PROVIDE SHUT-OFF VALVES TO ALL FIXTURES. AND GROUPS SHALL BE VENTED IN ACCORDANCE WITH THE CURRENT VERSION OF THE FLORIDA ROUTING PIPE THROUGH BUILDING FOOTINGS. WHERE CONFLICTS ARE UNAVOIDABLE, ROUTE PIPING A MINIMUM OF 12" BELOW FOOTING. HOT- AND COLD-WATER SUPPLY PIPING SHALL BE CPVC WITH APPROVED FITTINGS. PLUMBING CONSTRUCTION DRAWINGS SHALL INDICATE THE LOCATION OF CLEAN-OUTS AND AUTHORITY HAVING JURISDICTION. ELECTRICIAN FOR INSTALLATION. -USE PIPE BOOT @ ALL ROOF PENETRATIONS (TYP) 1 1/2"— 2" KITCHEN SINK __2" LAV co) FIRST FLOOR 4" -SLOPE **RISER DIAGRAM** NOT TO SCALE

- PLUMBING CONSTRUCTION DOCUMENTS SHALL BE SUBMITTED BY THE PLUMBING SUBCONTRACTOR

- L PENETRATIONS THROUGH THE ROOF SHALL BE FLASHED AND SEALED USING PREFORMED
- PLUMBING SUBCONTRACTOR SHALL PROVIDE AND INSTALL DRAIN PIPING FOR ALL HVAC EQUIPMENT.
 DISCHARGE TO GRADE. DO NOT CONNECT TO SANITARY PIPING. ALL DRAIN LINES SHALL HAVE WATER SEAL TRAPS AS REQUIRED BY CODE. ALL PLUMBING FIXTURES
- ALL SANITARY SEWER PIPING SHALL BE SOLID-CORE, SCHEDULE 40 PVC DWV PIPE WITH APPROPRIATE FITTINGS. MINIMUM SLOPE OF THE SANITARY SEWER PIPING SHALL BE MAINTAINED PER CODE. AVOID
- CONNECTIONS TO EXISTING UTILITIES INCLUDING WATER AND SANITARY SEWER FOR REVIEW BY THE
- KITCHEN SINK TO HAVE ENERGY STAR GARBAGE DISPOSAL. PLUMBER SHALL COORDINATE WITH
- HOT & COLD WATER PIPING AND SANITARY DRAIN TRAPS SHALL NOT BE INSTALLED IN ANY LOCATION

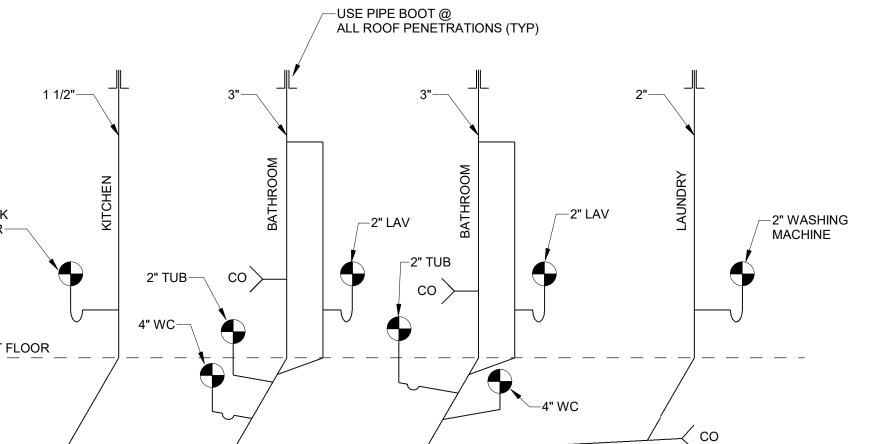



Dewberry

Dewberry Engineers Inc. 877 North County Hwy 393

850.267.0759 Phone

850.557.0076 Fax

www.dewberry.com

Santa Rosa Beach, FL 32459

SEAL

SCALE

As indicated

DRAWN BY APPROVED BY CHECKED BY

GENERAL INFORMATION 4BR WIDE

PROJECT NO.

P0.1

50171913

GENERAL NOTES

HVAC NOTES:

HVAC CONSTRUCTION DOCUMENTS SHALL BE SUBMITTED BY THE HVAC SUBCONTRACTOR FOR PERMITTING TO THE AUTHORITY HAVING JURISDICTION.

HVAC CONTRACTOR SHALL BE LICENSED AND RESPONSIBLE TO MEET ALL APPLICABLE REQUIREMENTS OF THE FLORIDA BUILDING CODE AND THE LOCAL CODE REQUIREMENTS OF THE JURISDICTION WHERE THE PROJECT WILL BE

THE HVAC DRAWINGS ARE SCHEMATIC IN NATURE. THE TWO CONTRACTOR SHALL PROVIDE ALL EQUIPMENT AND COMPONENTS REQUIRED FOR A COMPLETE AND FUNCTIONAL SYSTEM WHETHER SHOWN ON THE DRAWINGS OR NOT. THESE COMPONENTS MAY INCLUDE, BUT SHALL NOT BE LIMITED TO:

ALL AIR CONDITIONING EQUIPMENT **EXHAUST FANS** DUCTWORK INCLUDING SUPPLY RETURN **EXHAUST** VENTILATION AIR DISTRIBUTION DEVICE INCLUDING:

SUPPLY DIFFUSERS AND REGISTERS

RETURN GRADE DAMPERS LOV VERS ROOF AND WALL CAPS AIR FILTRATION (MERV 8 MINIMUM)

THERMOSTATS, TIMERS, AND WIRING

EQUIPMENT SUPPORTS, HANGERS, AND BRACING

h. COME NOATE DRAIN PANS, OVERFLOW SWITCHES, AND PIPING CONSTRUCTION DRAWINGS SHALL BE BASED ON THE LOCATION AND ORIENTATION OF THE PROPOSED SITE. HVAC SYSTEM STAYL BE SIZED BASED ON ACCA MANUAL J AND S, LATEST EDITION. CONTRACTOR SHALL PROVIDE

ALCULATION FOR EACH SITE. C UNITS SHALL BE MINIMUM OF 16 SEER.

ALL DUCTS AND PLENUMS SHALL BE MADE AIR TIGHT. SEAL ALL DUCT SEAMS USING TAPE AND MASTIC OVER JOINTS. ONSTRUCT AND INSTALL DUCTWORK IN COMPLIANCE WITH THE FLORIDA BUILDING CODE, LATEST EDITION. MAXIMUM DUCT LEAKAGE SHALL NOT EXCEED 5% OF RATED AIFLOW. OR AS REQUIRED BY LOCAL CODES. PROTECT OPEN DUCTS DURING CONSTRUCTION TO MINIMIZE DUST AND DEBRIS USING BLUE MAX OR EQUAL DUCT

CONSTRUCT DUCTWORK FROM RIGID DUCT BOARD AND BRANCHES FROM FLEX DUCT TO THE LATEST SMACNA REQUIREMENTS FOR THE PRESSURE CLASS REQUIRED. MAXIMUM LENGTH OF FLEX DUCT SHALL BE 5'. THE HVAC CONTRACTOR SHALL DESIGN THE DUCT SYSTEM BASED ON ACCA MANUAL D, LATEST EDITION. INSULATE

DUCTWORK AS REQUIRED BY FLORIDA BUILDING CODE BUT NOT LESS THAN R-6. FLEXIBLE DUCTS SHALL BE EXTENDED FULLY. EXCESS DUCT MATERIAL SHALL BE LIMITED TO LESS THAN 5%. INSTALL FLEXIBLE DUCT PER MANUFACTURER'S RECOMMENDATIONS INCLUDING JOINING, SEALING, LIMITATIONS OF

SAG, AND SUPPORTING. INSTALL BALANCING DAMPERS AT EACH DUCT TAKE-OFF.

INSTALL FIRE AND SMOKE DAMPERS WHERE REQUIRED BY LOCAL CODES AND ASSEMBLY PENETRATIONS.

INSTALL SMOKE DETECTORS WHERE REQUIRED BY LOCAL CODES.

PLUMBING SUBCONTRACTOR SHALL PROVIDE A MEANS OF CONDENSATE DISPOSAL FOR EACH PIECE OF HVAC EQUIPMENT CONTAINING AN EVAPORATOR COIL.

CONDENSATE DISPOSAL SYSTEM SHALL BE DESIGNED AND INSTALLED IN ACCORDANCE WITH THE FLORIDA BUILDING CODE AND LOCAL CODES.

PRIMARY AND SECONDARY CONDENSATE PIPING SHALL BE SCHEDULE 40 PVC. PRIMARY CONDENSATE PIPING LOCATED WITHIN THE BUILDING ENVELOPE SHALL BE INSULATED USING 3/4" CLOSED

ALL CONDENSATE DISPOSAL PIPING SHALL BE TESTED DURING HVAC EQUIPMENT STARTUP.

SPLIT-SYSTEM HEAT PUMP EQUIPMENT:

HEAT PUMP AND AIR-HANDLING UNIT SHALL BE INSTALLED IN ACCORDANCE WITH THE FLORIDA BUILDING CODE AND

HEAT PUMP, AT A MINIMUM, SHALL BE LOCATED 2' ABOVE THE 100-YEAR FLOOD LEVEL AND SHALL BE SUPPORTED

AND TIED DOWN AS REQUIRED BY THE FLORIDA BUILDING CODE USING APPROVED HURRICANE STRAPS. THE MANUFACTURER'S RECOMMENDED CLEARANCES SHALL BE MAINTAINED ON ALL SIDES OF HEAT PUMP AND AIR-

HEAT PUMP AND AIR-HANDLING UNITS SHALL BE INSTALLED PER THE MANUFACTURER'S RECOMMENDATIONS AND IN

COMPLIANCE WITH ALL EPA AND LOCAL REQUIREMENTS.

EQUIPMENT ACCESS SHALL NOT BE REDUCED BY REFRIGERANT PIPING, CONDENSATE DRAINS, OR OTHER

VENTILATION AIR AND EXHAUST AIR SYSTEMS:

EXHAUST DUCTS FOR BATHROOMS, POWDER ROOMS, AND KITCHEN HOODS SHALL TERMINATE AT THE BUILDING EXTERIOR USING APPROVED ROOF CAPS, SIDEWALL CAPS, OR SOFFIT VENTS.

TOILET EXHAUST FANS SHALL BE FURNISHED WITH BACKDRAFT DAMPERS. TOILET EXHAUST FANS SHALL BE CONTROLLED BY MANUALLY OPERATED TIMERS.

DRYER EXHAUST DUCT SHALL BE ROUTED TO THE BUILDING EXTERIOR PER THE FLORIDA BUILDING CODE AND MANUFACTURER RECOMMENDATIONS. INSTALL BOOSTER FAN AS REQUIRED AND AS ALLOWED BY CODE.

VENTILATION AIR DUCT SHALL BE CONNECTED TO THE RETURN AIR PLENUM.

VENTILATION AIR DUCT SHALL INCLUDE A MANUAL VOLUME DAMPER AND A NORMALLY CLOSED ISOLATION DAMPER

THE VENTILATION ISOLATION DAMPER SHALL BE WIRED TO OPEN WHENEVER THE ASSOCIATED AHU IS TURNED ON. VENTILATION AIR INTAKE SHALL BE LOCATED IN ACCORDANCE WITH THE FLORIDA BUILDING CODE, AND SHALL BE A MINIMUM OF 10 FEET FROM EXHAUST TERMINATIONS, A MINIMUM OF 10 FEET FROM PLUMBING VENTS, A MINIMUM OF

3 FEET FROM OPERABLE WINDOWS AND DOORS, AND A MINIMUM OF 3 FEET FROM PROPERTY LINES.

AIR HANDLING UNIT SCHEDULE AREA SERVED MODEL SIZE EXT SP in Wg FAN TYPE REMARKS STAGES V/PH/HZ FC 1,2,3 ENTIRE HOUSE SEE REMARKS 230/1/60 230/1/60

REMARKS:

- 1. MODEL TO BE SELECTED BY CONTRACTOR BASED ON ACCA MANUAL J CALCULATIONS.
- 2. PROVIDE SEVEN DAY PROGRAMMABLE THERMOSTAT, MERV 8 FILTER, AND ELECTRIC RESISTANCE HEAT.
- 3. MODEL SIZE TO BE BASED ON MANUAL J CALCULATION.

EXHAUST FAN SCHEDULE								
MARK	TYPE	CFM	SP in Wg	DRIVE	VOLTS/PH/HZ	REMARKS		
EF-1	CEILING	50	0.25	DIRECT	115/1/60	1,2,3,4		

REMARKS:

- MODEL TO BE SELECTED BY CONTRACTOR
- 2. PROVIDE BACKDRAFT DAMPER, INLET GRILLE, SPEED CONTROLLER, AND DISCHARGE WALL CAP OR ROOF JACK.
- 3. WIRE TO WALL SWITCH FOR MANUAL CONTROL.
- 4. PROVIDE EXHAUST FAN WITH MANUALLY OPERATED TIMER.

HEAT PUMP SCHEDULE							
MARK	NOMINAL TONS	SYSTEM SERVED	V/PH/HZ	REMARKS			
HP-1	SEE REMARKS	AHU-1	208/230/1/60	1,2,3			

- MODEL TO BE SELECTED BY CONTRACTOR
- 2. UNIT SHALL BE MINIMUM 16 SEER.
- 2. REQUIRED NOMINAL TONS FOR HEAT PUMP MUST MATCH THAT FOR AIR HANDLER UNIT.



Dewberry Engineers Inc. 877 North County Hwy 393 Santa Rosa Beach, FL 32459 850.267.0759 Phone 850.557.0076 Fax www.dewberry.com



SEAL

SCALE

As indicated

REVISIONS


DRAWN BY ETO APPROVED BY CHECKED BY DATE

TITLE

GENERAL INFORMATION 4BR WIDE

PROJECT NO. 50171913

M0.1

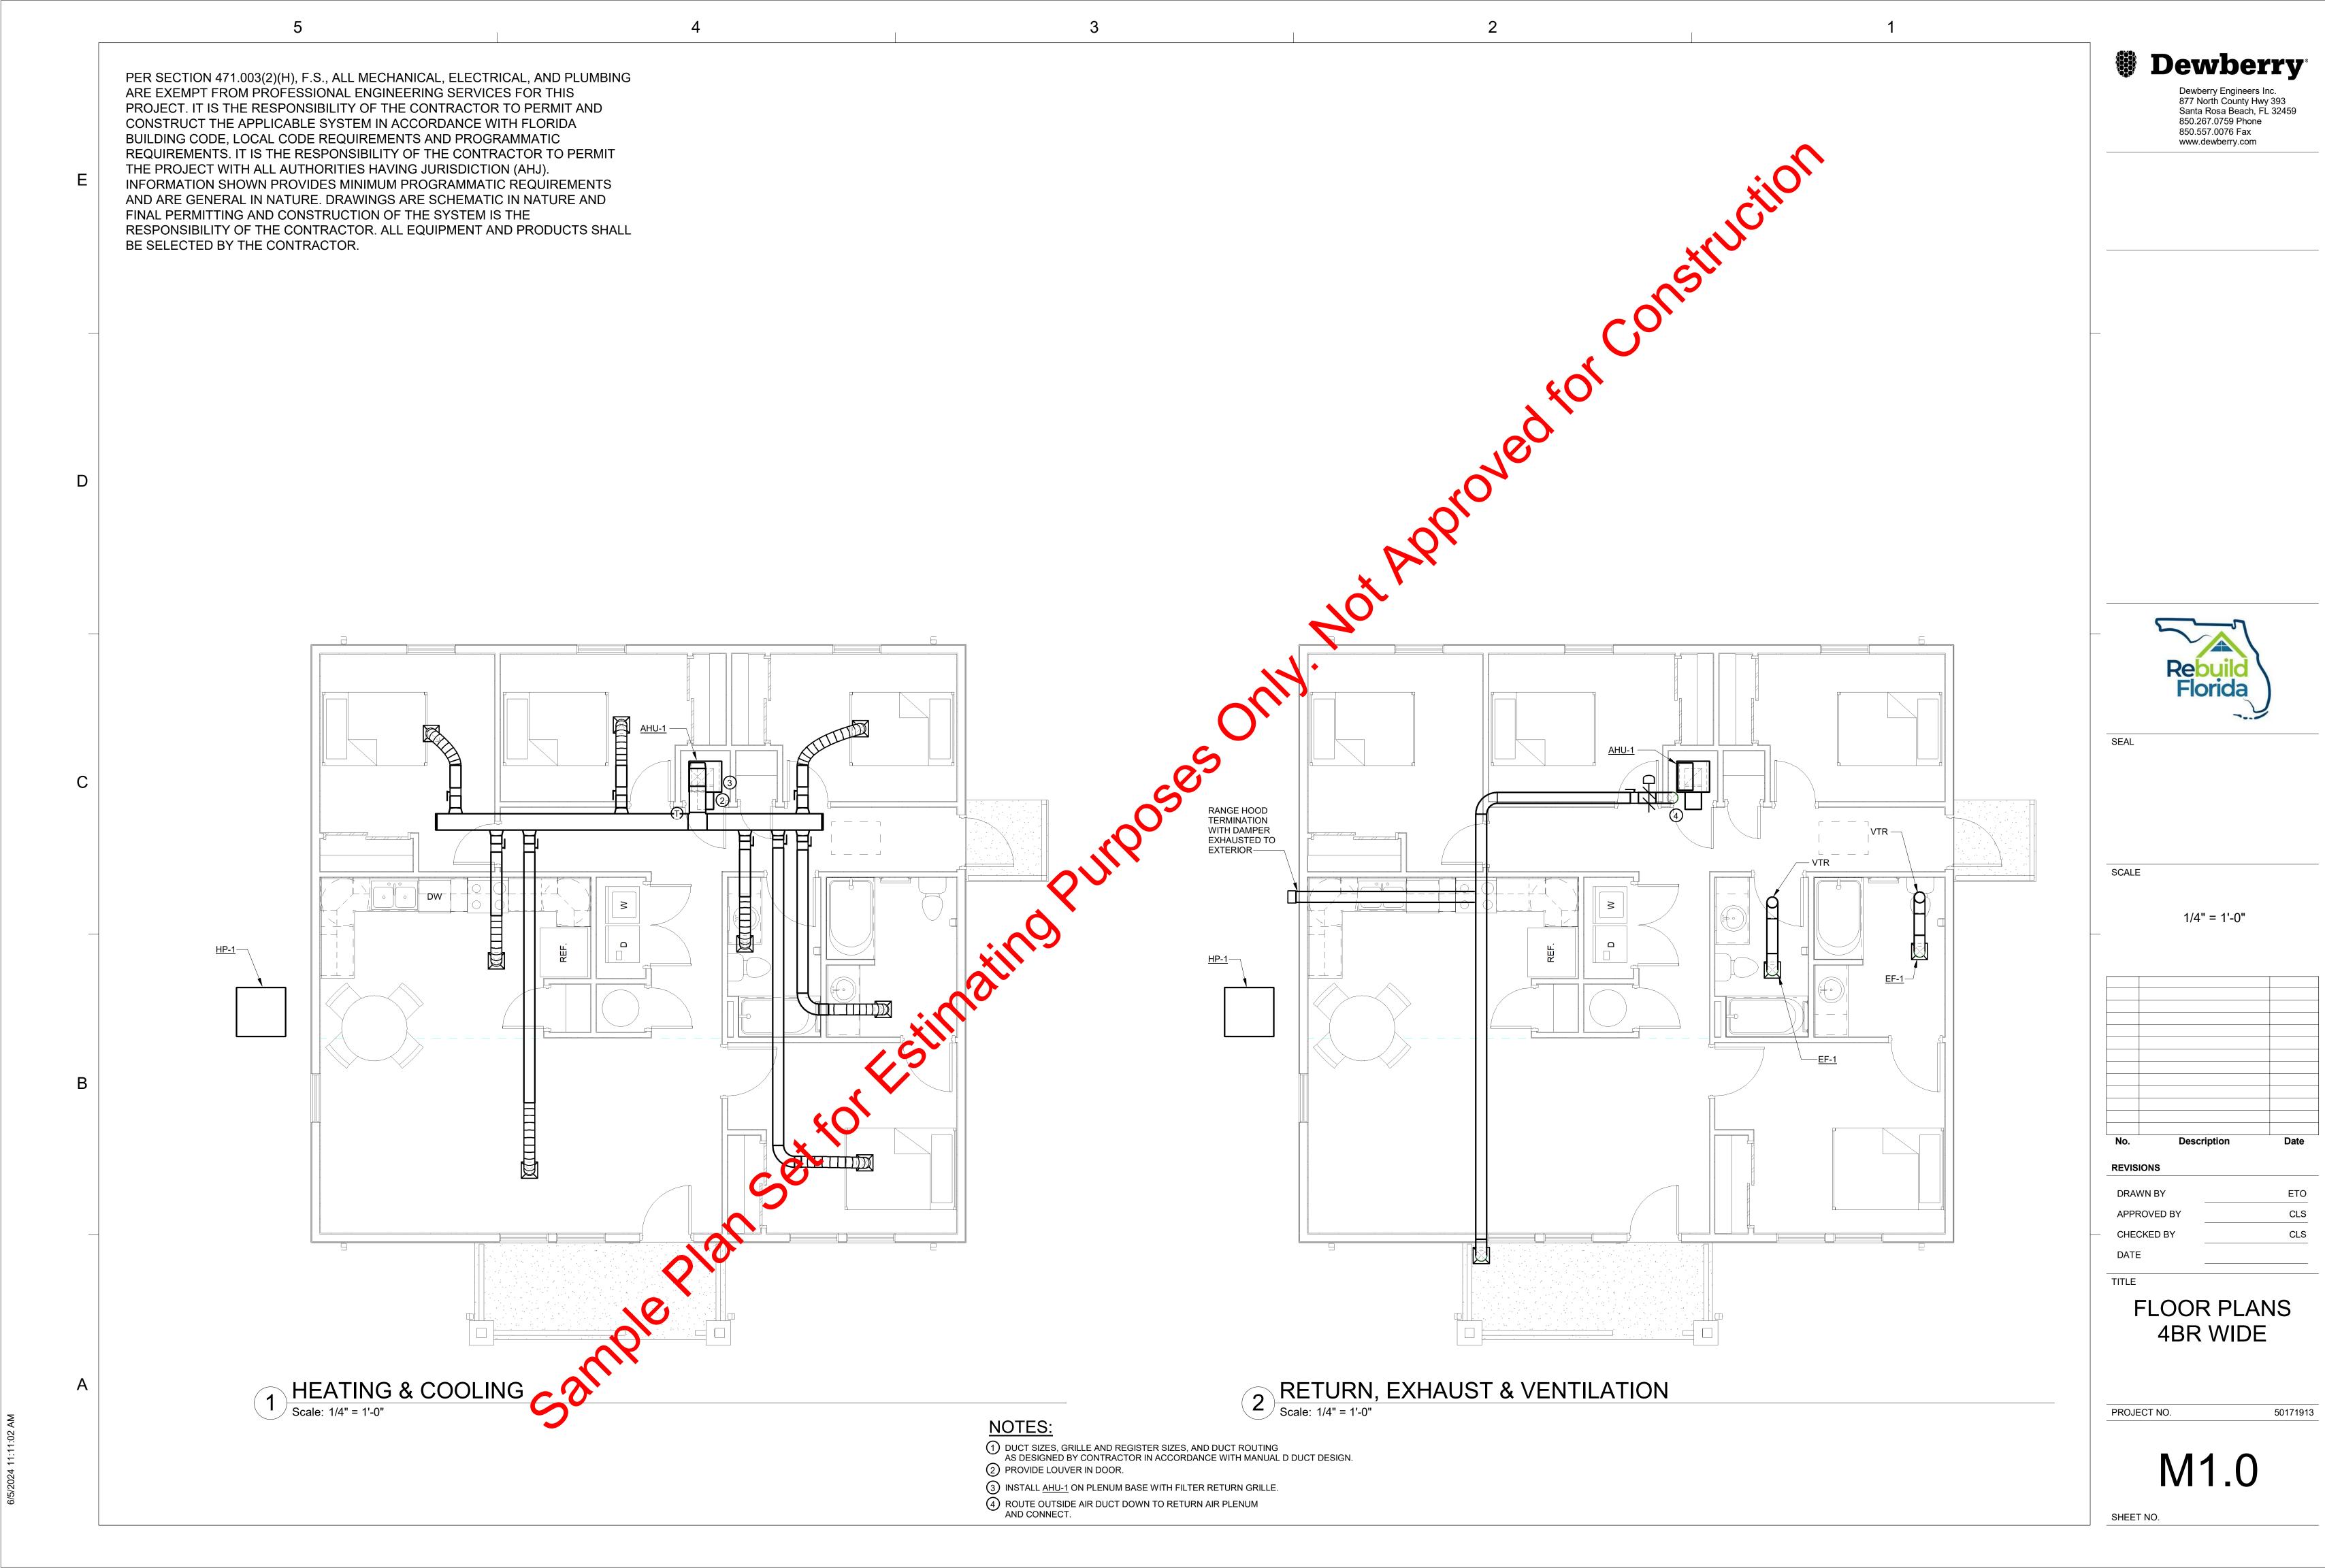

4 BR WIDE

NOTES (SHEET NO. E1.0)

- COMBINATION LIGHT / EXHAUST FAN FIXTURE TO BE ENERGY STAR COMPLIANT. COORDINATE WITH MECHANICAL CONTRACTOR.
- 2. INSTALL (1) 220 DISCONNECT. MAINTAIN A 3 FT CLEARANCE FRONT OF DISCONNECT

ELECTRICAL GENERAL NOTES

- 1. ELECTRICAL CONTRACTOR SHALL SIZE SERVICE, CONDUCTORS, FUSES, BREAKERS, AND SWITCHES IN ACCORDANCE WITH LOCAL BUILDING COLE. IN ELECTRICAL LOAD CALCULATION WILL BE REQUIRED FOR SERVICE SIZING.
- 2. PROVIDE SERVICE ENTRANCE COUNTY IN ACCORDANCE WITH LOCAL BUILDING CODE.
- 3. ELECTRICAL CONTRACTOR STALL COORDINATE WITH POWER COMPANY TO FULFILL REQUIREMENTS IN ESTABLISHING SERVICE. CONTRACTOR RESPONSIBLE FOR ALL ASSOCIATED FEES.
- 4. ALL WIRING SHALL BE COPPER WITH ONE EXCEPTION ONLY. THE SERVICE ENTERANCE CONDUCTORS MAY USE COPPER OR ALUMINUM (SE OR USE). OTHERWISE, NO ALUMINUM WIRING SHALL BE USED.
- SMOKE DETECTORS SHOWN SHALL BE COMBINATION SMOKE/CARBON MONOXIDE ALARMS. AND BE APPROVED AND LISTED IN ACCORDANCE WITH UL 217 AND 2034. THEY SHALL BE HARD WIRED WITH BATTERY BACK-UP. ALL DETECTORS WITHIN A UNIT SHALL BE INTERCONNECTED SUCH THAT ALL ALARM UPON ACTIVATION OF A SINGLECTION.
- 6. ALLICUT FIXTURES AND CEILING FANS SHALL BE ENERGY STAR QUALIFIED.
- 7. PROVIDE ARC FAULT CIRCUIT INTERRUPTER (AFCI) PROTECTION WHERE REQUIRED BY CODE. PREFERRED OMPLIANCE PATH IS PROTECTION AT THE BRANCH CIRCUIT BREAKER LEVEL.
- COORDINATION WITH OTHER TRADES: EXECUTE THE WORK IN FULL COOPERATION WITH OTHER CONSTRUCTION TRADES. PRIOR TO STARTING WORK, EXAMINE A COMPLETE SET OF CONSTRUCTION DOCUMENTS FOR ALL TRADES TO VERIFY COORDINATION, CHECK FOR INTERFERENCES, AND DETERMINE POINTS OF CONNECTIONS FOR EQUIPMENT. DUE TO STRUCTURAL CONDITIONS, MECHANICAL DUCT OR PIPING INTERFERENCE, OR OTHER REASONS, THE CONTRACTOR MAY DESIRE TO INSTALL THE WORK IN AN ALTERNATE MANNER FROM THAT SHOWN. SUCH CHANGES SHALL BE PRESENTED TO THE OWNER'S REPRESENTATIVE FOR APPROVAL BEFORE PROCEEDING.
- PROVIDE DATA (CAT-6) AND TELEVISION (RG-6 SHIELDED) RECEPTACLES IN ALL BEDROOMS AND (1) IN LIVING ROOM. PROVIDE ALL TERMINATIONS AND COVER PLATES TO MATCH POWER RECEPTACLE COVER PLATES.
- 10. LOCATIONS WHERE CONDUITS PENETRATE FIRE-RATED WALLS, FLOORS, OR CEILINGS SHALL BE FIREPROOFED USING A UL-LISTED METHOD TO MAINTAIN THE EXISTING RATING.
- COORDINATE THE MOUNTING HEIGHT AND LOCATIONS OF THE ELECTRICAL DEVICES WITH ARCHITECTURAL ELEVATIONS AND GENERAL TRADES CONTRACTOR PRIOR TO ROUGH-IN. RECEPTACLES LOCATED WITHIN SIX (6) FEET OF SINK SHALL BE GROUND FAULT CIRCUIT INTERRUPTER (GFCI) TYPE RECEPTACLES. RECEPTACLES NOT READILY ACCESSIBLE THAT REQUIRE GFCI PROTECTION SHALL BE SO AT THE CIRCUIT BREAKER.
- 12. COORDINATE LOCATION OF CONDUITS, OUTLETS AND JUNCTION BOXES WITH MECHANICAL EQUIPMENT SO THAT OUTLETS AND JUNCTION BOXES ARE ACCESSIBLE FOR SERVICING AND HVAC DUCTWORK CAN BE CONNECTED DIRECTLY TO DIFFUSERS.
- 3. PERFORM ALL WORK IN ACCORDANCE WITH 2020 NATIONAL ELECTRICAL CODE (NEC) (OR WHICHEVER IS LATEST FLORIDA-ADOPTED EDITION OF THE NEC) AND ALL APPLICABLE LOCAL CODES.
- 14. FOR RECORD DRAWING REQUIREMENTS, REFER TO THE GENERAL CONDITIONS. MAINTAIN A DEDICATED SET OF DRAWINGS ON THE JOBSITE AND MARK ALL VARIATIONS TAKEN TO THE CONTRACT DRAWINGS. SEE PLANS FOR SUGGESTED LOCATIONS.
- 15. ALL ELECTRICAL EQUIPMENT SHALL BE INSTALLED SUCH THAT PROPER WORKING CLEARANCES ARE MAINTAINED.
- 16. COORDINATE WITH MECHANICAL TO PROVIDE APPROPRIATE CIRCUITS FOR HVAC AND PLUMBING EQUIPMENT. PROVIDE LOCAL DISCONNECT FOR EACH PIECE OF EQUIPMENT AND ENSURE WORKING CLEARANCE TO
- 17. ALL WORK SHALL MEET APPLICABLE REQUIREMENTS OF THE FLORIDA RESIDENTIAL CODE 2023 EDITION (OR MOST RECENT) AND CHAPTER 4 [RE] RESIDENTIAL ENERGY EFFICIENCY OF FBC, ENERGY CONSERVATION 2023 (OR MOST RECENT).
- 18. ALL CONSTRUCTION WORK SHALL BE IN COMPLIANCE WITH ALL LOCAL CITY, COUNTY, STATE OF FLORIDA AND FEDERAL CODES. THE CONTRACTOR SHALL GIVE ALL NOTICES AND COMPLY WITH ALL LAWS, ORDINANCES, RULES, REGULATIONS, AND LAWFUL ORDERS OF ANY PUBLIC AUTHORITY BEARING PERFORMANCE OF THE
- 19. COMBINATION SMOKE /CARBON MONOXIDE DETECTORS SHALL BE PROVIDED IN AND OUTSIDE ALL SLEEPING AREAS. SEE PLANS FOR SUGGESTED LOCATIONS.
- 20. CONTRACTOR TO COORDINATE ALL UTILITIES INSTALLATION AND CONNECTION WITH LOCAL UTILITY COMPANY. AVOID ROUTING CONDUIT THROUGH BUILDING FOOTINGS. WHERE CONFLICTS ARE UNAVOIDABLE, ROUTE CONDUIT AT A MINIMUM OF 12" BELOW FOOTING.
- 21. ALL PENETRATIONS THROUGH FIRE RATED WALLS ARE TO BE SEALED WITH CODE APPROVED FIRESTOPPING
- 22. CONTRACTOR SHALL PROVIDE ALL ELECTRICAL FIXTURES, HARDWARE, AND ACCESSORIES IN A CONSISTENT
- 23. CONTRACTOR SHALL PROVIDE ELECTRICAL LOAD CALCULATIONS AND ANY ADDITIONAL ELECTRICAL

INFORMATION REQUESTED BY PERMIT DEPARTMENT NOT SHOWN IN DRAWINGS.

24. CONTRACTOR SHALL WIRE SERVICE CONDUCTORS THROUGH A JUNCTION BOX. THE INTENT IS THAT IF A FUTURE HOMEOWNER DESIRES TO INSTALL A BACKUP GENERATOR, THEY COULD REPLACE THE BOX WITH A SERVICE ENTRANCE AUTOMATIC TRANSFER SWITCH. PROVIDE CONTINUOUS SERVICE ENTRANCE CONDUCTORS THROUGH THE BOX WITH EXTRA LENGTH TO FACILITATE FUTURE CONNECTION. COORDINATE LOCATION BOX AND METER BASE WITH THE POWER COMPANY.

PER SECTION 471.003(2)(H), F.S., ALL MECHANICAL, ELECTRICAL, AND PLUMBING ARE EXEMPT FROM PROFESSIONAL ENGINEERING SERVICES FOR THIS PROJECT. IT IS THE RESPONSIBILITY OF THE CONTRACTOR TO PERMIT AND CONSTRUCT THE APPLICABLE SYSTEM IN ACCORDANCE WITH FLORIDA BUILDING CODE, LOCAL CODE REQUIREMENTS AND PROGRAMMATIC REQUIREMENTS. IT IS THE RESPONSIBILITY OF THE CONTRACTOR TO PERMIT THE PROJECT WITH ALL AUTHORITIES HAVING JURISDICTION (AHJ). INFORMATION SHOWN PROVIDES MINIMUM PROGRAMMATIC REQUIREMENTS AND ARE GENERAL IN NATURE. DRAWINGS ARE SCHEMATIC IN NATURE AND FINAL PERMITTING AND CONSTRUCTION OF THE SYSTEM IS THE RESPONSIBILITY OF THE CONTRACTOR. ALL EQUIPMENT AND PRODUCTS SHALL BE SELECTED BY THE CONTRACTOR.




Dewberry Engineers Inc. 877 North County Hwy 393 Santa Rosa Beach, FL 32459 850.267.0759 Phone 850.557.0076 Fax www.dewberry.com



SEAL

SCALE

As indicated

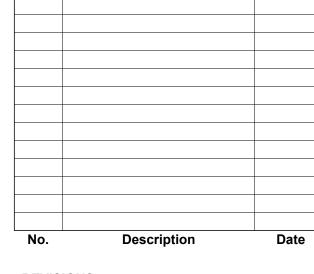

DRAWN BY
APPROVED BY
CHECKED BY
MGB
DATE

TITLE

ELECTRICAL PLAN 4 BR WIDE

PROJECT NO.

F10

50171913

REBUILD FLORIDA - HURRICANE HOUSING REPAIR AND REPLACEMENT

ADDRESS, CITY COUNTY, FLORIDA

2 BEDROOM / 2 BATH WIDE PIER

PROJECT MANAGER

Dewberry Engineers Inc.

877 North County Hwy 393
Santa Rosa Beach, FL 32459

850.267.0759

ARCHITECTURAL

Dewberry Architects Inc.


STRUCTURAL

Hunter Baumgardner, PE Southeastern Consulting Engineers, Inc.







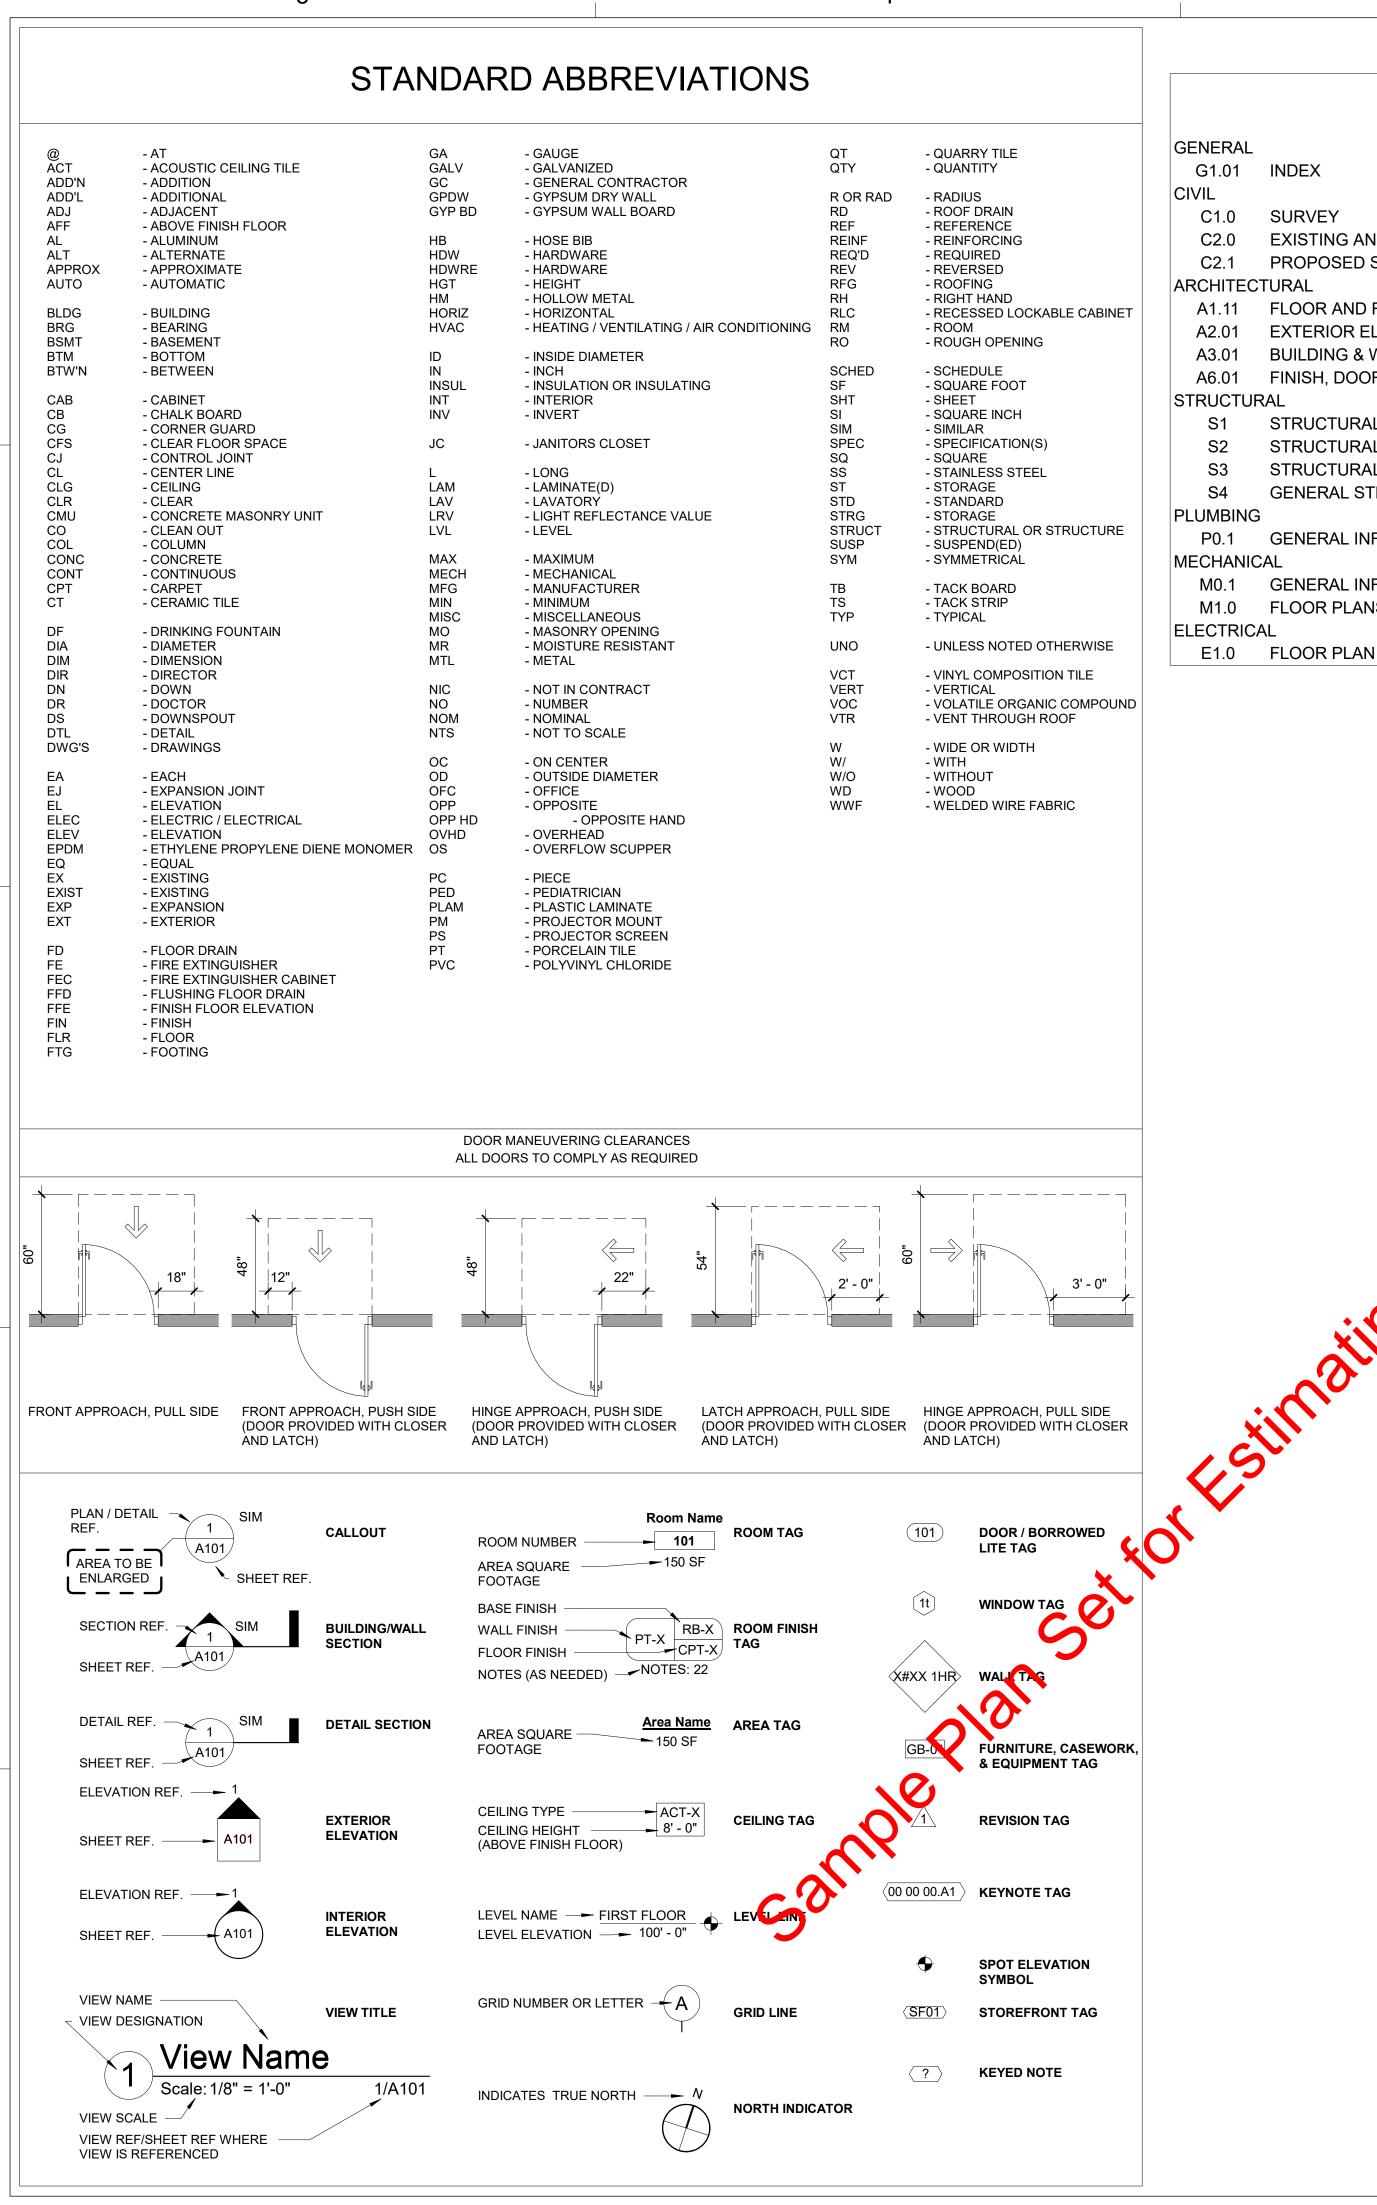

SHEET INDEX GENERAL G1.01 C1.0 SURVEY EXISTING AND PROPOSED SITE OVERLAY PROPOSED SITE AND DRAINAGE PLAN ARCHITECTURAL FLOOR AND ROOF PLANS **EXTERIOR ELEVATIONS** BUILDING & WALL SECTIONS AND INTERIOR ELEVATIONS FINISH, DOOR, & WINDOW SCHEDULES **STRUCTURAL** STRUCTURAL PLAN VIEW STRUCTURAL DETAILS STRUCTURAL DETAILS GENERAL STRUCTURAL NOTES **PLUMBING** GENERAL INFORMATION MECHANICAL GENERAL INFORMATION M1.0 FLOOR PLANS

GENERAL CONSTRUCTION NOTES

THE CONTRACTOR SHALL VISIT THE JOB SITE TO REVIEW THE SCOPE OF WORK AND CONFIRM THAT THE WORK MAY BE ACCOMPLISHED AS SHOWN.

PLANS ARE NOT TO BE SCALED AND ARE INTENDED TO BE A DIAGRAMMATIC OUTLINE, UNLESS OTHERWISE NOTED.

FURNISH ALL MATERIALS, EQUIPMENT, AND LABOR NECESSARY TO AFFECT ALL INSTALLATIONS INDICATED ON THE DRAWINGS. INCLUDING DETAILS AND LABOR NECESSARY FOR SUCCESSFUL INSTALLATION OF THE WORK.

INSTALL ALL EQUIPMENT AND MATERIALS IN STRICT ACCORDANCE WITH MANUFACTURERS' RECOMMENDATIONS UNLESS SPECIFICALLY INDICATED OTHERWISE OR WHERE LOCAL CODES OR REGULATIONS TAKE PRECEDENCE.

DETAILS ARE INTENDED TO SHOW END RESULT OF DESIGN. MNOR MODIFICATIONS MAY BE REQUIRED TO SUIT JOB DIMENSIONS OR

WORK SHOWN OR REFERRED TO ON ANY DRAWING SHALL BE PROVIDED AS THOUGH SHOWN ON ALL RELATE

EVERY EFFORT HAS BEEN MADE TO PROVIDE THE COMPLETE SCOPE OF WORK. MINOR OMISSIONS AND DISCREPANCIES IN THE DRAWINGS SHALL NOT DIMINISH THE EXPECTATION OF A COMPLETED FACILITY AND IMPROVEMENTS IN ACCORDANCE WITH THE INTENT OF THESE DOCUMENTS. IN THE EVENT OF DISCREPANCIES, PRICE THE MORE EXPENSIVE OR EXTENSIVE WORK, UNLESS DIRECTED OTHER VISE.

GENERAL CONTRACTOR SHALL PROVIDE AT THE JOB SITE A FULL SET OF CONSTRUCTION DOCUMENTS ANNOTATED WITH THE LATEST REVISIONS AND CLARIFICATIONS FOR THE USE BY ALL.

GENERAL CONTRACTOR SHALL COORDINATE, APPLY, AND PAY FOR ALL PERMITS, NOT ECTIONS, AND/OR CERTIFICATES FROM THE APPROPRIATE AGENCIES. IT IS THE CONTRACTOR'S RESPONSE LITY TO CALL FOR LOCAL INSPECTIONS AND OBTAIN APPROVAL FROM THE STATE FIRE MARSHAL IF REQUIRED.

CONTRACTOR SHALL VERIFY THE MINIMUM FINISH FLOOR EVATION WITH THE CITY/PARISH FEMA BASE FLOOD ELEVATION AND BENCHMARK CERTIFICATE.

THE CONTRACTOR SHALL HAVE THE WORK SITE CLEANED ON A DAILY BASIS. THE DISPOSAL OF ANY WASTE SHALL BE OFF SITE AND IN A MANNER PRESCRIBED UNDER THE LAW.

COORDINATE WITH UTILITY PROVIDERS TO LOCATE, CAP, AND/OR DISCONNECT UTILITIES AS REQUIRED.

A. BUILDING DATA

SEISMIC DESIGN CATEGORY : TBD (FIGURE R301.2.2(2))

B. ENERGY SUMMARY

: 1,092 SF

: 1,207 SF

: 115 SF

NEW CONSTRUCTION

: SINGLE FAMILY RESIDENTIAL

: 17'-2" (+ HEIGHT OF PIERS IF APPLICABLE)

REQUIRED

R-38

R-13

R-13

R-0

0.40

0.25

/ PROVIDED

/ R-19

/ R-19

/ R-0

/ R-38 BLOWN

OR / (2) R-19 BLANKET

TYPE OF WORK

FIRE ALARM **SPRINKLERS**

STANDPIPES

FIRE DISTRICT

RISK CATEGORY

BUILDING HEIGHT

CLIMATE ZONE

TABLE R402.1.2

CEILING

FLOOR

IECC REQUIREMENTS

NEW BUILDING AREA

GROSS

CONSTRUCTION TYPE

FLOOD HAZARD AREA

FIRE/SMOKE RATED WALLS

CONDITIONED

UNCONDITIONED

WALLS ABOVE GRADE (WOOD FRAMED)

FENESTRATION REQUIREMENTS

MAXIUMUM U-FACTOR

IT IS THE RESPONSIBILITY OF THE CONTRACTOR TO VERIFY AND COMPLY WITH ALL BUILDING CODE, MUNICIPAL CODE AND HOME OWNER ASSOCIATION (HOA) REQUIREMENTS.

RAZE EXISTING STRUCTURE AS REQUIRED, PROPERLY DISPOSING OF DEBRIS WITH A LEGAL DUMPSTER ON SITE.

REMOVE SIDEWALKS, DRIVEWAYS, AND OTHER FLATWORK ON SITE AS REQUIRED.

REMOVE EXISTING SHRUBS, TREE ROOTS, ETC WHERE NEW FLATWORK, DRAINLINES, AND HOUSE SLABS WILL BE LOCATED AS

COORDINATE TREE REMOVAL WITH MUNICPALITY. PROTECT TREES

FILL HOLES CAUSED BY REMOVAL OF EXISTING OBSTRUCTIONS WITH SOIL SIMILAR TO EXISTING ADJACENT SOILS.

SLOPE ALL CONCRETE PAVING AWAY FROM BUILDING AT MINIMUM

SLOPE ALL FINAL GRADING AWAY FROM BUILDING TO ENSURE

SLOPE ALL CONCRETE WALKS AWAY FROM BUILDING AT MINIMUM

POSITIVE DRAINAGE TO AREA DRAINS OR CULVERTS, NOT TO ADJACENT PROPERTIES.

ALL DRIVEWAY AND SIDEWALKS SHALL MEET LOCAL DEPARTMENT OF PUBLIC WORKS STANDARD DETAILS IF APPLICABLE.

THE CONTRACTOR SHALL COORDINATE ALL UTILITIES INSTALLATION AND CONNECTION WITH LOCAL UTILITY COMPANY.

CONTRACTOR SHALL PROVIDE CLEAN OUT LOCATIONS, TIE-IN

LOCATIONS, AND WATER AND SEWER LINE LOCATIONS ON SITE TO PERMIT DEPARTMENT FOR REVIEW. LAY NEW SOD AROUND PERIMETER OF FOUNDATION A MINIMUM OF

8 FEET. STABILIZE OTHER DISTURBED SOILS BY OTHER APPROPRIATE METHODS.

CONTRACTOR SHALL PROVIDE ALL PLUMBING FIXTURES, ELECTRICAL FIXTURE, DOOR HARDWARE, BATHROOM HARDWARE, AND BATHROOM ACCESSORIES IN A CONSISTENT MATERIAL FINISH.

APPLIANCES SHALL BE ENERGY STAR CERTIFIED - CLOTHES WASHER, CLOTHES DRYER, RANGE HOOD, DISHWASHER, REFRIGERATOR. SUPPLY HOSES TO WATER USING FIXTURES AND APPLIANCES MUST BE ARMORED PEX OR METAL (NOT COPPER).

ALL EXTERIOR PAINT TO MEET LIGHT REFLECTANCE VALUE (LRV) OF

PER FBC APPENDIX F, PASSIVE RADON-RESISTANT CONSTRUCTION: PROVIDE 6 MIL VAPOR BARRIER UNDER SLAB ON GRADE. 2" PRESSURE-SENSITIVE VINYL TAPE ALL JOINTS.

SEAL AND CAULK ALL SLAB PENETRATIONS WITH MASTIC OR SLABS AND FOUNDATIONS SHALL BE CONSTRUCTED USING

A SLAB EDGE DETAIL THAT ELIMINATES CRACKS THAT COULD CONNECT THE HOUSE INTERIOR TO SUBSLAB SOIL. MONOLITHIC SLAB CONSTRUCTION USED WHERE POSSIBLE ALL CONTRACTION JOINTS SHALL BE CLEANED AND SEALED

AGAINST SOIL-GAS ENTRY BY USE OF AN APPROVED SEALANT. WORK SPACES FORMED INTO A SLAB SHALL BE SEALED GAS-TIGHT. EXPOSED SOIL SHALL BE COMPACTED AND FULLY

COVERED WITH A SOLVENT-BASED PLASTIC ROOF CEMENT OR OTHER APPROVED ELASTOMERIC MATERIAL TO A MIN. WHERE PENETRATING PIPES ARE SLEEVED, THEY SHALL BE

SEALED BY JOINT SEALANT OR APPROVED ALTERNATIVE **VAPOR BARRIER NOT REQUIRED FOR PIER CONSTRUCTION** WHEN BOTTOM OF FLOOR JOISTS ARE GREATER THAN 18"

C. BUILDING CODE SUPPORTING DATA

APPLICABLE CODE

2023 FLORIDA BUILDING CODE, ENERGY CONSERVATION 2018 WOOD FRAME CONSTRUCTION MANUAL

ENCLOSED SPACE UNDER STAIRS THAT IS ACCESSED BY A DOOR OR ACCESS PANEL SHALL HAVE WALLS, UNDER-STAIR SURFACE AND ANY SOFFITS PROTECTED ON THE ENCLOSED SIDE WITH 1/2-INCH GYPSUM BOARD

BOTH VERTICAL AND HORIZONTAL CONCEALED DRAFT OPENINGS AND TO FORM AN EFFECTIVE FIRE BARRIER BETWEEN STORIES. AND BETWEEN A TOP STORY AND THE

PERCENT OF THE FLOOR AREA OF SUCH ROOMS

HABITABLE ROOMS SHALL HAVE A ROOM AREA OF NOT LESS THAN 70 SQUARE FEET EXCEPTION: KITCHENS

EXCEPTION: KITCHENS BASEMENTS, HABITABLE ATTICS, AND EVERY SLEEPING ROOM SHALL HAVE NOT LESS

EMERGENCY ESCAPE AND RESCUE OPENINGS SHALL HAVE A NET CLEAR OPENING OF NOT LESS THAN 5.7 SQUARE FEET

NOT LESS THAN ONE EGRESS DOOR SHALL BE PROVIDED FOR EACH DWELLING UNIT, AND SHALL PROVIDE A CLEAR WIDTH OF NOT LESS THAN 32 INCHES.

DIRECTION OF TRAVEL THE WIDTH OF A HALLWAY SHALL BE NOT LESS THAN 3 FEET

THE MAXIMUM RISER HEIGHT SHALL BE 7 3/4 INCHES

THE TREAD DEPTH SHALL BE NOT LESS THAN 10 INCHES

SMOKE ALARMS SHALL BE INSTALLED IN EACH SLEEPING ROOM, OUTSIDE EACH

BUILDINGS SHALL BE PROVIDED WITH APPROVED ADDRESS IDENTIFICATION. THE SHALL BE NOT LESS THAN 4 INCHES IN HEIGHT

FROM GRADE

:2023 FLORIDA BUILDING CODE, RESIDENTIAL **AMERICANS WITH DISABILITIES ACT GUIDELINES**

IN COMBUSTIBLE CONSTRUCTION, FIREBLOCKING SHALL BE PROVIDED TO CUT OFF

HABITABLE ROOMS SHALL HAVE AN AGGREGATE GLAZING AREA OF NOT LESS THAN 8

HABITABLE ROOMS SHALL BE NOT LESS THAN 7 FEET IN ANY HORIZONTAL DIMENSION THAN ONE OPERABLE EMERGENCY ESCAPE AND RESCUE OPENING

THERE SHALL BE A LANDING OR FLOOR ON EACH SIDE OF EACH EXTERIOR DOOR. THE WIDTH OF THE LANDING SHALL BE NOT LESS THAN THE DOOR SERVED. LANDINGS SHALL HAVE A DIMENSION OF NOT LESS THAN 36 INCHES MEASURED IN THE

A FLIGHT OF STAIRS SHALL NOT HAVE A VERTICAL RISE LARGER THAN 12 FEET 7 INCHES BETWEEN FLOOR LEVELS OR LANDINGS

SEPARATE SLEEPING AREA IN THE IMMEDIATE VICINITY OF THE BEDROOMS, NOT LESS THAN 3 FEET HORIZONTALLY FROM THE DOOR OR OPENING OF A BATHROOM THAT CONTAINS A BATHTUB OR SHOWER, AND ON EACH ADDITIONAL STORY

ADDRESS IDENTIFICATION SHALL BE LEGIBLE AND PLACED IN A POSITION THAT IS VISIBLE FROM THE STREET OR ROAD FRONTING THE PROPERTY. EACH CHARACTER

THE UNDER-FLOOR SPACE BETWEEN THE BOTTOM OF THE FLOOR JOISTS AND THE EARTH UNDER ANY BUILDING SHALL HAVE VENTILATION OPENINGS THROUGH FOUNDATION WALLS OR EXTERIOR WALLS. THE MINIMUM NET AREA OF VENTILATION OPENINGS SHALL BE NOT LESS THAN 1 SQUARE FOOT FOR EACH 150 SQUARE FEET OF UNDER-FLOOR SPACE AREA. ONE SUCH VENTILATING OPENING SHALL BE WITHIN 3 FEET OF EACH CORNER OF THE BUILDING

Dewberry

877 North County Hwy 393

850.267.0759 Phone

850.557.0076 Fax

www.dewberry.com

Santa Rosa Beach, FL 32459

SCALE

As indicated

Description REVISIONS

DRAWN BY SEH APPROVED BY LWH **CHECKED BY** ANS


PROJECT NO.


50171913


SHEET NO.

DATE

TITLE

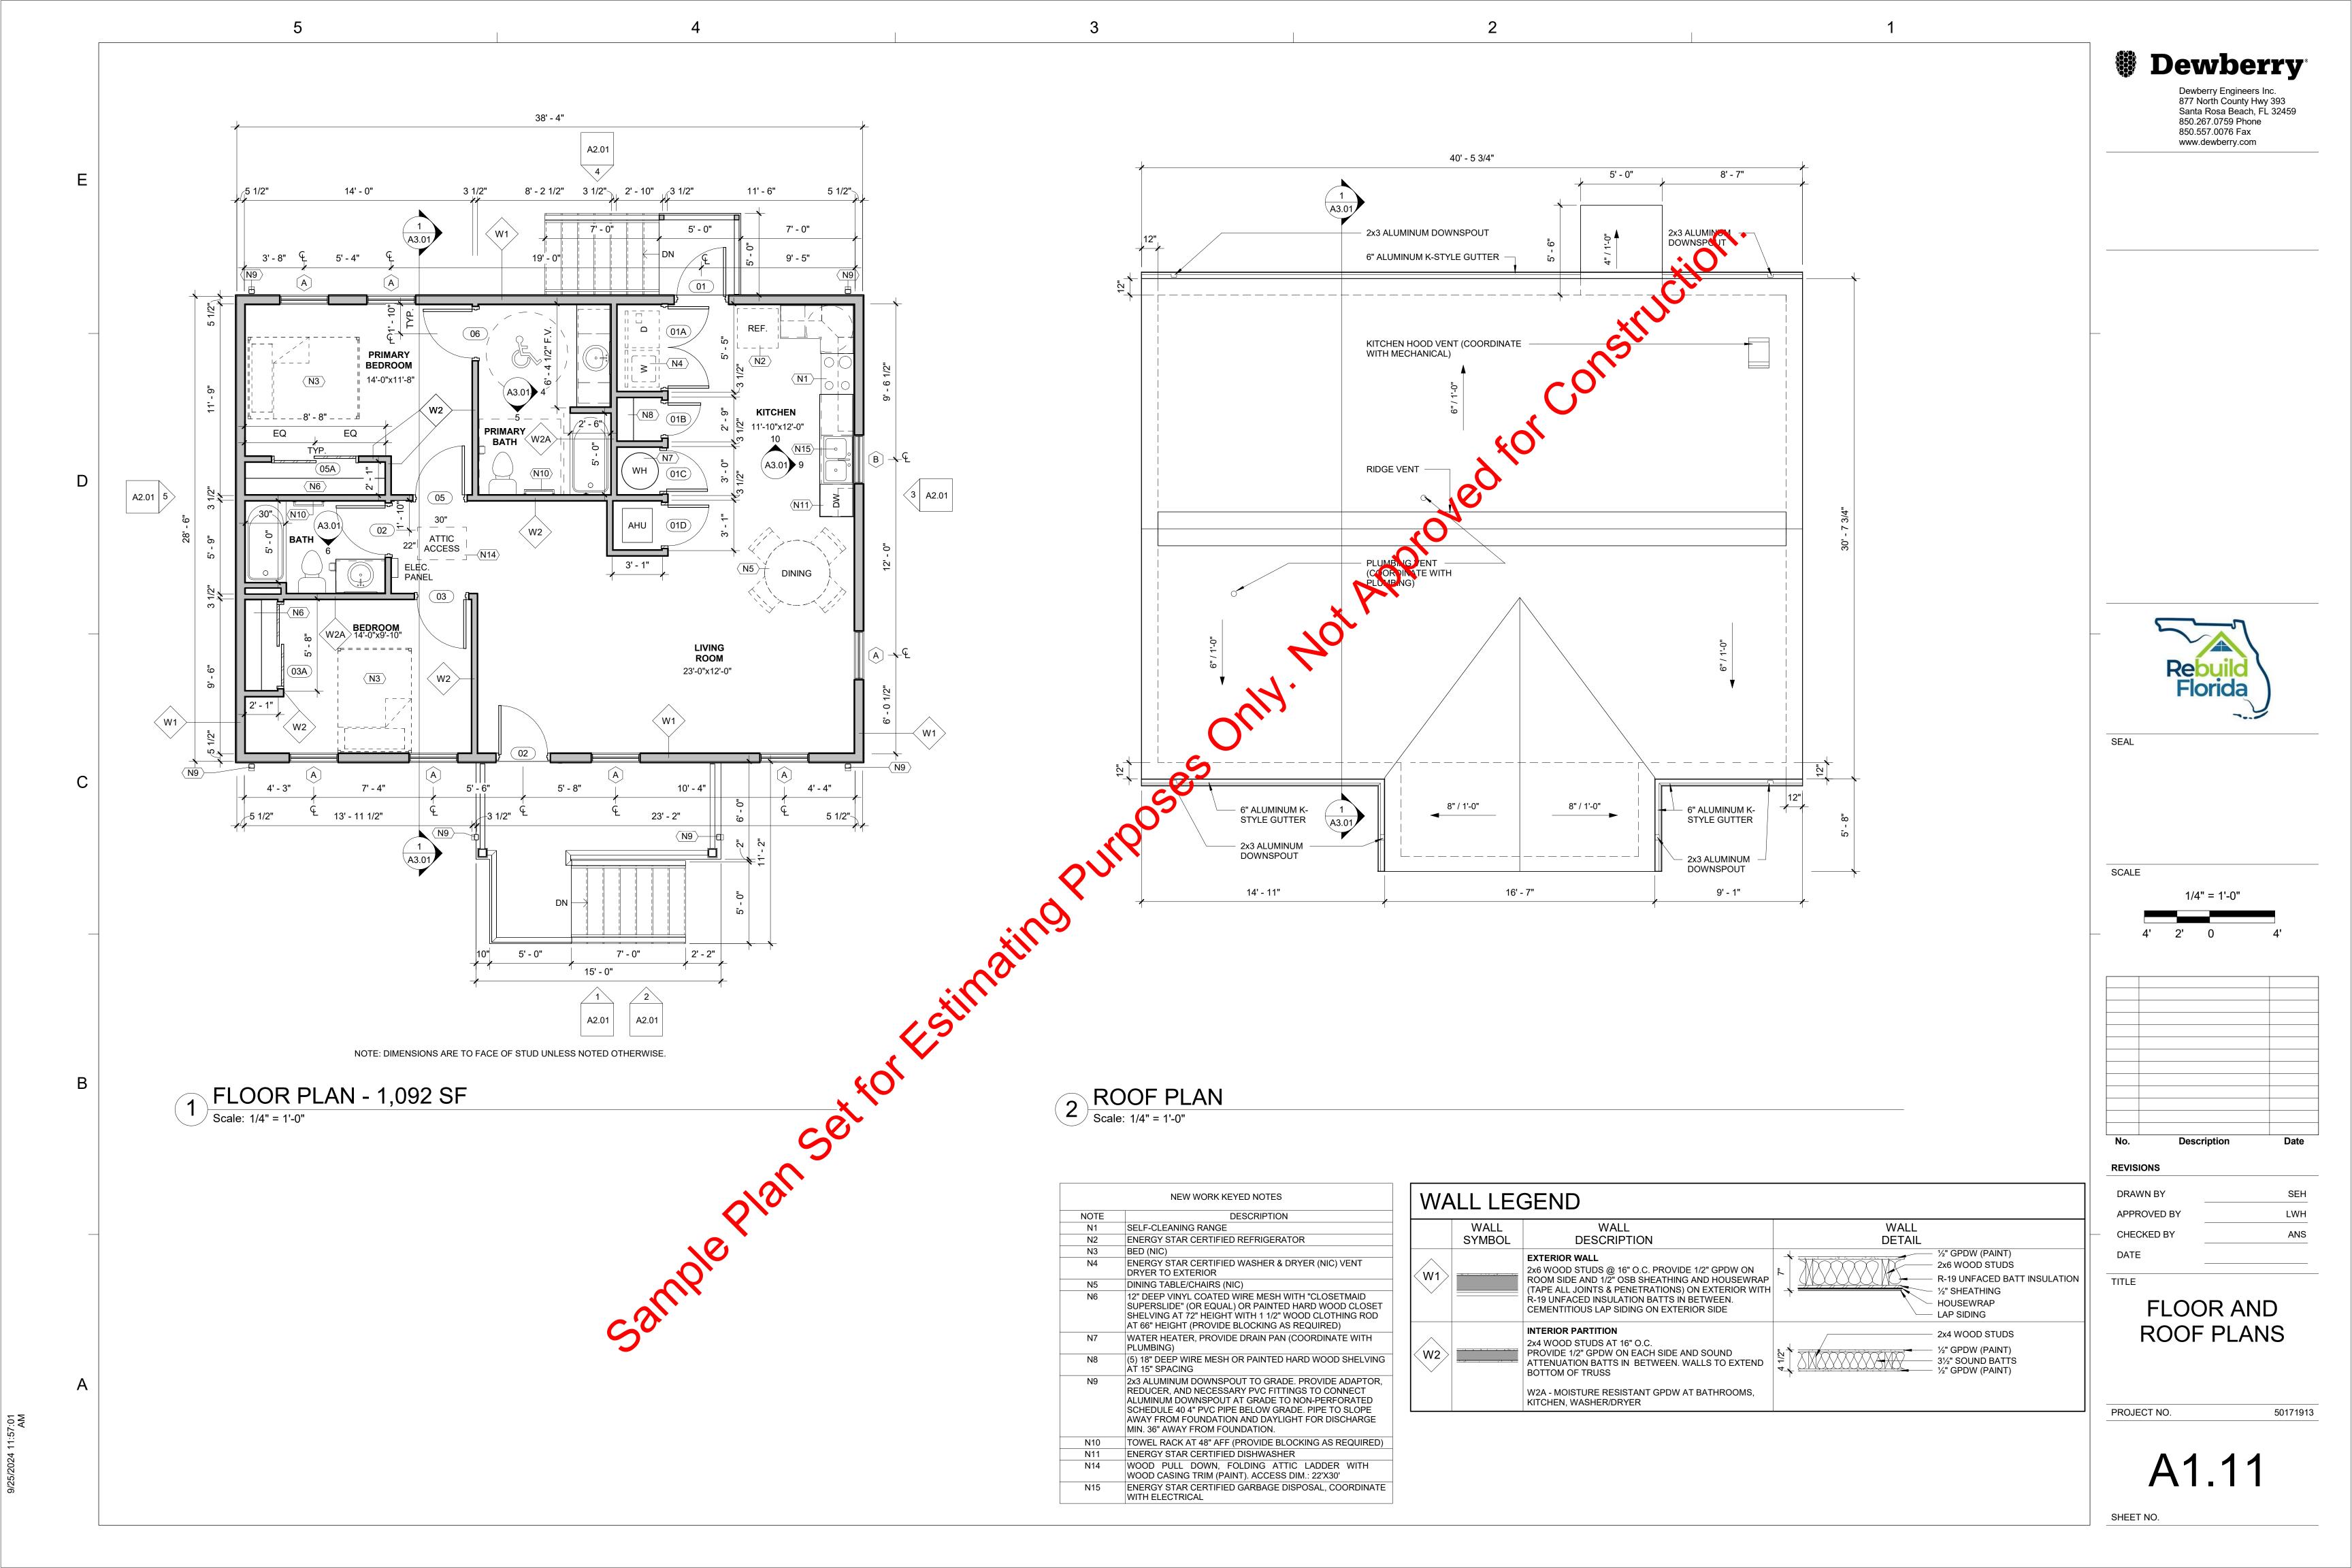

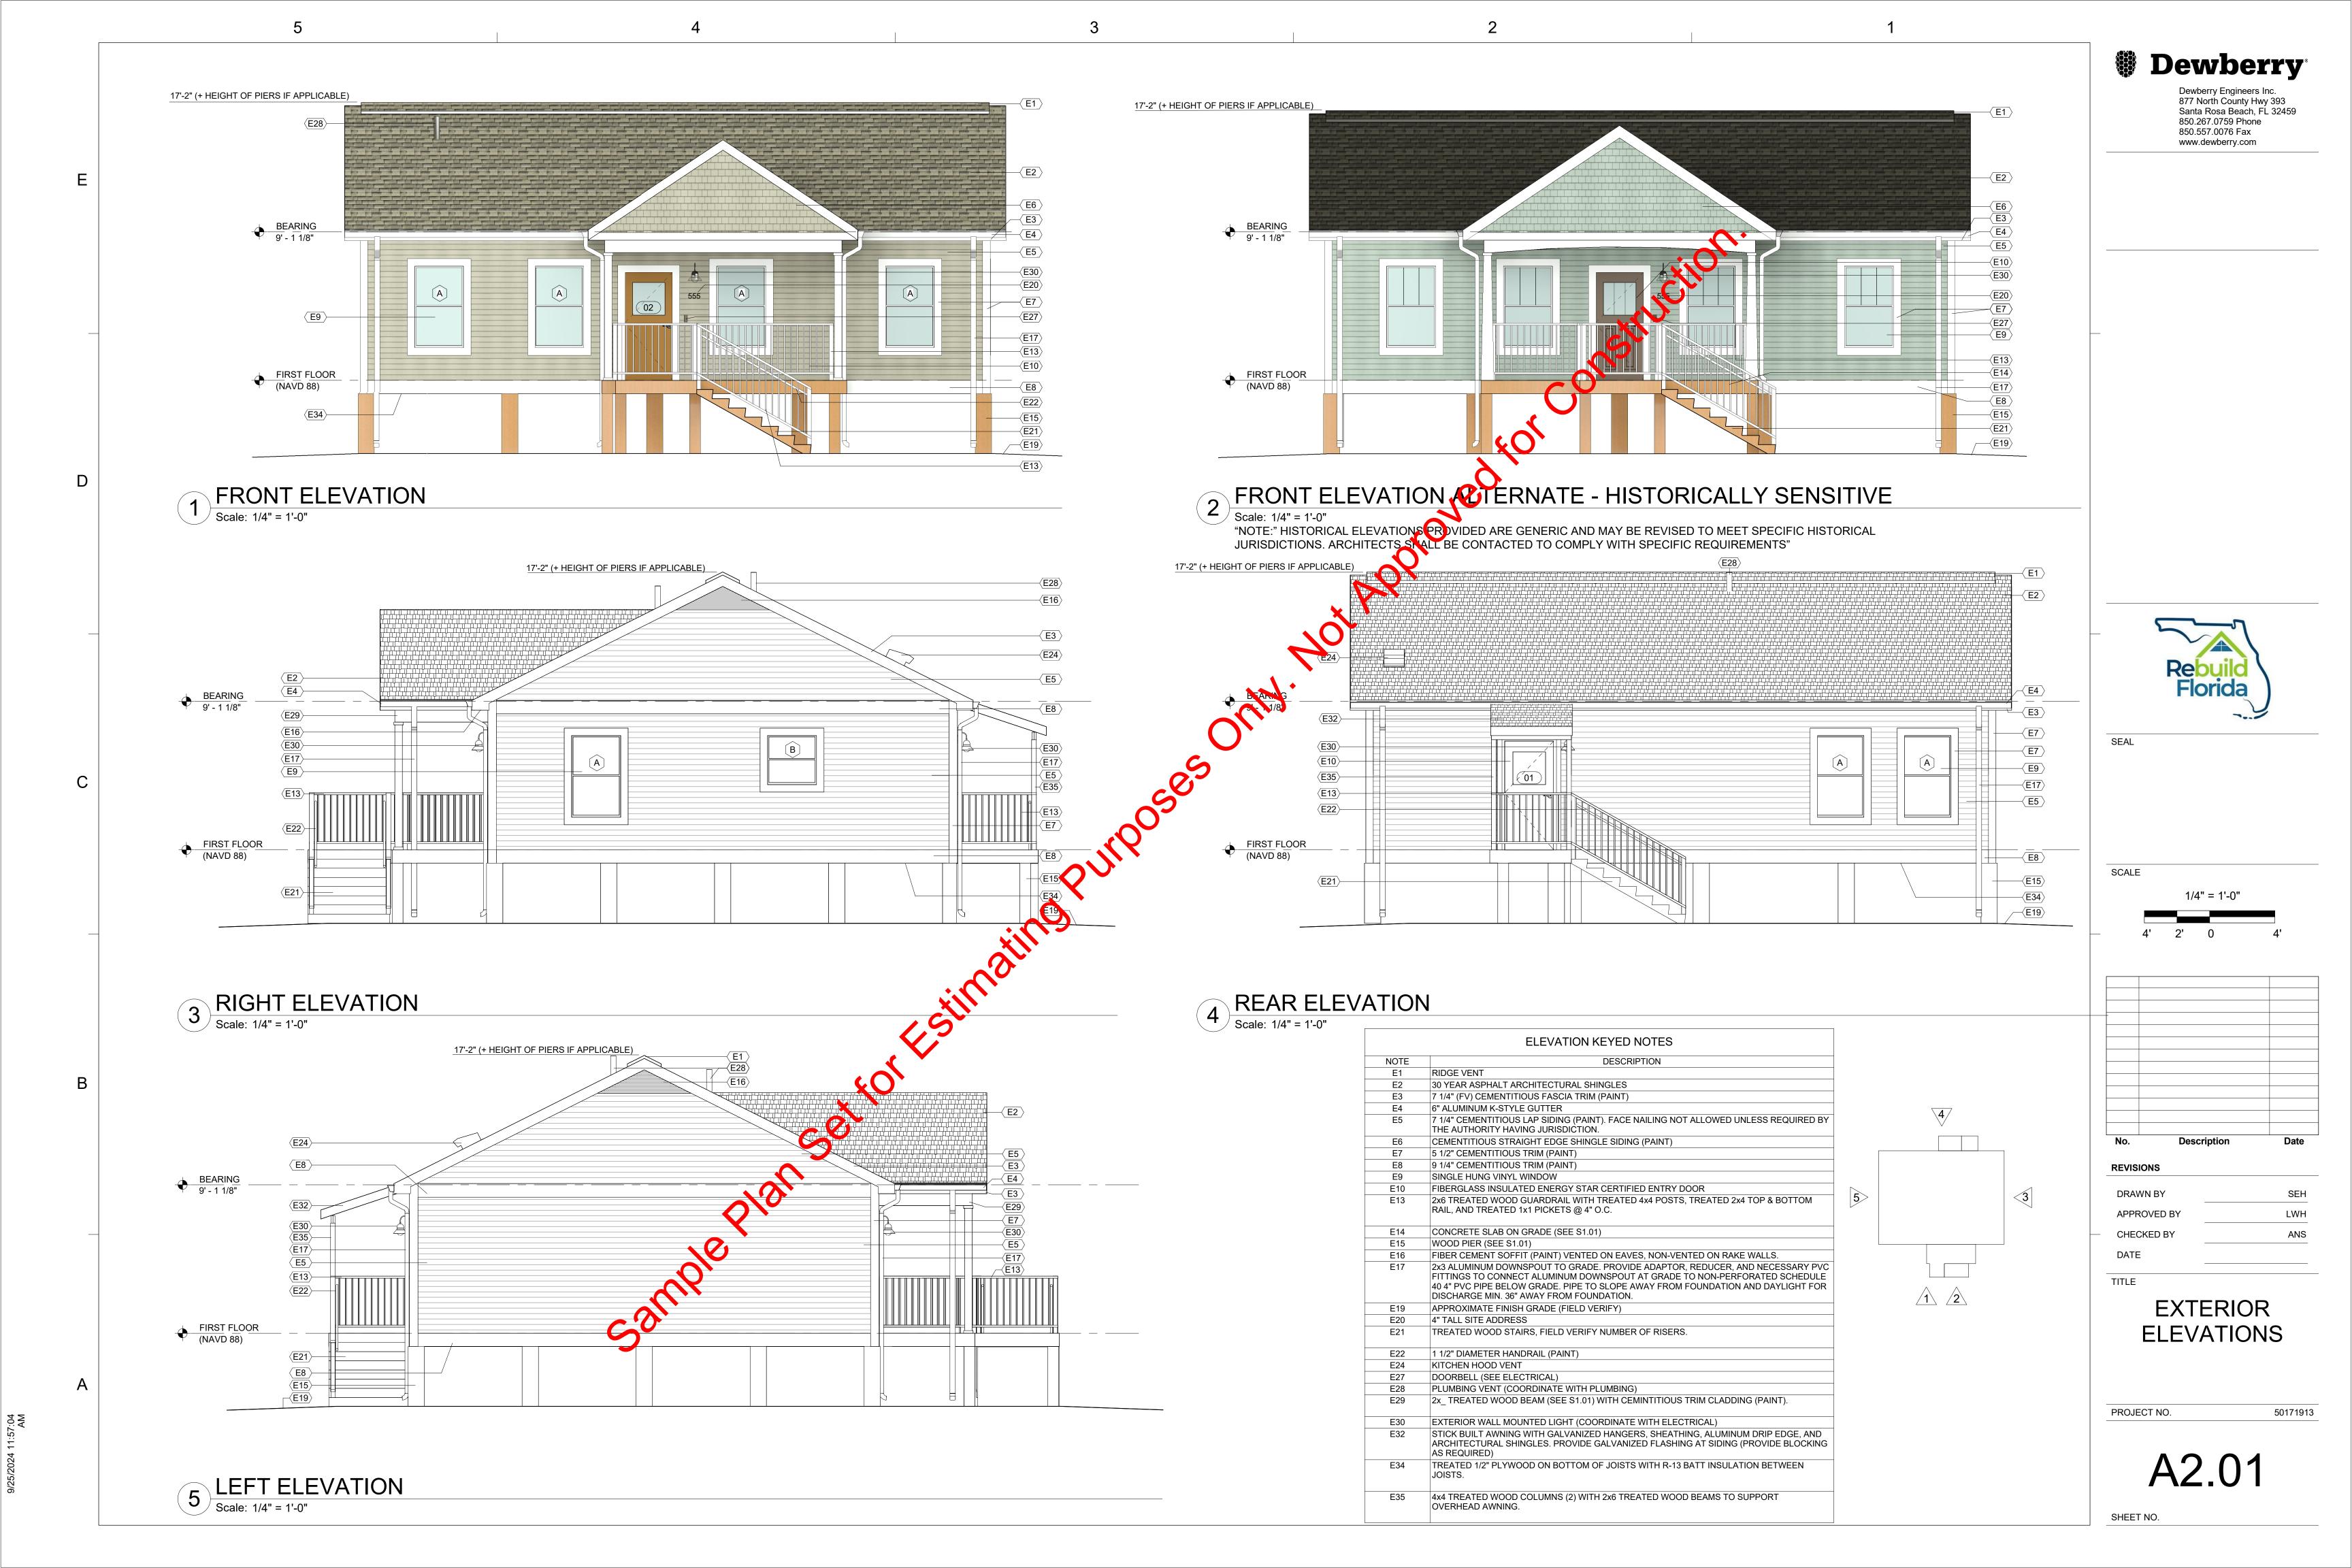

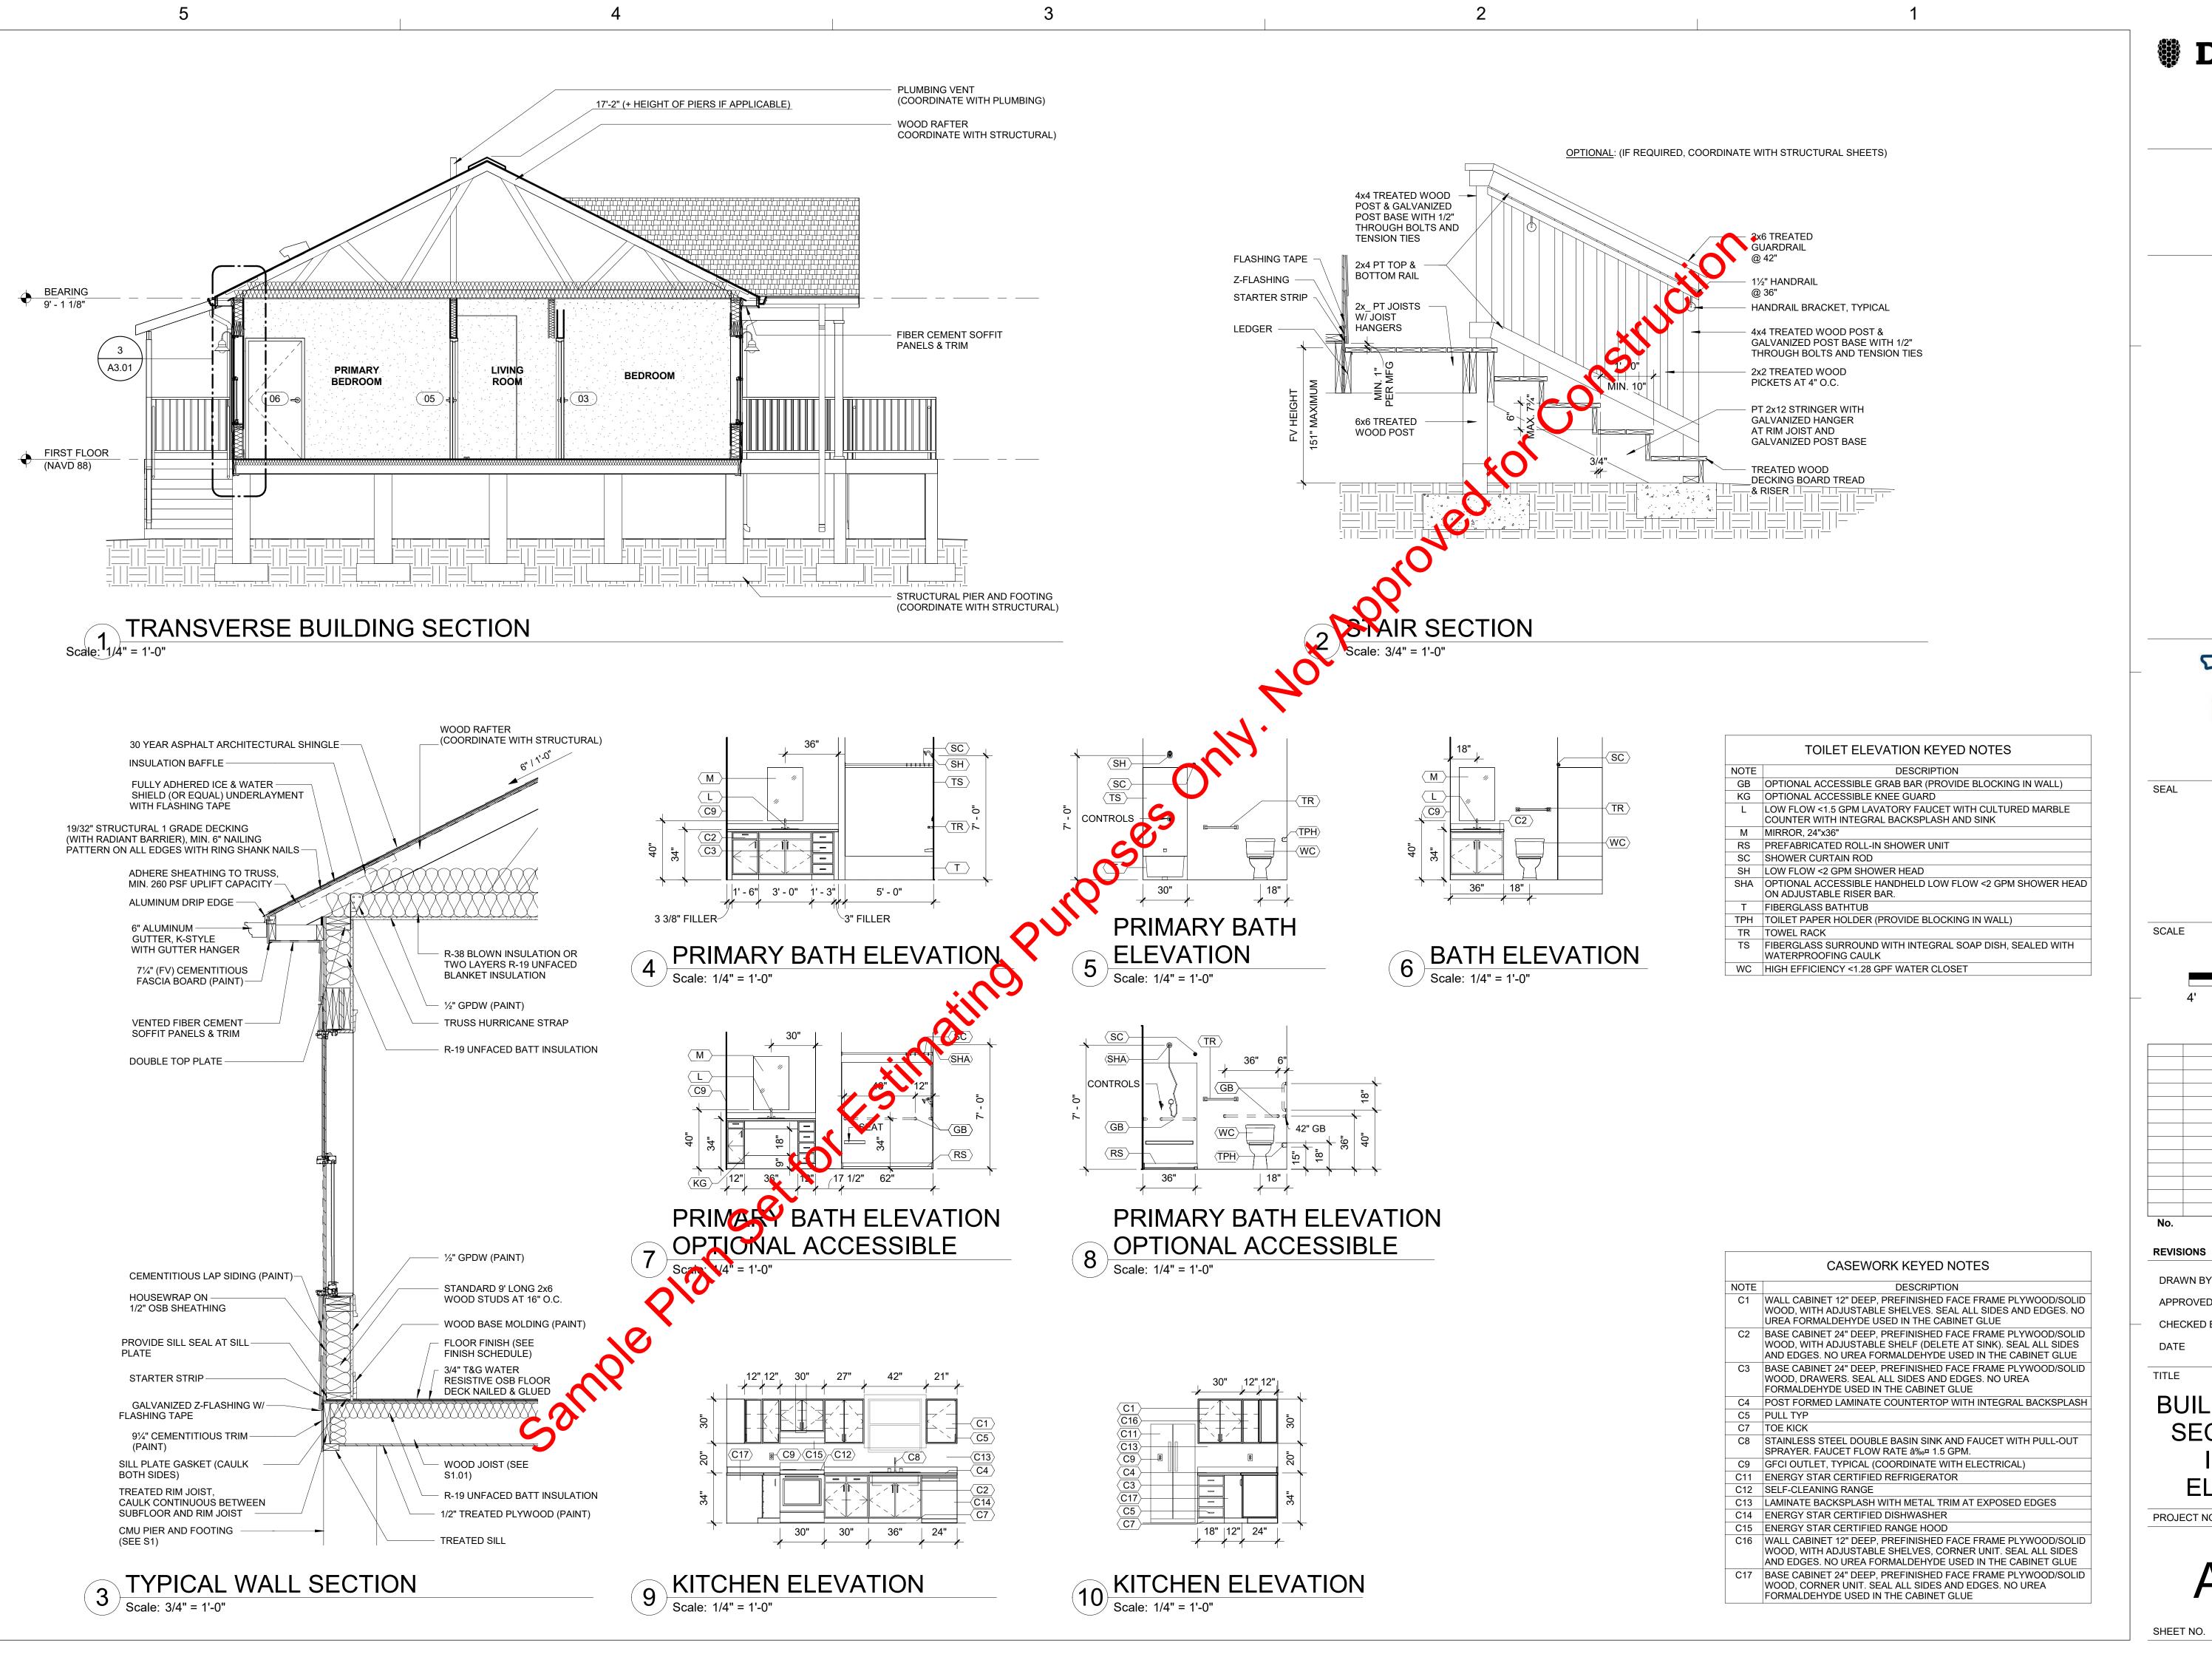

Dewberry Engineers Inc. 877 North County Hwy 393 Santa Rosa Beach, FL 32459 850.267.0759 Phone 850.557.0076 Fax www.dewberry.com

1/4" = 1'-0"

Description

REVISIONS


SEH APPROVED BY CHECKED BY ANS

BUILDING & WALL SECTIONS AND INTERIOR ELEVATIONS

PROJECT NO.

A3.01

50171913

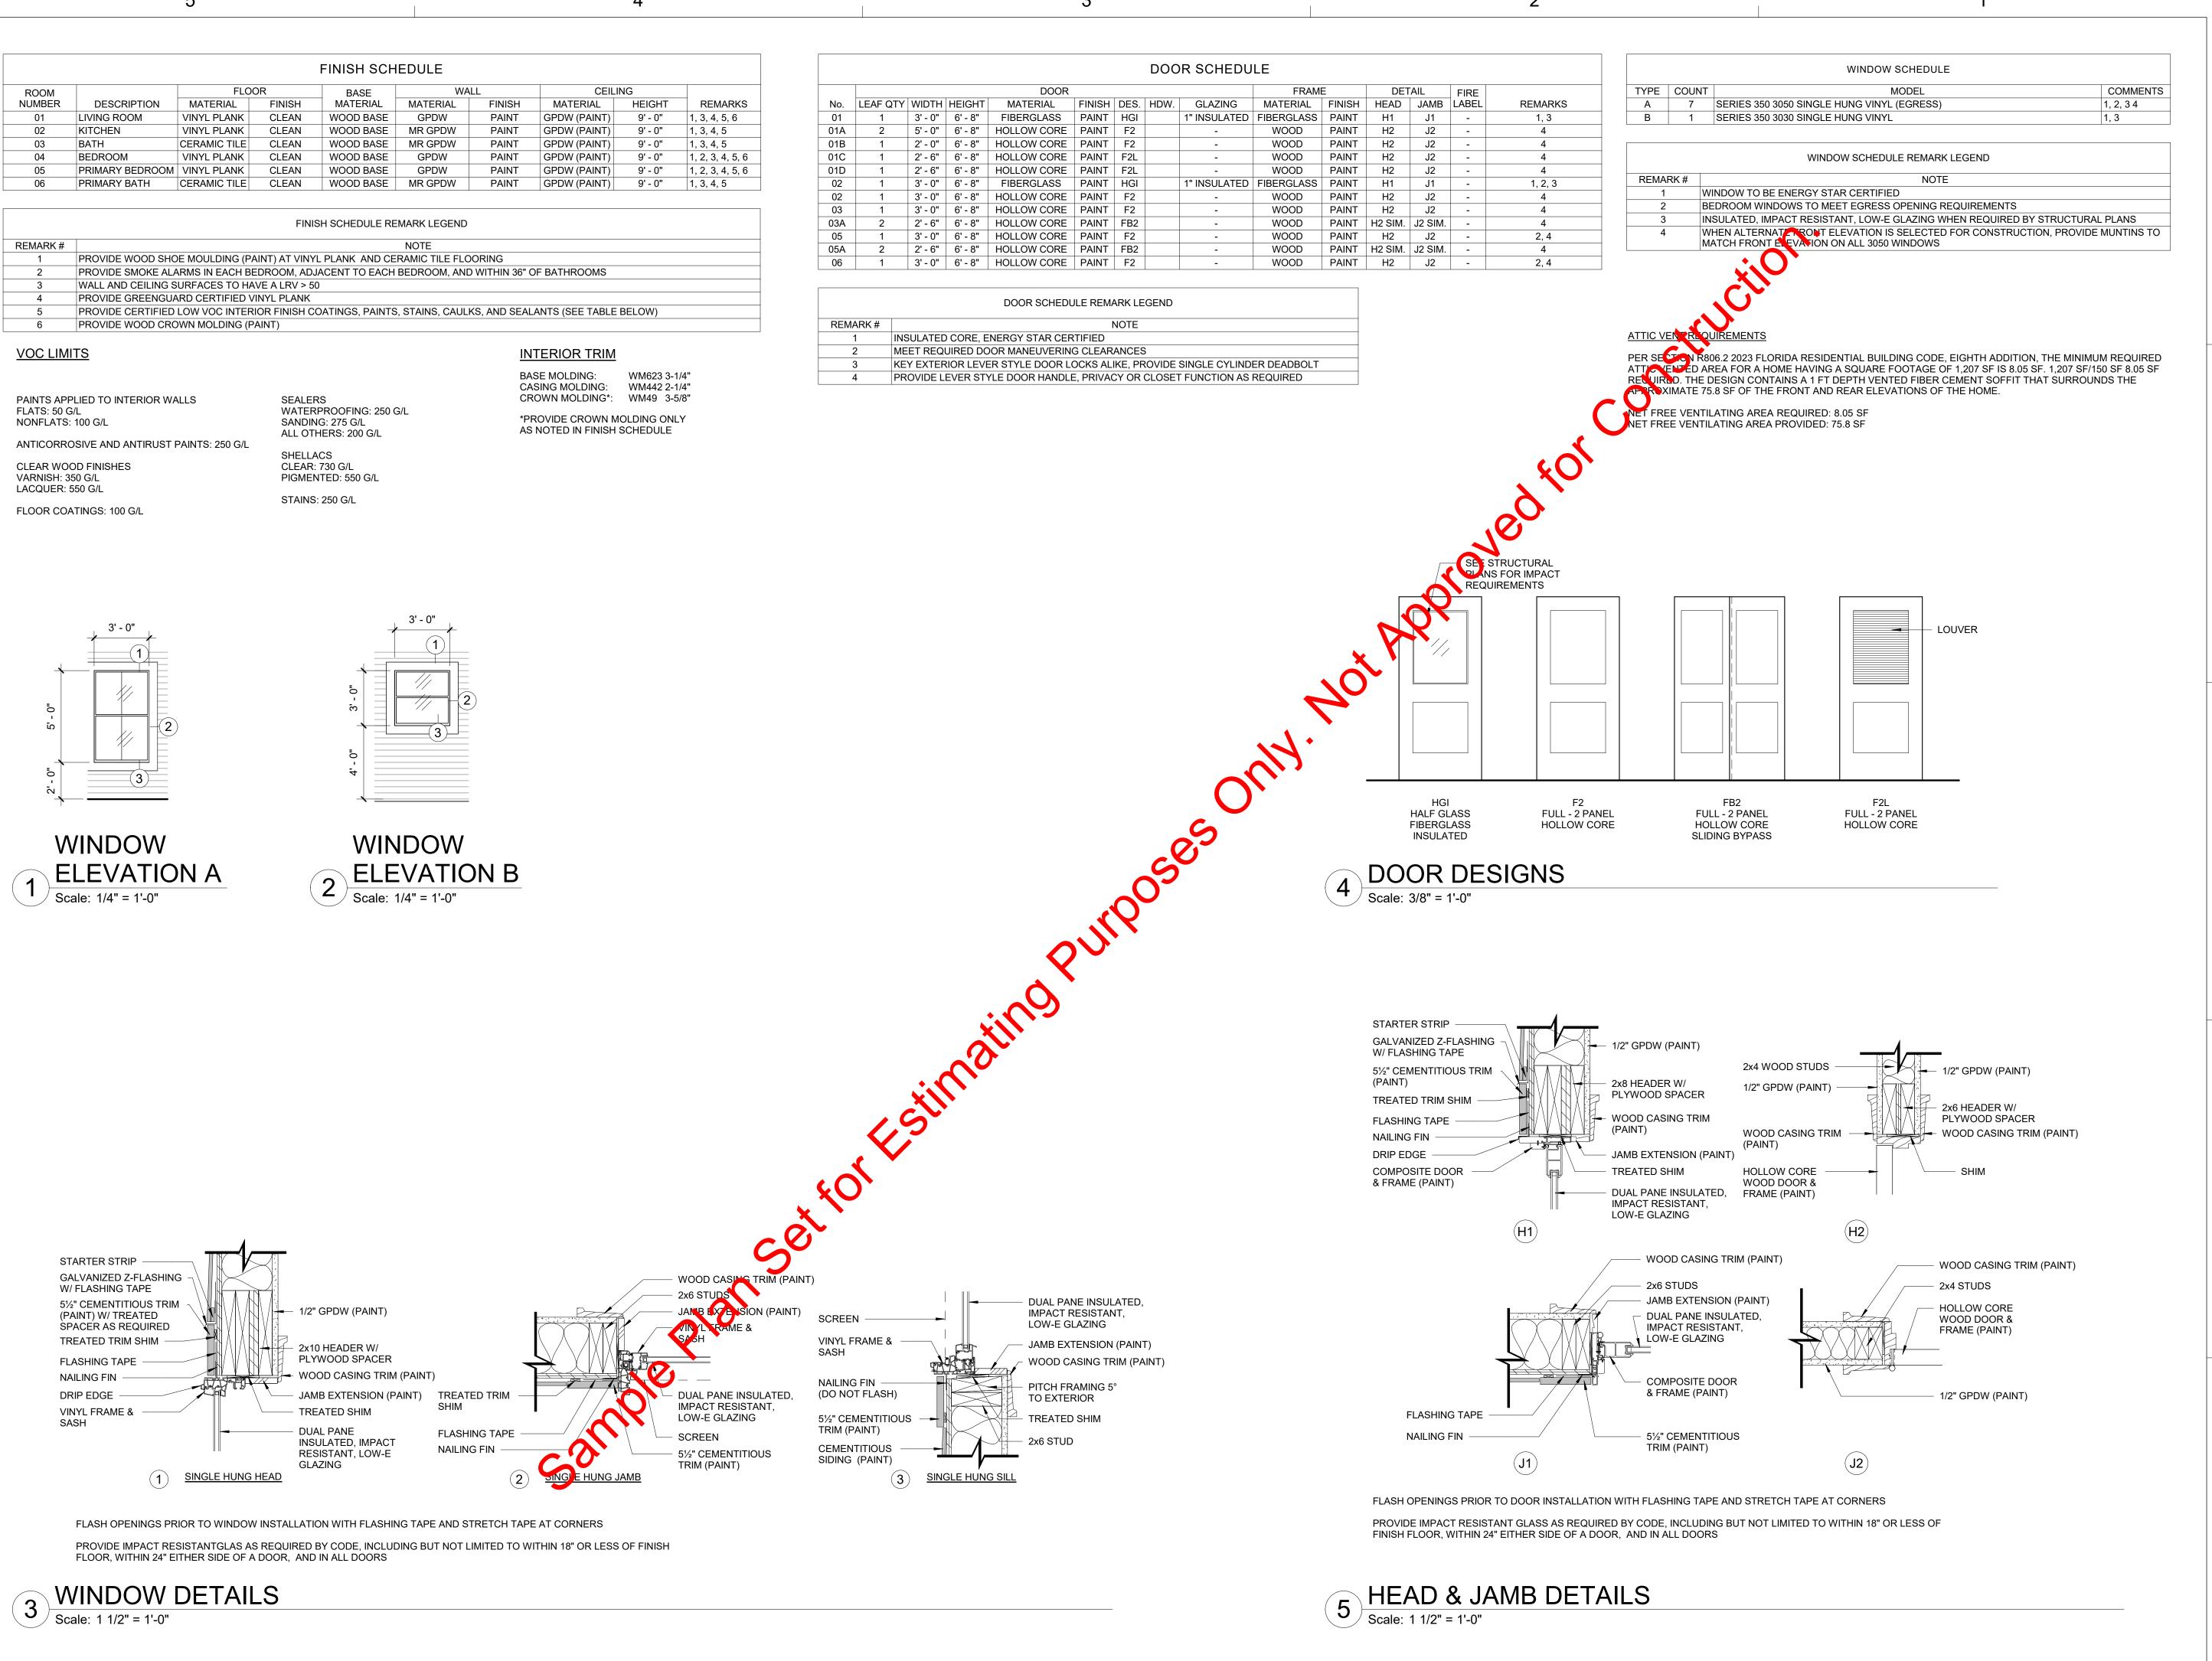

Dewberry Engineers Inc. 877 North County Hwy 393 Santa Rosa Beach, FL 32459 850.267.0759 Phone 850.557.0076 Fax www.dewberry.com

SCALE

SEAL

As indicated

Description REVISIONS SEH

DRAWN BY APPROVED BY

CHECKED BY


TITLE


FINISH, DOOR, &


WINDOW SCHEDULES

50171913 PROJECT NO.

A6.01

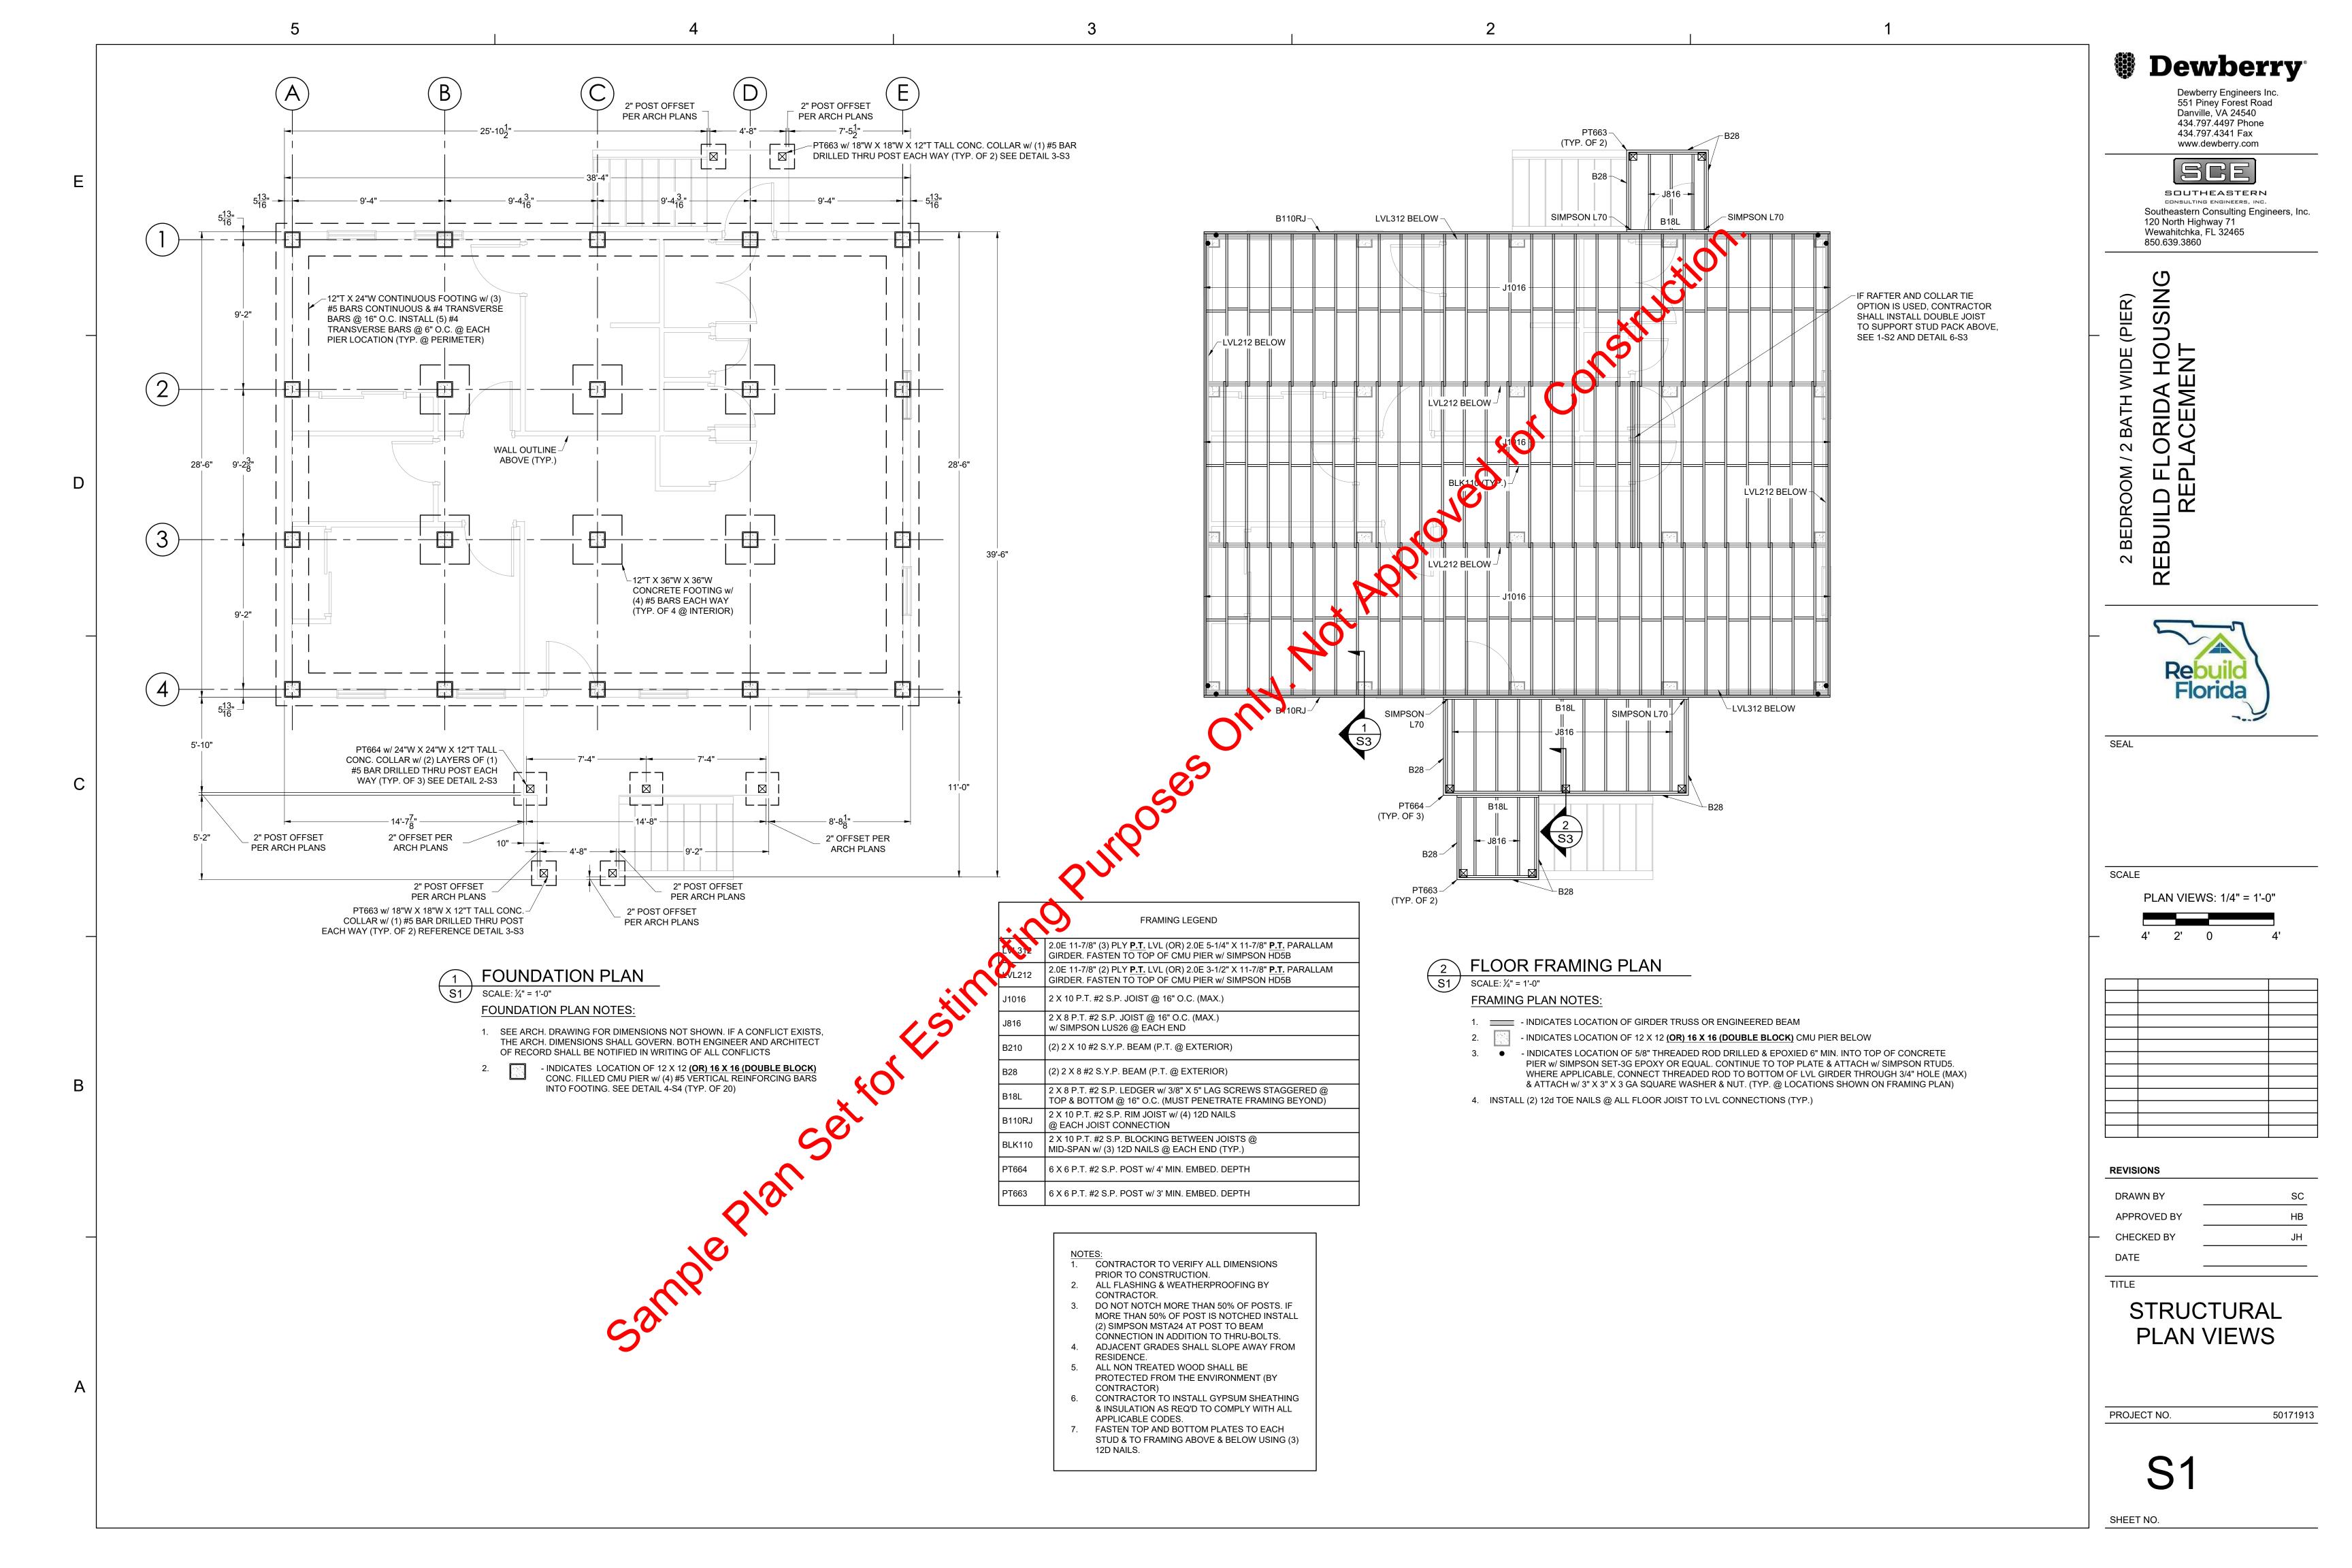

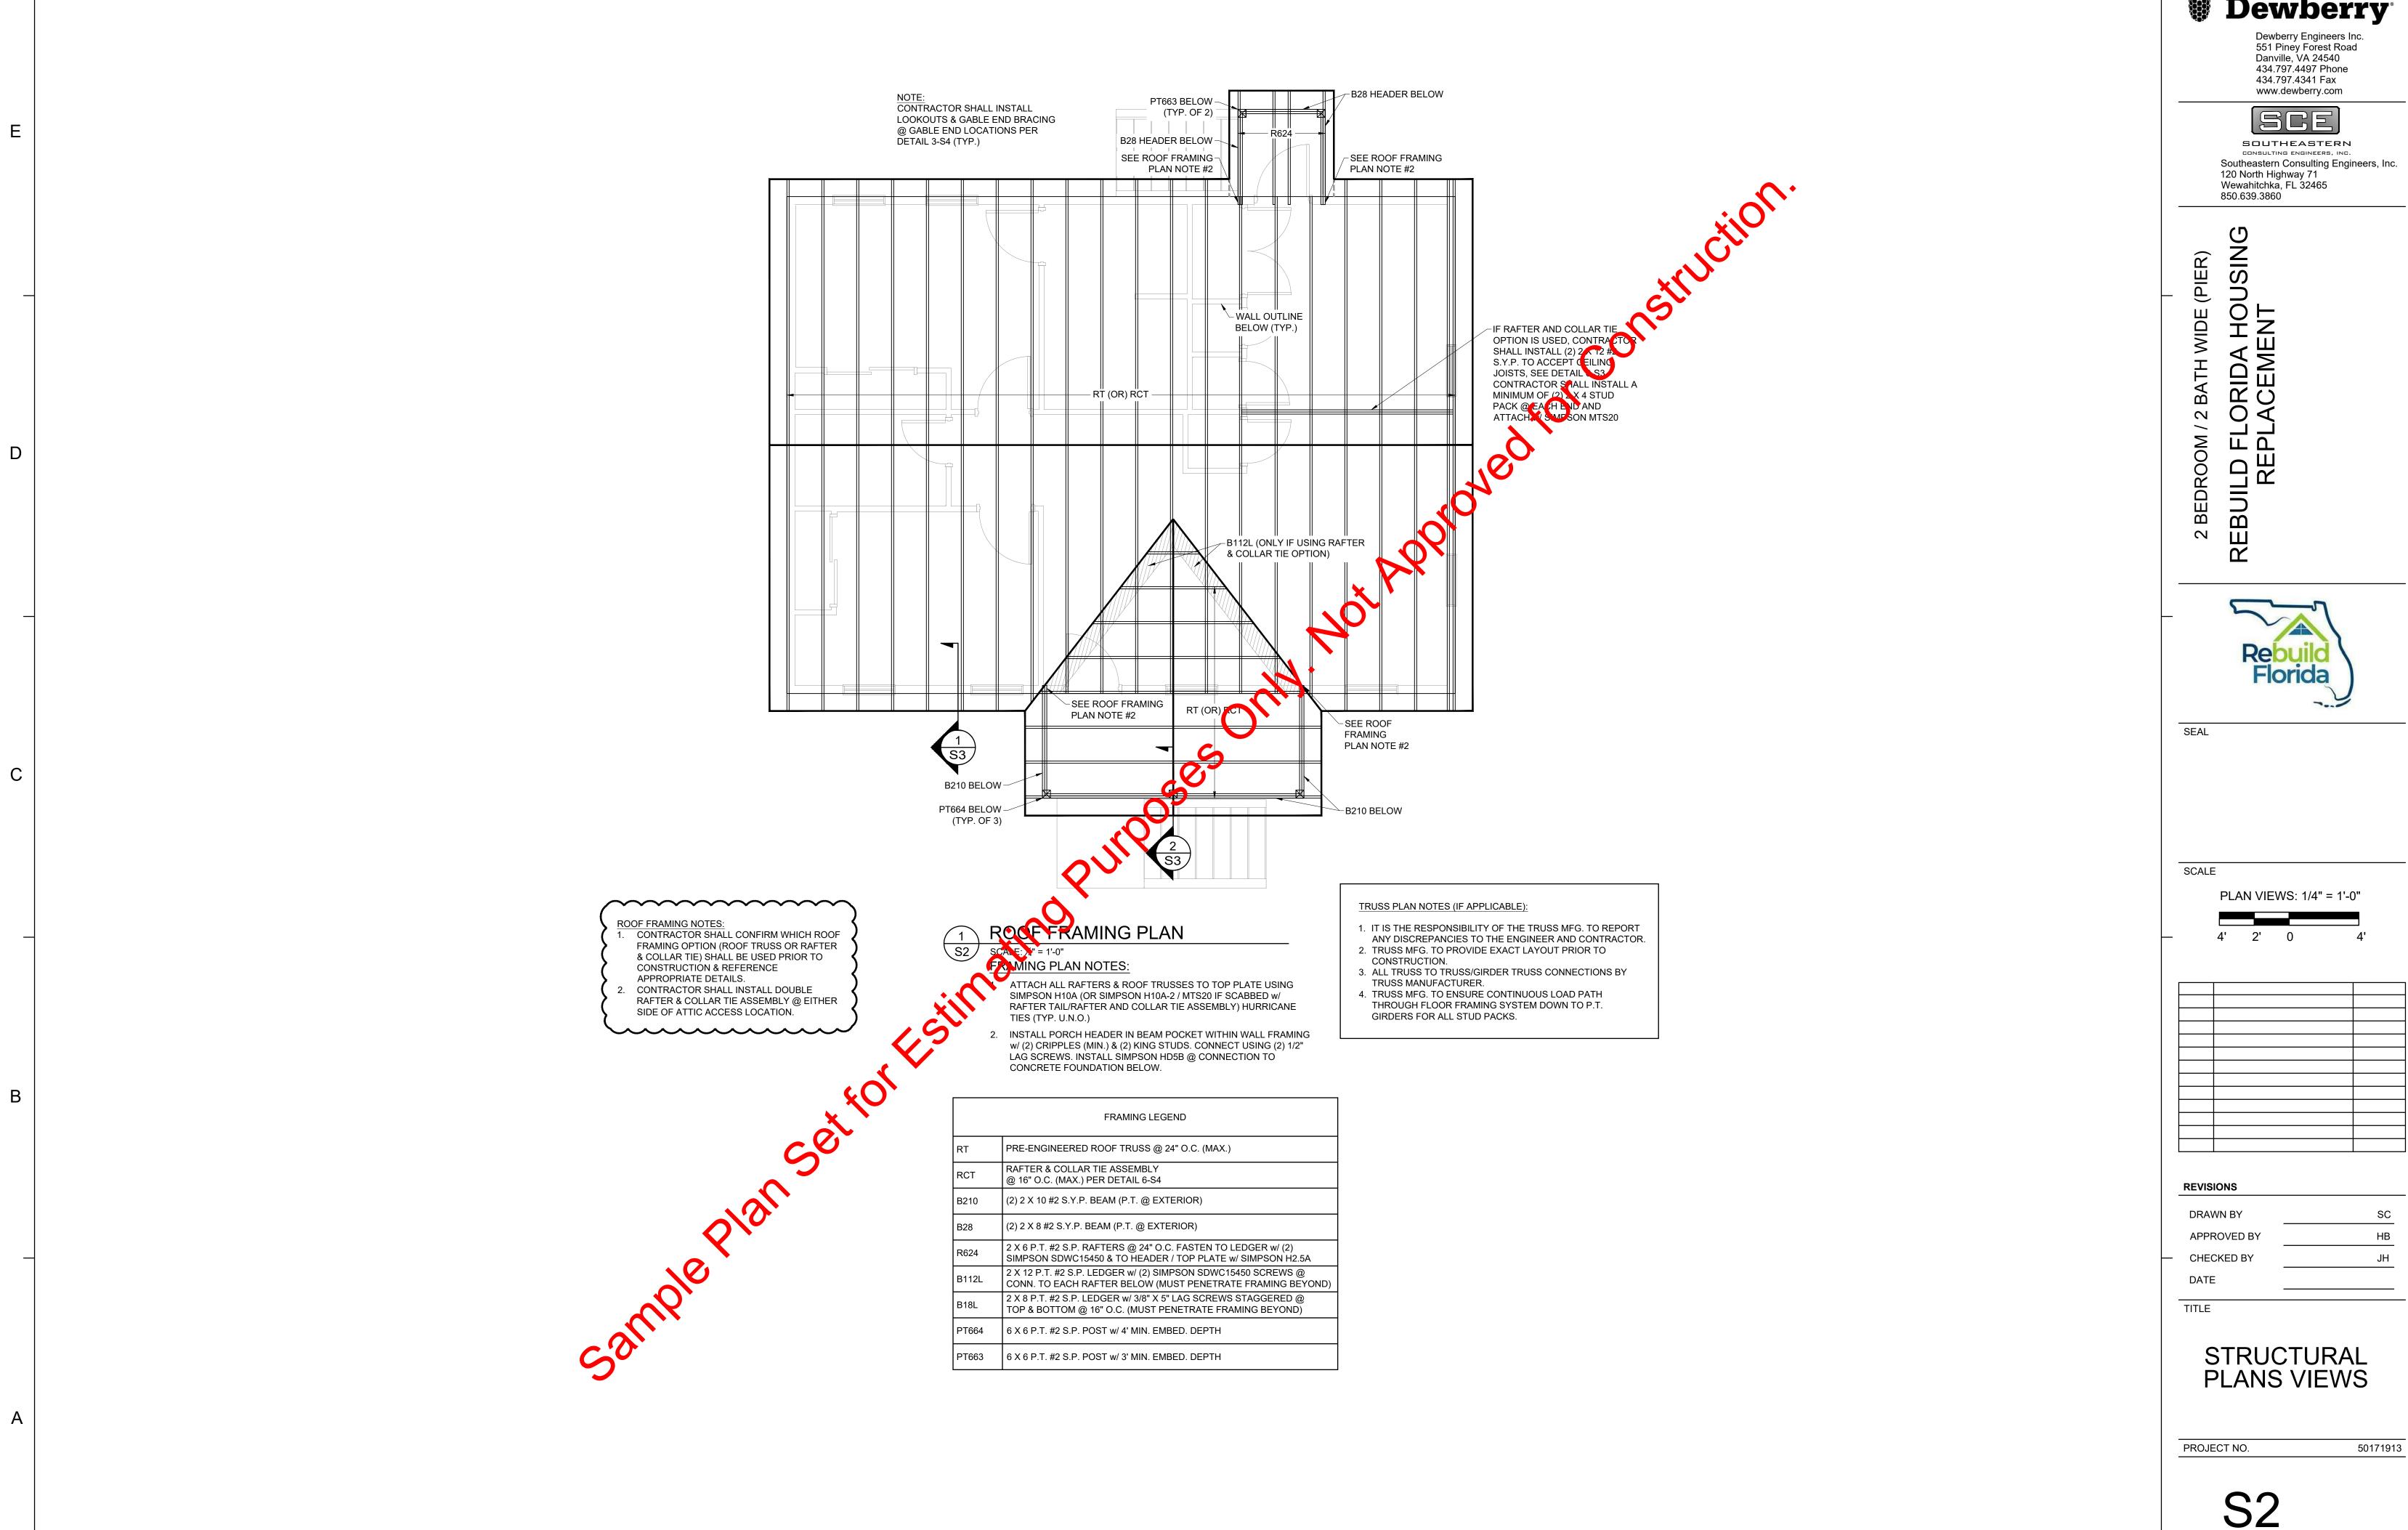

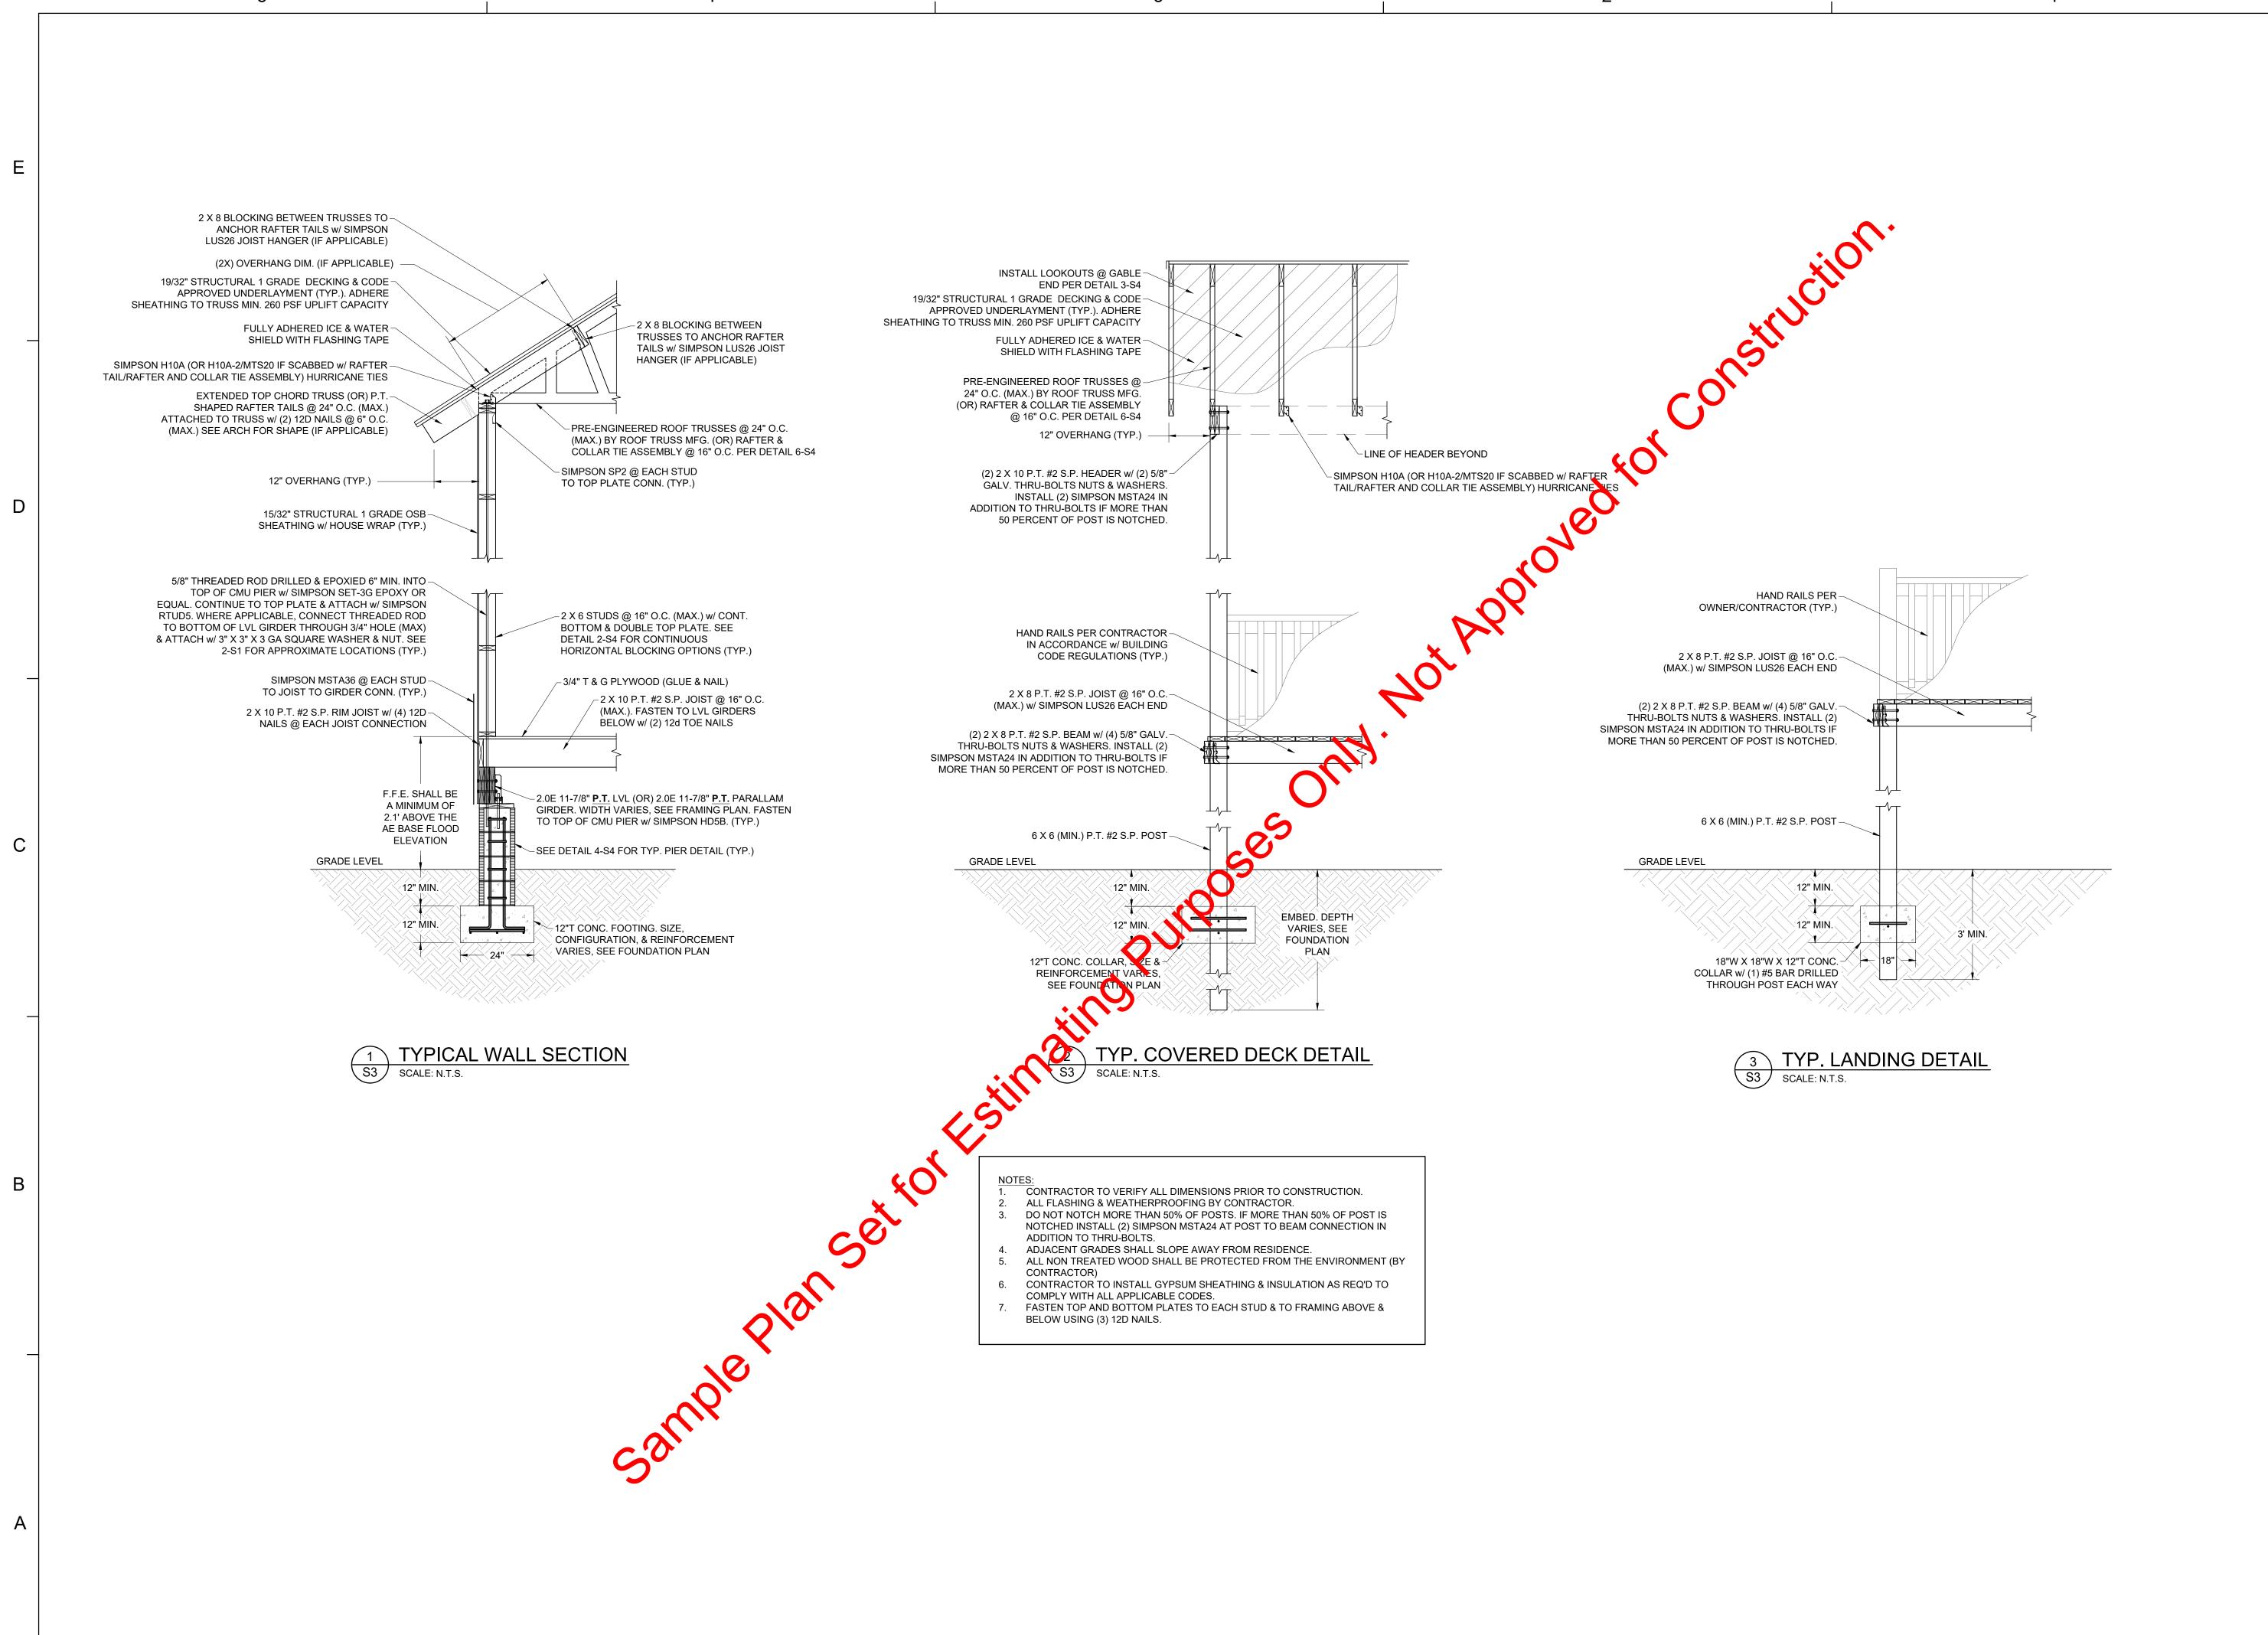

Dewberry Engineers Inc. 551 Piney Forest Road Danville, VA 24540 434.797.4497 Phone 434.797.4341 Fax www.dewberry.com

SCE

SOUTHEASTERN
CONSULTING ENGINEERS, INC.

Southeastern Consulting Engineers, Inc.
120 North Highway 71

Wewahitchka, FL 32465
850.639.3860


2 BEDROOM / 2 BATH WIDE (PIER)
REBUILD FLORIDA HOUSING
REPLACEMENT



SEAL

SCALE

PLAN VIEWS: 1/2" = 1'-0"

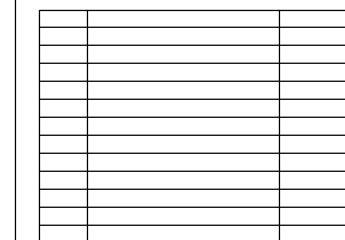

REVISIONS

DRAWN BY SC

APPROVED BY HB

CHECKED BY JH

DATE


TITLE

STRUCTURAL DETAILS

50171913

PROJECT NO.

S3

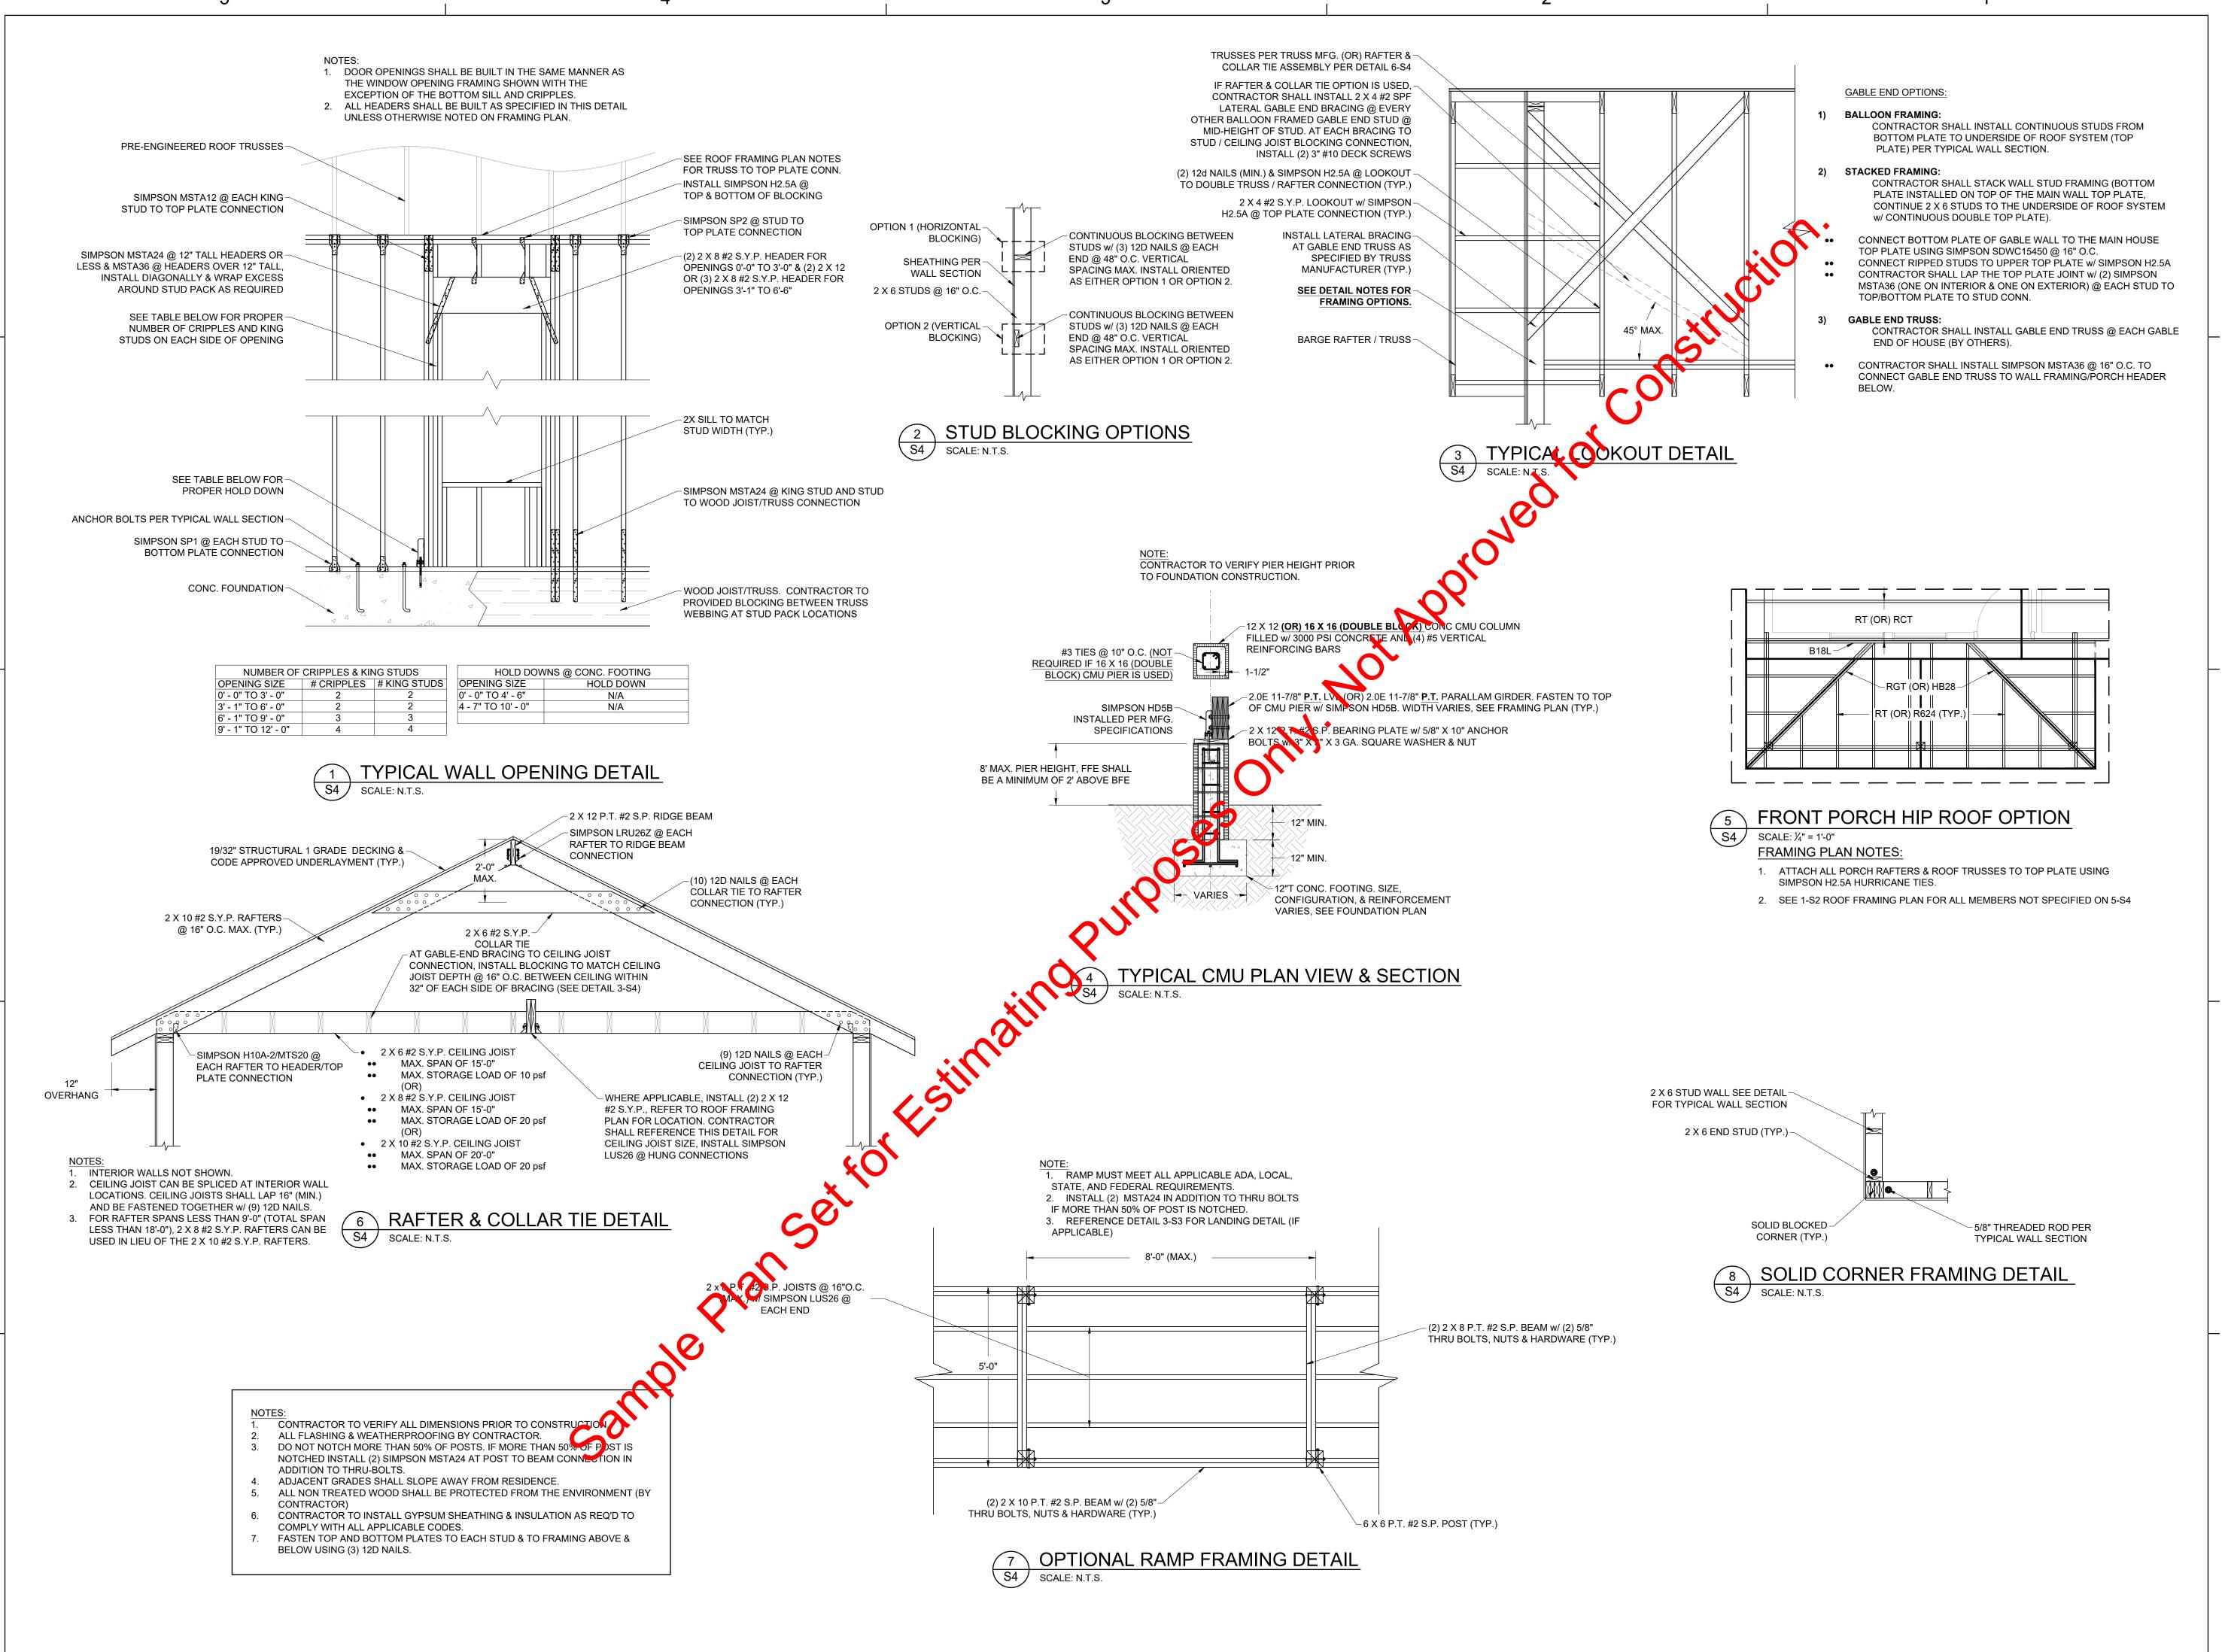



Dewberry Engineers Inc 551 Piney Forest Road Danville, VA 24540 434.797.4497 Phone 434.797.4341 Fax www.dewberry.com



SOUTHEASTERN
CONSULTING ENGINEERS, INC.

Southeastern Consulting Engineers, Inc.
120 North Highway 71

Wewahitchka, FL 32465
850.639.3860

2 BEDROOM / 2 BATH WIDE (PIER)

EBUILD FLORIDA HOUSING


REPLACEMENT



SEAL

SCALE

PLAN VIEWS: 1/4" = 1'-0"

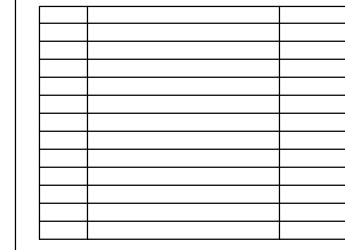

REVISIONS

DRAWN BY SC

APPROVED BY HB

CHECKED BY JH

DATE

TITLE

STRUCTURAL DETAILS

PROJECT NO. 50171913

S4

GENERAL

- THE OWNER/CONTRACTOR SHALL VERIFY AND BE RESPONSIBLE FOR ALL FINAL DIMENSIONS, PRIOR TO START. THE CONTRACTOR SHALL COORDINATE ARCHITECTURAL, MECHANICAL, ELECTRICAL, PLUMBING, AND CIVIL WORKS DOCUMENTS WITH THE STRUCTURAL CONTRACT DOCUMENTS. NOTIFICATION SHALL BE MADE TO THE ENGINEER OF RECORD OF ANY CONFLICT AND/OR OMISSIONS.
- $3.\quad$ FOR DIMENSIONS NOT SHOWN ON THE STRUCTURAL CONTRACT DOCUMENTS, SEE THE $\,$ ARCHITECTURAL PLANS.
- 4. $\,\,$ THE CONTRACTOR SHALL VERIFY EXISTING SITE CONDITIONS, DIMENSIONS, AND ELEVATIONS PRIOR TO STARTING WORK. THE ENGINEER SHALL BE NOTIFIED IN WRITING OF ANY DISCREPANCIES IN EXISTING SITE CONDITIONS, DIMENSIONS, OR ELEVATIONS TO THOSE SHOWN IN THE STRUCTURAL CONTRACT DOCUMENTS.
- THE REVIEW OF SUBMITTALS AND/OR SHOP DRAWINGS BY THE ENGINEER DOES NOT RELIEVE THE CONTRACTOR OF THE SOLE RESPONSIBILITY TO REVIEW AND CHECK SHOP DRAWINGS PRIOR TO SUBMITTAL TO THE ENGINEER. THE CONTRACTOR REMAINS SOLELY RESPONSIBLE FOR ERRORS AND OMISSIONS ASSOCIATED WITH THE PREPARATION OF SHOP DRAWINGS AS THEY PERTAIN TO MEMBER SIZES, DETAILS, AND DIMENSIONS SPECIFIED IN THE CONTRACT DOCUMENTS. THE CONTRACTOR ALSO SHALL BE RESPONSIBLE FOR MEANS, METHOD, TECHNIQUES, SEQUENCES, AND PROCEDURES OF CONSTRUCTION INCLUDING BUT NOT LIMITED TO DEMOLITION PROCEDURES AND TEMPORARY SHORING.
- THE CONTRACTOR IS SOLELY RESPONSIBLE FOR THE DESIGN, CONSTRUCTION, AND ERECTION OF SAFE AND ADEQUATE BRACING, SHORING, TEMPORARY SUPPORTS, ETC. REQUIRED FOR STABILITY OF THE STRUCTURE DURING ALL INTERMEDIATE STAGES OF CONSTRUCTION AND/OR DEMOLITION.
- IN NO CASE SHALL STRUCTURAL ALTERATIONS OR WORK AFFECTING A STRUCTURAL MEMBER BE MADE, UNLESS APPROVED BY THE ENGINEER OF RECORD IN WRITING.
- NO PROVISION OF ANY REFERENCED STANDARD SPECIFICATION, MANUAL OR CODE (WHETHER OR NOT SPECIFICALLY INCORPORATED BY REFERENCE IN THE CONTRACT DOCUMENTS) SHALL BE EFFECTIVE TO CHANGE THE DUTIES AND RESPONSIBILITIES OF OWNER, CONTRACTOR, ENGINEER, SUPPLIER, OR ANY OF THEIR CONSULTANTS, AGENTS, OR EMPLOYEES FROM THOSE SET FORTH IN THE CONTRACT DOCUMENTS. NOR SHALL IT BE EFFECTIVE TO ASSIGN TO THE STRUCTURAL ENGINEER OF RECORD OR ANY OF THE STRUCTURAL ENGINEER OF RECORD'S CONSULTANTS, AGENTS, OR EMPLOYEES ANY DUTY OR AUTHORITY TO SUPERVISE OR DIRECT THE FURNISHING OR PERFORMANCE OF THE WORK OR ANY DUTY OR AUTHORITY TO UNDERTAKE RESPONSIBILITIES CONTRARY TO THE PROVISIONS OF THE CONTRACT
- CONTRACT DOCUMENTS INCLUDE, BUT ARE NOT LIMITED TO, THE STRUCTURAL DOCUMENTS (DRAWINGS AND SPECIFICATIONS), BUT DO NOT INCLUDE SHOP DRAWINGS, VENDOR DRAWINGS, OR MATERIAL PREPARED AND SUBMITTED BY THE CONTRACTOR
- 10. REFERENCE TO STANDARD SPECIFICATIONS OF ANY TECHNICAL SOCIETY, ORGANIZATION, OR ASSOCIATION OR TO CODES OF LOCAL OR STATE AUTHORITIES, SHALL MEAN THE LATEST STANDARD, CODE, SPECIFICATION OR TENTATIVE SPECIFICATION ADOPTED AT THE DATE OF TAKING BIDS, UNLESS SPECIFICALLY STATED OTHERWISE
- 11. CONTRACT DOCUMENTS SHALL GOVERN IN THE EVENT OF A CONFLICT WITH THE CODE OF PRACTICE OR SPECIFICATIONS OF ACI, PCI, AISC, SJI OR OTHER STANDARDS. WHERE A CONFLICT OCCURS WITHIN THE CONTRACT DOCUMENTS, THE STRICTEST REQUIREMENT SHALL GOVERN.
- 12. MATERIAL, WORKMANSHIP, AND DESIGN SHALL CONFORM TO THE REFERENCED BUILDING CODE.
- 13. CONTRACTOR SHALL OBTAIN AND COORDINATE EDGE OF SLAB DIMENSIONS, OPENING LOCATIONS AND DIMENSIONS, DEPRESSED SLAB LOCATIONS AND EXTENTS, SLAB SLOPES, CURB LOCATIONS, AND CMU WALL LOCATIONS. ARCHITECT/STRUCTURAL ENGINEER SHALL BE NOTIFIED OF ANY DISCREPANCY OR OMISSION.
- 14. CONTRACTOR HAS SOLE RESPONSIBILITY FOR MEANS, METHODS, SAFETY, TECHNIQUES, SEQUENCES, AND PROCEDURES OF CONSTRUCTION.
- 15. CONTRACTOR HAS SOLE RESPONSIBILITY TO COMPLY WITH ALL OSHA REGULATIONS.
- 16. REPRODUCTION OF STRUCTURAL DRAWINGS FOR SHOP DRAWINGS IS NOT PERMITTED. ELECTRONIC DRAWING FILES WILL NOT BE PROVIDED TO THE CONTRACTOR.
- 17. SUBMIT SHOP DRAWINGS WHICH ADEQUATELY DEPICT THE STRUCTURAL ELEMENTS AND CONNECTIONS SHOWN IN THE CONTRACT DOCUMENTS. SHOP DRAWINGS SHALL BE SEALED BY ENGINEER LICENSED IN THE PROJECT STATE. REVIEW OF SHOP DRAWINGS SHALL BE FOR CONFORMANCE WITH THE CONTRACT DOCUMENTS REGARDING ARRANGEMENT AND SIZES OF MEMBERS AND THE CONTRACTOR'S INTERPRETATION OF THE DESIGN LOADS AND CONTRACT DOCUMENT DETAILS. REVIEW OF SUBMITTALS OR SHOP DRAWINGS BY THE ARCHITECT/STRUCTURAL ENGINEER DOES NOT RELIEVE THE CONTRACTOR OF THE SOLE RESPONSIBILITY TO REVIEW AND CHECK ALL SUBMITTALS AND SHOP DRAWINGS BEFORE SUBMITTING TO THE STRUCTURAL ENGINEER. REVIEW OF SUBMITTALS OR SHOP DRAWINGS BY THE ARCHITECT/STRUCTURAL ENGINEER DOES NOT RELIEVE THE CONTRACTOR OF FULL RESPONSIBILITY FOR COMPLIANCE WITH THE CONTRACT DOCUMENTS. CONTRACTOR REMAINS SOLELY RESPONSIBLE FOR ERRORS AND OMISSIONS ASSOCIATED WITH THE PREPARATION OF SHOP DRAWINGS AS THEY PERTAIN TO MEMBER SIZES, DETAILS, AND DIMENSIONS SPECIFIED IN THE CONTRACT DOCUMENTS. SHOP DRAWINGS SHALL BE SEALED BY ENGINEER LICENSED IN PROJECT STATE.
- 18. WHERE A SECTION OR DETAIL IS SHOWN OR DETAILED FOR ONE CONDITION, IT SHALL APPLY TO ALL SIMILAR AND LIKE CONDITIONS. DETAILS LABELED "TYPICAL" ON THE STRUCTURAL DRAWINGS APPLY TO ALL SITUATIONS OCCURRING ON THE PROJECT THAT ARE THE SAME OR SIMILAR. THE CONTRACTOR SHALL CONSIDER ALL OF THE CONTRACT DOCUMENTS IN DETERMINING SIMILAR AND LIKE CONDITIONS.
- 19. ALL FLASHING AND WATERPROOFING BY CONTRACTOR.
- 20. ALL ADA REQUIREMENTS SHALL BE ADHERED (IF APPLICABLE) TO AND MAY NOT BE SHOWN ON THESE PLANS IN ITS ENTIRETY.
- 21. PLANS DO NOT INCLUDE ANY FIRE ESCAPE PLAN, FIRE SPRINKLER, OR FIRE RELATED DESIGN ASPECTS, U.N.O.. OWNER/CONTRACTOR SHALL PROVIDE APPLICABLE FIRE PROTECTION DESIGN/DOCUMENTS NOT SHOWN ON THIS PLAN
- 22. OWNER/CONTRACTOR SHALL BE RESPONSIBLE FOR ALL THRESHOLD INSPECTION REQUIREMENTS (IF APPLICABLE).
- 23. ATTACH STAIR STRINGERS & LANDING FRAMING TO STAIRWELL STUD FRAMING w/ (2) SIMPSON SDWC15600 @ 16" O.C.
- 24. INSTALL LATERAL BRACING AT GABLE END TRUSS AS SPECIFIED BY TRUSS MANUFACTURER

CODE DESIGN

WIND LOADS: SEE TABLE

ESTIMATED DEFLECTIONS (IN INCHES) ARE AS FOLLOWS: LIVE LOAD DEAD + LIVE LOAD ROOF MEMBERS: L/240 OR < 1" L/180

FLOOR MEMBERS: L/360 OR $< \frac{1}{2}$ " L/240 WHERE, L = SPAN LENGTH (IN INCHES) BETWEEN CENTERLINES OF SUPPORTS. (FOR CANTILEVERS, L IS TWICE THE LENGTH OF THE CANTILEVER.)

FOUNDATION

- FOUNDATION DESIGN IS BASED ON AN ASSUMED ALLOWABLE BEARING PRESSURE OF 2000 PSF. STRUCTURAL ENGINEER IS NOT RESPONSIBLE FOR SUBSURFACE CONDITIONS ENCOUNTERED IN THE FIELD DIFFERENT FROM THOSE ASSUMED
- ALL FOUNDATION BEARING SOIL SHALL BE COMPACTED TO 98% STANDARD PROCTOR OR 95% MODIFIED PROCTOR AS SPECIFIED BY AASHTO T-99 AND AASHTO T-180, RESPECTIVELY.
- UNLESS OTHERWISE NOTED, ALL CONSTRUCTION JOINTS SHALL BE CONSTRUCTED w/ 3/4" X 3/4" (MIN.) KEY WAY. ALL SURFACES SHALL BE CLEANED BEFORE PLACEMENT OF ADJACENT CONCRETE. CONTRACTION JOINTS / SAW CUTS SHALL BE INSTALLED AT 10' O.C. EACH WAY OR NO GREATER THAN 30 TIMES THE SLAB THICKNESS (LESSER OF THE TWO) AND SHALL BE A MINIMUM OF 1/8" WIDE AND TO A DEPTH OF 25% OF THE SLAB THICKNESS (MIN.) UNLESS OTHERWISE NOTED. ALL CONCRETE SLABS LOCATED WITHIN VE FLOOD ZONES SHALL BE SCORED IN 25 SQ. FT. SECTIONS (MAXIMUM). REFER TO F.D.E.P. PERMIT DRAWINGS FOR ALL CONCRETE SLABS LOCATED SEAWARD OF THE COASTAL CONSTRUCTION CONTROL LINE.
- 4. STRUCTURAL TESTING/INSPECTION AGENCY SHALL CERTIFY THE BEARING MEDIUM BEFORE STARTING CONSTRUCTION.
- 5. NO FOOTINGS SHALL BE PLACED IN WATER. ANY SOIL CONDITION ENCOUNTERED DURING EXCAVATION THAT IS CONTRARY TO THE CONDITIONS USED FOR DESIGN OF
- FOOTINGS AS OUTLINED IN THESE NOTES OR ON THE DRAWINGS SHALL BE BROUGHT TO THE ATTENTION OF THE ARCHITECT OR ENGINEER OF RECORD BEFORE PROCEEDING.
- BACK FILL BOTH SIDES OF FOUNDATION WALLS AT SAME TIME TO PREVENT OVERTURNING.

CONCRETE MASONRY

- CONCRETE MASONRY WORK SHALL CONFORM TO ACI 530, BUILDING CODE REQUIREMENTS FOR MASONRY STRUCTURI S AND ACI 530.1, SPECIFICATION FOR MASONRY STRUCTURES.
- MINIMUM COMPRESSIVE STRENGTH OF CONCRETE MASONRY SHALL BE F'M = 1,500 PSI.
- MORTAR SHALL COMPLY WITH THE BUILDING CODE REQUIREMENTS FOR CONCRETE MASONRY AND SHALL BE OF THE FOLLOWING TYPE:

WALLS BELOW GRADE TYPE M OR S

- I. CONCRETE MASONRY UNITS SHALL BE GROUTED WITH 2,500 PSI COARSE GROUT AS SHOWN IN THE STRUCTURAL DOCUMENTS. GROUT SHALL CONFORM TO ASTM C476.
- PROVIDE HORIZONTAL JOINT REINFORCEMENT WITH NO. 9 GAGE LONGITUDINAL WIRES AT 16" VERTICALLY, UNLESS NOTED OTHERWISE. PROVIDE SPECIAL ACCESSORIES FOR CORNERS, INTERSECTIONS, ETC.
- MINIMUM VERTICAL WALL REINFORCEMENT SHALL BE #5 @32" UNLESS NOTED OTHERWISE.
- 7. DEFECTIVE AREAS IN CONCRETE INCLUDING, BUT NOT LIMITED TO, HONEY-COMBING, SPALLS, AND CRACKS WITH WIDTHS EXCEEDING 0.01 INCH SHALL BE REPAIRED. EXTENTS OF DEFECTIVE AREA TO BE DETERMINED BY THE STRUCTURAL
- 8. REINFORCING DOWELS MUST BE TIED IN PLACE PRIOR TO POURING FOOTING. "WET-STICKING" IS NOT ALLOWED.


- REINFORCING STEEL SHALL CONFORM TO ASTM A615, GRADE 60, UNLESS NOTED OTHERWISE
- WELDED WIRE FABRIC SHALL CONFORM TO ASTM A185 AND HAVE MINIMUM SIDE AND END LAPS OF 8".FOR ALL MONOLITHIC FOOTINGS, A DOUBLE LAYER OF WELDED WIRE FABRIC SHALL BE INSTALLED WITHIN 3'-0" OF ALL FOOTINGS (3" CLEAR OF OUTSIDE PERIMETER OF FOOTING)
- REINFORCING STEEL SHALL ONLY BE WELDED OR TACK-WELDED IF IT CONFORMS TO ASTM A706, AND AWS D1.4. REINFORCING SHALL NOT BE WELDED NOR TACK-WELDED UNLESS APPROVED BY THE STRUCTURAL
- SUBMIT SHOP DRAWINGS WHICH ADEQUATELY DEPICT THE REINFORCING BAR SIZES AND PLACEMENT WRITTEN DESCRIPTION OF REINFORCEMENT WITHOUT ADEQUATE SECTIONS, ELEVATIONS, AND DETAILS IS NOT ACCEPTABLE.
- PROVIDE DOWELS FROM FOUNDATIONS THE SAME SIZE AND NUMBER AS THE VERTICAL WALL OR COLUMN REINFORCING, UNLESS NOTED OTHERWISE. REINFORCING DOWELS MUST BE TIED IN PLACE PRIOR TO POURING FOOTING. "WET-STICKING" IS NOT ALLOWED.
- PLACE REINFORCEMENT AS FOLLOWS, UNLESS NOTED OTHERWISE
- 6.1. CAST-IN-PLACE (NON POST-TENSIONED) CONCRETE REINFORCEMENT COVER

PERMANENTLY EXPOSED TO EARTH:	
CAST AGAINST THE EARTH	3" CLEAF
EXPOSED TO EARTH OR WEATHER:	
FOR BARS LARGER THAN A NO. 5 BAR	2" CLEAF
NO. 5 BARS OR SMALLER	1 ½" CLE/
COLUMN TIES	1 3/4" CLE

- 6.2. MASONRY REINFORCING STEEL SHALL BE PLACED IN THE CENTER OF CMU CELLS, UNLESS NOTED OTHERWISE.
- REINFORCEMENT SHALL BE SPLICED ONLY AT LOCATIONS SHOWN OR NOTED IN THE STRUCTURAL DOCUMENTS, EXCEPT REINFORCEMENT MARKED "CONTINUOUS" CAN BE SPLICED AT LOCATIONS DETERMINED BY CONTRACTOR. SPLICES AT OTHER LOCATIONS SHALL BE APPROVED IN WRITING BY THE STRUCTURAL ENGINEER. REINFORCING STEEL SPLICES SHALL BE AS FOLLOWS, UNLESS NOTED OTHERWISE:

MINIMUM LAP SPLICE LENGTH (IN.) - 3000 PSI CONCRETE								
	No. 3	No. 4	No. 5	No. 6	No. 7	No. 8		
	22	29	36	43	63	72		
	MINIMUN	I LAP SPLICE L	ENGTH (IN.) -	1500 PSI NORM	AL WEIGHT CI	MU		
6-in CMU WALL	19	25	39	81	NA	NA		
8-in CMU WALL	19	25	31	57	79	113		
12-in CMU WALL	19	25	31	53	61	75		

RECOMMENDED END HOOKS ANCHORAGE LENGTH (IN.) - 3000 PSI CONCRETE							
	No. 3	No. 4	No. 5	No. 6	No. 7	No. 8	
D	2.25	3.00	3.75	4.50	5.25	6.00	
A or G	6	8	10	12	14	16	
`							

 

POST-INSTALLED ANCHORS SHALL ONLY BE USED WHERE SPECIFIED ON THE CONSTRUCTION DOCUMENTS. THE CONTRACTOR SHALL OBTAIN APPROVAL FROM THE ENGINEER-OF-RECORD PRIOR TO INSTALLING POST-INSTALLED ANCHORS IN PLACE OF MISSING OR MISPLACED CAST-IN-PLACE ANCHORS. CARE SHALL BE TAKEN IN PLACING POST-INSTALLED ANCHORS TO AVOID CONFLICTS WITH EXISTING REBAR. HOLES SHALL BE DRILLED AND CLEANED IN ACCORDANCE WITH THE MANUFACTURER'S WRITTEN INSTRUCTIONS. SUBSTITUTION REQUESTS FOR PRODUCTS OTHER THAN THOSE SPECIFIED BELOW SHALL BE SUBMITTED BY THE CONTRACTOR TO THE ENGINEER-OF-RECORD ALONG WITH CALCULATIONS THAT ARE PREPARED & SEALED BY A REGISTERED PROFESSIONAL ENGINEER. THE CALCULATIONS SHALL DEMONSTRATE THAT THE SUBSTITUTED PRODUCT IS CAPABLE OF ACHIEVING THE PERTINENT EQUIVALENT PERFORMANCE VALUES

(MINIMUM) OF THE SPECIFIED PRODUCT USING THE APPROPRIATE DESIGN PROCEDURE AND/OR STANDARD(S) AS REQ'D BY THE BUILDING CODE. PROVIDE CONTINUOUS SPECIAL INSPECTION FOR ALL MECHANICAL AND ADHESIVE ANCHORS PER THE APPLICABLE EVALUATION REPORT. CONTACT MANUFACTURER'S REPRESENTATIVE FOR THE INITIAL TRAINING AND INSTALLATION OF ANCHORS AND FOR PRODUCT RELATED QUESTIONS AND AVAILABILITY.

1.1. CONCRETE ANCHORS

POST INSTALLED ANCHORS

- A. MECHANICAL ANCHORS SHALL HAVE BEEN TESTED AND QUALIFIED FOR USE IN ACCORDANCE WITH ACI 355.2 AND ICC-ES AC193 FOR CRACKED AND UNCRACKED CONCRETE RECO PRE-APPROVED MECHANICAL ANCHORS INCLUDE: - SIMPSON STRONG-TIE "TITEN-HD" (ICC-ES ESR-2713)
- SIMPSON STRONG-TIE "STRONG-BOLT 2" (ICC-ES ESR-3037)
- B. ADHESIVE ANCHORS SHALL HAVE BEEN TESTED AND QUALIFIED FOR USE IN A CCORDANCE WITH ACI 355.4 AND ICC-ES AC308 FOR CRACKED AND UNCRACKED CONCRETE NECO ENITION. PRE-APPROVED ADHESIVE ANCHORS INCLUDE: - SIMPSON STRONG-TIE "SET-XP" (ICC-ES ESR-2508)
- SIMPSON STRONG-TIE "AT-XP" (IAPMO-ES ER-0263) - HILTI HIT HY150 INJECTION ADHESIVE
- EPCON CERAMIC 6 EPOXY ADHESIVE SUPPLIED BY ITW PAMSET RED HEAD - POWER-FAST EPOXY INJECTION GEL SUPPLIED BY POWERS ASTENING
- C. POWDER AND GAS-ACTUATED FASTENERS SHALL HAVE BEEN TESTED AND QUALIFIED FOR USE IN ACCORDANCE WITH ICC-ES AC70. PRE-APPROVED 20WDER ACTUATED FASTENERS INCLUDE:
 SIMPSON STRONG-TIE "POWER-DRIVEN FASTENERS" (ICC-ES ESR-2138) - SIMPSON STRONG-TIE "GAS-ACTUATED F/STEXER" (ICC-ES ESR-2811)

2. MASONRY ANCHORS

- 2.1 ANCHORAGE TO SOLID-GROUTED CONCRETE MISONRY:
- A. MECHANICAL ANCHORS SHALL HAVE BEEN TESTED AND QUALIFIED FOR USE IN ACCORDANCE WITH ICC-ES AC01 OR AC106. PRE-A PROVED MECHANICAL ANCHORS INCLUDE:
 - SIMPSON STRONG-TIE "TITEN-NO" (ICC-ES ESR-1056) - SIMPSON STRONG-TIE "STRONG-BOLT 2" (IAMPO-ES ER-0240)
- SIMPSON STRONG-TIE "WELGE-ALL" (ICC-ES ESR-1396)

 B. ADHESIVE ANCHORS S VALUHAVE BEEN TESTED AND QUALIFIED FOR USE IN ACCORDANCE WITH ICC-ES AC58. PRI -APPROVED MECHANICAL ANCHORS INCLUDE:
 SIMPSON STRONG-TIF "AT-XP" (IAMPO-ES ER-0281)
 - SIMPSON STRONG-TE "SET-XP" (IAMPO-ES ER-0265)
 - HILTI HIT H (13) INJECTION ADHESIVE EPCON CEN AMIC 6 EPOXY ADHESIVE SUPPLIED BY ITW RAMSET/RED HEAD
- POWER-POST EPOXY INJECTION GEL SUPPLIED BY POWERS FASTENING ANCHORACE TO HOLLOW CONCRETE MASONRY:
- 3.1 ADINGIVE ANCHORS WITH SCREEN TUBES SHALL BE TESTED AND QUALIFIED IN ACCORDANCE WITH ICC-ESAC58 OR AC60, AS APPROPRIATE. THE APPROPRIATE SCREEN TUBE SHALL BE USED AS COMMENDED BY THE ADHESIVE MANUFACTURER. PRE-APPROVED ADHESIVE ANCHORS WITH
 - UBES INCLUDE: - SIMPSON STRONG-TIE "SET" (ICC-ES ESR-1772)
 - SIMPSON STRONG-TIE "AT" (ICC-ES ESR-1958) - HILTI HIT HY150 INJECTION ADHESIVE - EPCON CERAMIC 6 EPOXY ADHESIVE SUPPLIED BY ITW RAMSET/RED HEAD

- POWER-FAST EPOXY INJECTION GEL SUPPLIED BY POWERS FASTENING

ALL DRILLED & EPOXIED 5/8" THREADED RODS SHALL MAINTAIN A MINIMUM EDGE DISTANCE OF 1 3/4" AND CLEAR SPACING OF 4" O.C. (MAX.)

CAST-IN-PLACE CONCRETE

- 1. ALL CONCRETE HAS BEEN DESIGNED IN ACCORDANCE WITH ACI 318 AND SHALL BE CONSTRUCTED IN
- 2. UNLESS NOTED OTHERWISE, ALL CONCRETE SHALL HAVE A 28 DAY COMPRESSIVE STRENGTH OF 3000 PSI.
- 3. REFER TO ARCHITECTURAL DRAWINGS FOR MOLDS, GROVES, ORNAMENTS, CLIPS OR GROUNDS REQUIRED TO BE ENCASED IN CONCRETE AND FOR LOCATION OF FLOOR FINISHES AND SLAB DEPRESSIONS.
- 4. CONSTRUCTION JOINT LOCATIONS SHALL BE APPROVED BY THE STRUCTURAL ENGINEER. NO HORIZONTAL CONSTRUCTION JOINTS ARE PERMITTED EXCEPT THOSE SHOWN ON THE STRUCTURAL DRAWINGS.
- DEFECTIVE AREAS IN CONCRETE INCLUDING, BUT NOT LIMITED TO, HONEY-COMBING, SPALLS, AND CRACKS WITH WIDTHS EXCEEDING O.O1 INCH SHALL BE REPAIRED. EXTENT OF DEFECTIVE AREA TO BE DETERMINED BY THE STRUCTURAL ENGINEER.

- 1. ALL HEADERS, BEAMS, POSTS, ETC. HAVE BEEN DESIGNED TO SUPPORT ROOF FRAMING MEMBERS AS SHOWN ON ROOF FRAMING PLAN. IT IS THE RESPONSIBILITY OF THE TRUSS MFG. TO NOTIFY E.O.R. OF ANY DISCREPANCY & PROVIDE FINAL TRUSS LAYOUT TO E.O.R. FOR STRUCTURAL PLAN REVISION IF LAYOUT VARIES FROM THAT SHOWN ON THIS PLAN SET.
- 1.1. ALL DECK JOISTS HEREIN SHOWN AS 16" O.C. OR GREATER ARE INTENDED FOR 2 X 6 OR 5/4 X 6 WOOD DECKING. IT IS THE CONTRACTORS RESPONSIBILITY, IF USING COMPOSITE DECKING TO INSTALL DECK JOISTS @ 12" O.C. OR AS REQUIRED BY MANUFACTURERS
- STRUCTURAL GLUED LAMINATED TIMBER SHALL BE PRODUCED IN ACCORDANCE WITH THE AMERICAN INSTITUTE OF TIMBER CONSTRUCTION (AITC). MINIMUM ALLOWABLE BENDING STRESS SHALL BE 2,400 PSI (DRY CONDITIONS).
- PROVIDE DRESSED SEASONED LUMBER, S4S, WITH A MAXIMUM MOISTURE CONTENT OF 19%
- 3.1. INTERIOR AND EXTERIOR LOAD-BEARING WALLS:

SOUTHERN PINE (S.P.), NO. 2 GRADE.

SPRUCE PINE FUR (SPF) U.N.O.

3.2. LINTELS, FLOOR JOISTS AND BEAMS:

AT TIME OF DRESSING AS LISTED BELOW.

- 3.3. WOOD IN CONTACT WITH CONCRETE OR MASONRY SHALL BE FOUNDATION GRADE PRESSURE-TREATED. USE GALVANIZED NAILS IN PRESSURE-TREATED WOOD. THE PROTECTIVE COATING ON LIGHT GAUGE STEEL CONNECTIONS IN CONTACT W/ PRESSURE-TREATED WOOD SHALL BE IN ACCORDANCE WITH THE CONNECTOR MANUFACTURERS RECOMMENDATIONS.
- 4. ENGINEERED LUMBER PRODUCTS

HORIZONTAL SHEAR

4.1. PARALLEL STRAND LUMBER (PSL) SHALL HAVE THE FOLLOWING MINIMUM ALLOWABLE STRESSES AND PROPERTIES:

ALLOWABLE BENDING STRESS	F_B	= 2900 PSI
COMPRESSION PERPENDICULAR TO GRAIN	F_{C^\perp}	= 750 PSI
COMPRESSION PARALLEL TO GRAIN	F _c	= 2900 PSI
HORIZONTAL SHEAR	F_V	= 290 PSI
MODULUS OF ELASTICITY	Ε	= 2,000,000 PSI

- 4.2. LAMINATED VENEER LUMBER (LVL) SHALL HAVE THE FOLLOWING M STRESSES AND PROPERTIES: ALLOWABLE BENDING STRESS $F_{\rm p} = 2600 \, \rm P$ COMPRESSION PERPENDICULAR TO GRAIN FC. COMPRESSION PARALLEL TO GRAIN
- MODULUS OF ELASTICITY 4.3. LAMINATED STRAND LUMBER (LSL) SHALL HAVE THE TOLLOWING MINIMUM ALLOWABLE STRESSES AND PROPERTIES: ALLOWABLE BENDING STRESS COMPRESSION PERPENDICULAR TO GRAIN = 710 PSI
- COMPRESSION PARALLEL TO GRAIN = 1835 PSI HORIZONTAL SHEAR F_v = 425 PSI MODULUS OF ELASTICITY E = 1,300,000 PSIGLULAM BEAMS (GLU) SHALL HAVE THE FOLLOWING MINIMUM ALLOWABLE STRESSES
- AND PROPERTIES: ALLOWABLE BENDING STP COMPRESSION PERRENDICULAR TO GRAIN $F_{C^{\perp}} = 805 \, PSI$ TENSION PARALLEL TO = 1350 PSI $F_V = 300 PSI$ HORIZONTAL SHEA
- MODULUS OF ELASTICITY E = 2,100,000 PSI4.5. PRESERVED G ULAM BEAMS (GLU) SHALL HAVE THE FOLLOWING MINIMUM ALLOWABLE STRESSES AND PROPERTIES:
- ALLOWALLE BENDING STRESS $F_B = 2400 \text{ PSI}$ CON PRESSION PERPENDICULAR TO GRAIN $F_{C^{\perp}} = 740 \text{ PSI}$ $F_B = 2400 PSI$ RIZONTAL SHEAR $F_{V} = 300 \, PSI$ MOLULUS OF ELASTICITY E = 1,800,000 PS
- STRUCTURAL PANELS FLOOR PANELS SHALL BE CONSTRUCTED WITH TONGUE AND GROOVE APA RATED 3/4" ✓ PLYWOOD. FLOOR PANELS SHALL BE GLUED AND NAILED w/ 8d RING SHANK NAILS @4"
- O.C. AT PANEL EDGES AND AT 6" O.C. IN THE FIELD. WALL PANELS SHALL BE CONSTRUCTED WITH APA RATED SHEATHING, SHEATHING SHALL BE ATTACHED WITH 8d COMMON NAILS @3" O.C. AT PANEL EDGES AND 6" O.C. IN THE FIELD. ALL PANEL EDGES SHALL BE BLOCKED.
- 5.3. ROOF PANELS SHALL BE CONSTRUCTED WITH APA RATED SHEATHING. SHEATHING SHALL BE ATTACHED WITH 8d RING SHANK NAILS @ 3" O.C. AT PANEL EDGES AND AT 6" O.C. IN THE FIELD. ALL PANEL EDGES SHALL BE BLOCKED OR ATTACHED WITH SIMPSON PSCA PANEL SHEATHING CLIPS.
- 5.4. NAIL HEADS SHALL NOT PENETRATE THE OUTER SURFACE OF SHEATHING.
- 6. FABRICATED WOOD TRUSSES
- 6.1. DESIGN OF WOOD TRUSSES SHALL BE THE SOLE RESPONSIBILITY OF THE CONTRACTOR. SUBMIT SHOP DRAWINGS, DESIGN LOAD DATA, AND SUPPORT REACTIONS SEALED BY AN ENGINEER LICENSED IN THE PROJECT STATE. REVIEW OF SHOP DRAWINGS SHALL BE FOR CONFORMANCE WITH THE CONTRACT DOCUMENTS WITH REGARD TO TRUSS CONFIGURATION, AND THE CONTRACTOR'S INTERPRETATION OF DESIGN LOADS AND DETAILS. SUCH REVIEW SHALL NOT RELIEVE THE CONTRACTOR OF THE FULL RESPONSIBILITY FOR THE DESIGN OF THE TRUSSES OR TRUSS CONNECTIONS NOT SPECIFICALLY DETAILED IN THE CONTRACT DOCUMENTS.
- 6.2. ERECTION AND BRACING OF PREFABRICATED WOOD TRUSSES SHALL BE IN CONFORMANCE WITH THE RECOMMENDATIONS OF THE TRUSS MANUFACTURER AND THE TRUSS PLATE INSTITUTE'S "BRACING WOOD TRUSSES: COMMENTARY AND
- 6.3. SECURE EACH COMMON ROOF TRUSS/RAFTER TO TOP PLATE WITH SIMPSON H-10 OR H-7 HURRICANE CLIP AT ALL BEARING POINTS. USE SIMPSON H-7 AT GIRDER TRUSSES. PROVIDE A MINIMUM OF TWO STUDS UNDER GIRDER TRUSS END BEARING.
- 6.4. TRUSSES ON SITE PRIOR TO INSTALLATION SHALL BE STORED IN A VERTICAL POSITION WITH SUPPORT POINTS PROVIDED AT FINAL BEARING POINTS AND BRACED TO AVOID
- 6.5. INSTALLATION OF ALL TRUSSES SHALL BE DONE USING A SPREADER BAR WITH A THREE POINT VERTICAL PICK AND CARE IS TO BE USED IN LIFTING TO MINIMIZE HORIZONTAL
- 6.6. IMPROPER HANDLING OF THE TRUSSES AS NOTED ABOVE AND IN THE SPECIFICATIONS SHALL MEAN REMOVAL OF THE TRUSSES FROM THE JOB SITE.
- 6.7. TRUSS TO TRUSS CONNECTIONS SHALL BE VERIFIED BY THE TRUSS DESIGNER. 6.8. EXPOSED TRUSSES SHALL BE DELIVERED TO THE JOB SITE UNBLEMISHED AND SUITABLE FOR FIELD PAINTING.
- 6.9. CONTRACTOR TO REFER TO "STANDARD FOR HURRICANE RESISTANT CONSTRUCTION SSTD 10-99 FOR FRAMING REQUIREMENTS OF WOOD FRAMED WALL SYSTEMS, TABLE 305C AND FIGURE 306D.
- 6.10. ALL FLOOR TRUSS DESIGN LOADS SHALL BE PER TRUSS MANUFACTURER. THE LOADS REFERENCED WITHIN THE FOLLOWING "STRUCTURAL LOADS" SECTION REPRESENTS THE LOADS USED FOR THE DESIGN OF STRUCTURAL MEMBERS SUPPORTING FLOOR AND ROOF TRUSSES.
- CONNECTIONS
- 7.1. CONNECTIONS FOR STRUCTURAL TIMBER SHALL BE GALVANIZED STRONG TIE CONNECTORS BY THE SIMPSON COMPANY OR APPROVED EQUAL. CONNECTORS SHALL FOLLOW MANUF. CORROSION PROTECTION RECOMMENDATIONS.
- 7.2. THE NUMBER OF FASTENERS PER CONNECTION SHALL BE THE MAX. ALLOWED FOR THAT PARTICULAR FASTENER.

STRUCTURAL LOADS:

FLOOR PORCH 10 PSF 15 PSF SUPERIMPOSED LIVE LOADS (RESIDENTIAL CONSTRUCTION)

SUPERIMPOSED DEAD LOADS (RESIDENTIAL CONSTRUCTION):

ATTICS w/ STORAGE 20 PSF 10 PSF ATTICS w/o STORAGE HABITABLE ATTICS & BEDROOMS 40 PSF ALL OTHER ROOMS 40 PSF DECKS 60 PSF FLOOR 40 PSF ROOF 20 PSF


MALTOWABLE


124 MPH UCTURAL CATEGOR' PUSURE CATEGORY LERNAL PRESSURE COEFFICIENT 0.18 ± MPACT GLASS WINDOWS & DOORS

MAIN W	IND FRAME RESISTING SYSTEM (N	MWFRS)
AREA	INTERIOR ZONE	END ZONE
WALLS	39.24 PSF	49.05 PSF
ROOF	± 34.52 PSF	± 43.15 PSF

COMPONENTS AND CLADDING ROOF PRESSURES (PSF)									
ZONE			+ GCpi			- GCpi			
ROOF (ZONE 1)		28.35			-61.07				
ROOF (ZONE 2)		28.35		-97.42					
ROOF (ZONE 3)		28.35		-115.59					
COMPONENTS AND CLADDING WALL F						ESSURES (PSF)			
	0 SF - 10 SF		10 SF - 30 SF 30 SF -		- 60 SF	60 SF	- 100 SF		
ZONE	+ GCpi	- GCpi	+ GCpi	- GCpi	+ GCpi	- GCpi	+ GCpi	- GCpi	
4	42.89	-46.53	42.89	-46.53	39.83	-43.47	37.90	-41.53	
5	42.89	-57.43	42.89	-57.43	39.83	-51.31	37.90	-47.44	

NOTE: ALL PRESSURES SHOWN ARE BASED UPON ASD DESIGN, WITH A LOAD FACTOR OF 0.6.

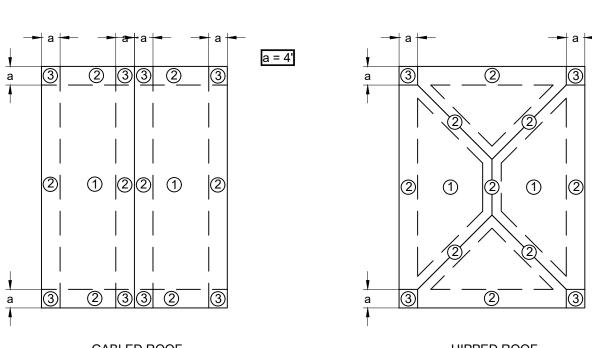

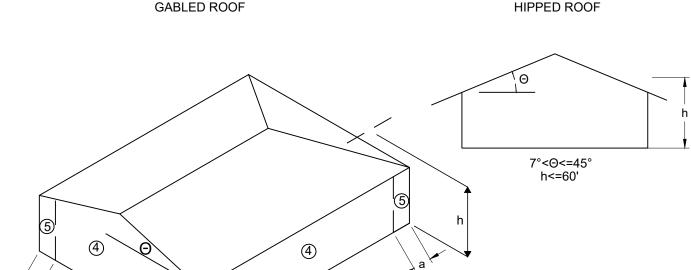

THE STRUCTURE SHOWN ON THESE PLANS IS DESIGNED IN ACCORDANCE WITH FLORIDA BUILDING CODE 8TH EDITION (2023).

BTM. = BOTTOM

TYP. = TYPICAL

REQ'D = REQUIRED

E.O.R. = ENGINEER OF RECORD

U.N.O. = UNLESS NOTED OTHERWISE

3" O.C. EDGE

6" O.C. FIFI D

N.T.S. = NOT TO SCALE

C.I.P. = CAST IN PLACE

S.S. = STAINLESS STEEL

ABBREVIATIONS

CONC. = CONCRETE WWM = WELDED WIRE MESH CONT. = CONTINUOUS CMU = CONCRETE MASONRY UNIT P.T. = PRESSURE TREATED N.T.S. = NOT TO SCALE BTW = BETWEEN

WALLS

SIM = SIMILAR LOC = LOCATION HCA = HEADED CONCRETE ANCHOR CONT. = CONTINUOUS

L.B.W. = LOAD BEARING WALL MFG. = MANUFACTURER F.F.E. = FINISHED FLOOR ELEVATION SHEARWALL/SHEATHING NAIL SCHEDULE (U.N.O.)

		0 0.0.1 ILLD			
ROOF	8d "RING SHANK"	3" O.C. EDGE 6" O.C. FIELD			
TONGUE	E & GROOVE SHEATHING, IF APPLICABLE (U.N.O.)				
WALLS	(2) 3" #9 DECK SREWS	EACH STUD CONN.			
ROOF	(2) 3" #9 DECK SREWS	EACH TRUSS/RAFTER CONN			

551 Piney Forest Road Danville, VA 24540 434.797.4497 Phone 434.797.4341 Fax www.dewberry.com

SOUTHEASTERN CONSULTING ENGINEERS, INC Southeastern Consulting Engineers, Inc. 120 North Highway 71 Wewahitchka, FL 32465 850.639.3860

 \overline{C} മ



SEAL

SCALE

REVISIONS DRAWN BY

APPROVED B

CHECKED BY

STRUCTURAL **GENERAL NOTES**

50171913 PROJECT NO.

PER SECTION 471.003(2)(H), F.S., ALL MECHANICAL, ELECTRICAL, AND PLUMBING ARE EXEMPT FROM PROFESSIONAL ENGINEERING SERVICES FOR THIS PROJECT. IT IS THE RESPONSIBILITY OF THE CONTRACTOR TO PERMIT AND CONSTRUCT THE APPLICABLE SYSTEM IN ACCORDANCE WITH FLORIDA BUILDING CODE, LOCAL CODE REQUIREMENTS AND PROGRAMMATIC REQUIREMENTS. IT IS THE RESPONSIBILITY OF THE CONTRACTOR TO PERMIT THE PROJECT WITH ALL AUTHORITIES HAVING JURISDICTION (AHJ). INFORMATION SHOWN PROVIDES MINIMUM PROGRAMMATIC REQUIREMENTS AND ARE GENERAL IN NATURE. DRAWINGS ARE SCHEMATIC IN NATURE AND FINAL PERMITTING AND CONSTRUCTION OF THE SYSTEM IS THE RESPONSIBILITY OF THE CONTRACTOR. ALL EQUIPMENT AND PRODUCTS SHALL BE SELECTED BY THE CONTRACTOR.

GENERAL NOTES

PLUMBING NOTES:

- PLUMBING CONSTRUCTION DOCUMENTS SHALL BE SUBMITTED BY THE PLUMBING SUBCONTRACTOR FOR PERMITTING TO THE AUTHORITY HAVING JURISDICTION.
- PLUMBING CONTRACTOR SHALL BE LICENSED AND RESPONSIBLE TO MEET ALL APPLICABLE REQUIREMENTS OF THE FLORIDA BUILDING CODE AND THE LOCAL CODE REQUIREMENTS OF THE
- JURISDICTION WHERE THE PROJECT WILL BE LOCATED. ALL PLUMBING FIXTURES AND PIPING MATERIALS AND INSTALLATION SHALL CONFORM TO THE LOCAL
- INSULATE ALL PIPING AS REQUIRE BY THE FLORIDA BUILDING CODE.

 USE WATER-CONSERVING FIX UKES MEETING THE FOLLOWING WATERSENSE REQUIREMENTS:
- USE WATER-CONSERVING FIX URES MEETING THE FOLLOWING WATERSENSE REQUIREMENTS:

 a. TOILETS = 1.28 GPF

 b. SHOWER HEADS = 2.0 CPM

 c. KITCHEN FAUCE S = 2.0 GPM

 d. BATHROOM FANCETS = 1.5 GPM

 e. WATER CLUSETS MUST HAVE A MINIMUM MAP RATING OF 600 GRAMS PER FLUSH. COORDINATE FIXTURES AND LOCATIONS WITH ARCHITECTURAL PLANS AND OWNER.

 PROVIDE SERVICE CONNECTIONS TO THE LOCAL UTILITY THAT COMPLY WITH THE SERVICE AUTHORITY S REQUIREMENTS

 COORDINATE HOT WATER HEATER LOCATION AND PROVIDE PLASTIC DRAIN/DRIP PAN WITH DRAIN TO THE BUILDING EXTERIOR IN A CONSPICUOUS LOCATION. WATER HEATER SHALL BE MINIMUM 50 GALLOW OF PACITY AND ENERGY STAR LISTED.

 CORDINATE HOSE BIBB LOCATIONS (MINIMUM OF 2 EXTERIOR HOSE BIBBS SHALL BE PROVIDED).


 PROVIDE 'NO-DRIP' SUPPLY/DRAIN AT WASHING MACHINE.

 PROVIDE ACCESS PANELS TO TUB/SHOWER PLUMBING LINES/VALVE.

 PIRFORM ALL REQUIRED TESTS PRIOR TO INSTALLING PIPE INSULATION, BACKFILLING, OR INSTALLING DRYWALL.

- PROVIDE ALL CLEAN-OUTS, EXPANSION TANKS, VACUUM BREAKERS, AND OTHER MISCELLANEOUS COMPONENTS REQUIRED FOR A COMPLETE AND FUNCTIONAL SYSTEM WHETHER SHOWN ON
- DRAWINGS OR NOT. PROVIDE SHUT-OFF VALVES TO ALL FIXTURES. ALL PENETRATIONS THROUGH THE ROOF SHALL BE FLASHED AND SEALED USING PREFORMED RUBBER
- PLUMBING SUBCONTRACTOR SHALL PROVIDE AND INSTALL DRAIN PIPING FOR ALL HVAC EQUIPMENT.
- DISCHARGE TO GRADE. DO NOT CONNECT TO SANITARY PIPING. ALL DRAIN LINES SHALL HAVE WATER SEAL TRAPS AS REQUIRED BY CODE. ALL PLUMBING FIXTURES AND GROUPS SHALL BE VENTED IN ACCORDANCE WITH THE CURRENT VERSION OF THE FLORIDA
- BUILDING CODE. ALL SANITARY SEWER PIPING SHALL BE SOLID-CORE. SCHEDULE 40 PVC DWV PIPE WITH APPROPRIATE FITTINGS. MINIMUM SLOPE OF THE SANITARY SEWER PIPING SHALL BE MAINTAINED PER CODE. AVOID ROUTING PIPE THROUGH BUILDING FOOTINGS. WHERE CONFLICTS ARE UNAVOIDABLE, ROUTE PIPING A
- MINIMUM OF 12" BELOW FOOTING. HOT- AND COLD-WATER SUPPLY PIPING SHALL BE CPVC WITH APPROVED FITTINGS. PLUMBING CONSTRUCTION DRAWINGS SHALL INDICATE THE LOCATION OF CLEAN-OUTS AND
- CONNECTIONS TO EXISTING UTILITIES INCLUDING WATER AND SANITARY SEWER FOR REVIEW BY THE **AUTHORITY HAVING JURISDICTION.**
- HOT & COLD WATER PIPING AND SANITARY DRAIN TRAPS SHALL NOT BE INSTALLED IN ANY LOCATION SUBJECT TO FREEZING.

KITCHEN SINK TO HAVE ENERGY STAR GARBAGE DISPOSAL. PLUMBER SHALL COORDINATE WITH ELECTRICIAN FOR INSTALLATION.

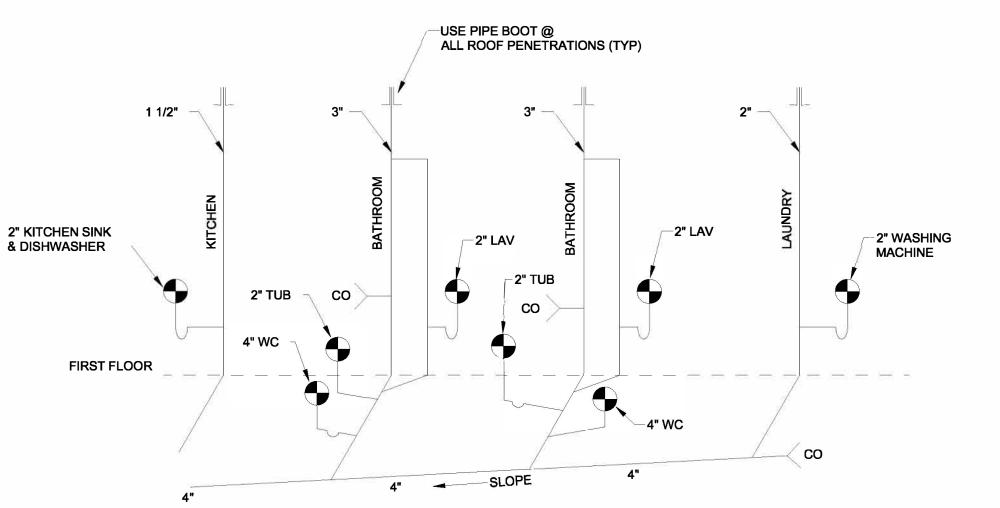

RISER DIAGRAM

NOT TO SCALE

Dewberry

Dewberry Engineers Inc. 877 North County Hwy 393 Santa Rosa Beach, FL 32459 850.267.0759 Phone 850.557.0076 Fax

www.dewberry.com


Master Engineers & Designers 904 Lakeside Drive Lynchburg, VA 24501 434.846.1350



SEAL

SCALE

As indicated

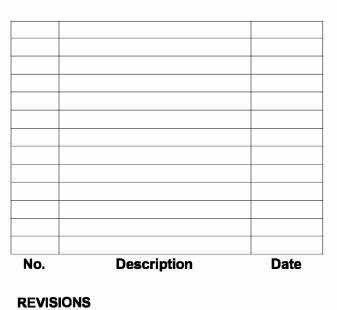

ETO

50171913

DRAWN BY APPROVED B

CHECKED BY DATE

GENERAL INFORMATION 2BR WIDE

PROJECT NO.

HVAC CONSTRUCTION DOCUMENTS SHALL BE SUBMITTED BY THE HVAC SUBCONTRACTOR FOR PERMITTING TO THE

HVAC CONTRACTOR SHALL BE LICENSED AND RESPONSIBLE TO MEET ALL APPLICABLE REQUIREMENTS OF THE

FLORIDA BUILDING CODE AND THE LOCAL CODE REQUIREMENTS OF THE JURISDICTION WHERE THE PROJECT WILL BE THE HVAC DRAWINGS ARE SCHEMATIC IN NATURE. THE HVAC CONTRACTOR SHALL PROVIDE ALL EQUIPMENT AND

COMPONENTS REQUIRED FOR A COMPLETE AND FUNCTIONAL SYSTEM WHETHER SHOWN ON THE DRAWINGS OR NOT. THESE COMPONENTS MAY INCLUDE, BUT SHALL NOT BE LIMITED TO:

CONDENSATE DRAIN PANS, OVERFLOW SWITCHES, AND PIPING

CONSTITUTION DRAWINGS SHALL BE BASED ON THE LOCATION AND ORIENTATION OF THE PROPOSED SITE. HVAC SYSTEM SHALL BE SIZED BASED ON ACCA MANUAL J AND S, LATEST EDITION. CONTRACTOR SHALL PROVIDE

ALL DUCTS AND PLENUMS SHALL BE MADE AIR TIGHT. SEAL ALL DUCT SEAMS USING TAPE AND MASTIC OVER JOINTS. CONSTRUCT AND INSTALL DUCTWORK IN COMPLIANCE WITH THE FLORIDA BUILDING CODE, LATEST EDITION. MAXIMUM DUCT LEAKAGE SHALL NOT EXCEED 5% OF RATED AIFLOW, OR AS REQUIRED BY LOCAL CODES. PROTECT OPEN DUCTS DURING CONSTRUCTION TO MINIMIZE DUST AND DEBRIS USING BLUE MAX OR EQUAL DUCT

REQUIREMENTS FOR THE PRESSURE CLASS REQUIRED. MAXIMUM LENGTH OF FLEX DUCT SHALL BE 5'. THE HVAC CONTRACTOR SHALL DESIGN THE DUCT SYSTEM BASED ON ACCA MANUAL D, LATEST EDITION. INSULATE DUCTWORK AS REQUIRED BY FLORIDA BUILDING CODE, BUT NOT LESS THAN R-6. FLEXIBLE DUCTS SHALL BE EXTENDED FULLY. EXCESS DUCT MATERIAL SHALL BE LIMITED TO LESS THAN 5%.

INSTALL FLEXIBLE DUCT PER MANUFACTURER'S RECOMMENDATIONS INCLUDING JOINING, SEALING, LIMITATIONS OF

INSTALL BALANCING DAMPERS AT EACH DUCT TAKE-OFF.

INSTALL FIRE AND SMOKE DAMPERS WHERE REQUIRED BY LOCAL CODES AND ASSEMBLY PENETRATIONS.

INSTALL SMOKE DETECTORS WHERE REQUIRED BY LOCAL CODES.

PLUMBING SUBCONTRACTOR SHALL PROVIDE A MEANS OF CONDENSATE DISPOSAL FOR EACH PIECE OF HVAC

CONDENSATE DISPOSAL SYSTEM SHALL BE DESIGNED AND INSTALLED IN ACCORDANCE WITH THE FLORIDA BUILDING

PRIMARY AND SECONDARY CONDENSATE PIPING SHALL BE SCHEDULE 40 PVC. PRIMARY CONDENSATE PIPING LOCATED WITHIN THE BUILDING ENVELOPE SHALL BE INSULATED USING 3/4" CLOSED

ALL CONDENSATE DISPOSAL PIPING SHALL BE TESTED DURING HVAC EQUIPMENT STARTUP.

HEAT PUMP AND AIR-HANDLING UNIT SHALL BE INSTALLED IN ACCORDANCE WITH THE FLORIDA BUILDING CODE AND

HEAT PUMP, AT A MINIMUM, SHALL BE LOCATED 2' ABOVE THE 100-YEAR FLOOD LEVEL AND SHALL BE SUPPORTED

AND TIED DOWN AS REQUIRED BY THE FLORIDA BUILDING CODE USING APPROVED HURRICANE STRAPS. THE MANUFACTURER'S RECOMMENDED CLEARANCES SHALL BE MAINTAINED ON ALL SIDES OF HEAT PUMP AND AIR-

HEAT PUMP AND AIR-HANDLING UNITS SHALL BE INSTALLED PER THE MANUFACTURER'S RECOMMENDATIONS AND IN COMPLIANCE WITH ALL EPA AND LOCAL REQUIREMENTS. EQUIPMENT ACCESS SHALL NOT BE REDUCED BY REFRIGERANT PIPING, CONDENSATE DRAINS, OR OTHER

EXHAUST DUCTS FOR BATHROOMS, POWDER ROOMS, AND KITCHEN HOODS SHALL TERMINATE AT THE BUILDING EXTERIOR USING APPROVED ROOF CAPS, SIDEWALL CAPS, OR SOFFIT VENTS.

TOILET EXHAUST FANS SHALL BE FURNISHED WITH BACKDRAFT DAMPERS. TOILET EXHAUST FANS SHALL BE CONTROLLED BY MANUALLY OPERATED TIMERS.

DRYER EXHAUST DUCT SHALL BE ROUTED TO THE BUILDING EXTERIOR PER THE FLORIDA BUILDING CODE AND MANUFACTURER RECOMMENDATIONS. INSTALL BOOSTER FAN AS REQUIRED AND AS ALLOWED BY CODE.

VENTILATION AIR DUCT SHALL INCLUDE A MANUAL VOLUME DAMPER AND A NORMALLY CLOSED ISOLATION DAMPER

THE VENTILATION ISOLATION DAMPER SHALL BE WIRED TO OPEN WHENEVER THE ASSOCIATED AHU IS TURNED ON.

VENTILATION AIR INTAKE SHALL BE LOCATED IN ACCORDANCE WITH THE FLORIDA BUILDING CODE, AND SHALL BE A MINIMUM OF 10 FEET FROM EXHAUST TERMINATIONS, A MINIMUM OF 10 FEET FROM PLUMBING VENTS, A MINIMUM OF 3 FEET FROM OPERABLE WINDOWS AND DOORS, AND A MINIMUM OF 3 FEET FROM PROPERTY LINES.

			AIR HA	NDLING	TINU 6	SCHEE	ULE		
	MARK	AREA SERVED	MODEL SIZE	EXT SP in Wg	FAN TYPE	V/PH/HZ	AUX HE		REMARKS
-							STAGES	V/PH/HZ	
	AHU-1	ENTIRE HOUSE	SEE REMARKS	-	FC	230/1/60	1	230/1/60	1,2,3

- 2. PROVIDE SEVEN DAY PROGRAMMABLE THERMOSTAT, MERV 8 FILTER, AND ELECTRIC RESISTANCE HEAT.

EXHAUST FAN SCHEDULE						
MARK	TYPE	CFM	SP in Wg	DRIVE	VOLTS/PH/HZ	REMARKS
EF-1	CEILING	50	0.25	DIRECT	115/1/60	1,2,3,4

- 2. PROVIDE BACKDRAFT DAMPER, INLET GRILLE, SPEED CONTROLLER, AND DISCHARGE WALL CAP OR ROOF JACK.
- 4. PROVDE EXHAUST FAN WITH MANUALLY OPERATED TIMER.

	HEAT F	PUMP SC	HEDUL	E
MARK	NOMINAL TONS	SYSTEM SERVED	V/PH/HZ	REMARKS
HP-1	SEE REMARKS	AHU-1	208/230/1/60	1,2,3

- MODEL TO BE SELECTED BY CONTRACTOR.
- 2. UNIT SHALL BE MINIMUM 16 SEER.
- 3. REQUIRED NOMINAL TONS FOR HEAT PUMP MUST MATCH THAT FOR AIR HANDLER UNIT.





SCALE

As indicated

NO.	Description	Date
REVISIONS		
DRAWN B	Υ	ЕТО
APPROVE	D BY	CLS
CHECKED	BY	CLS
DATE		


GENERAL INFORMATION 2BR WIDE

PROJECT NO. 50171913

M0.1

SHEET NO.

TITLE

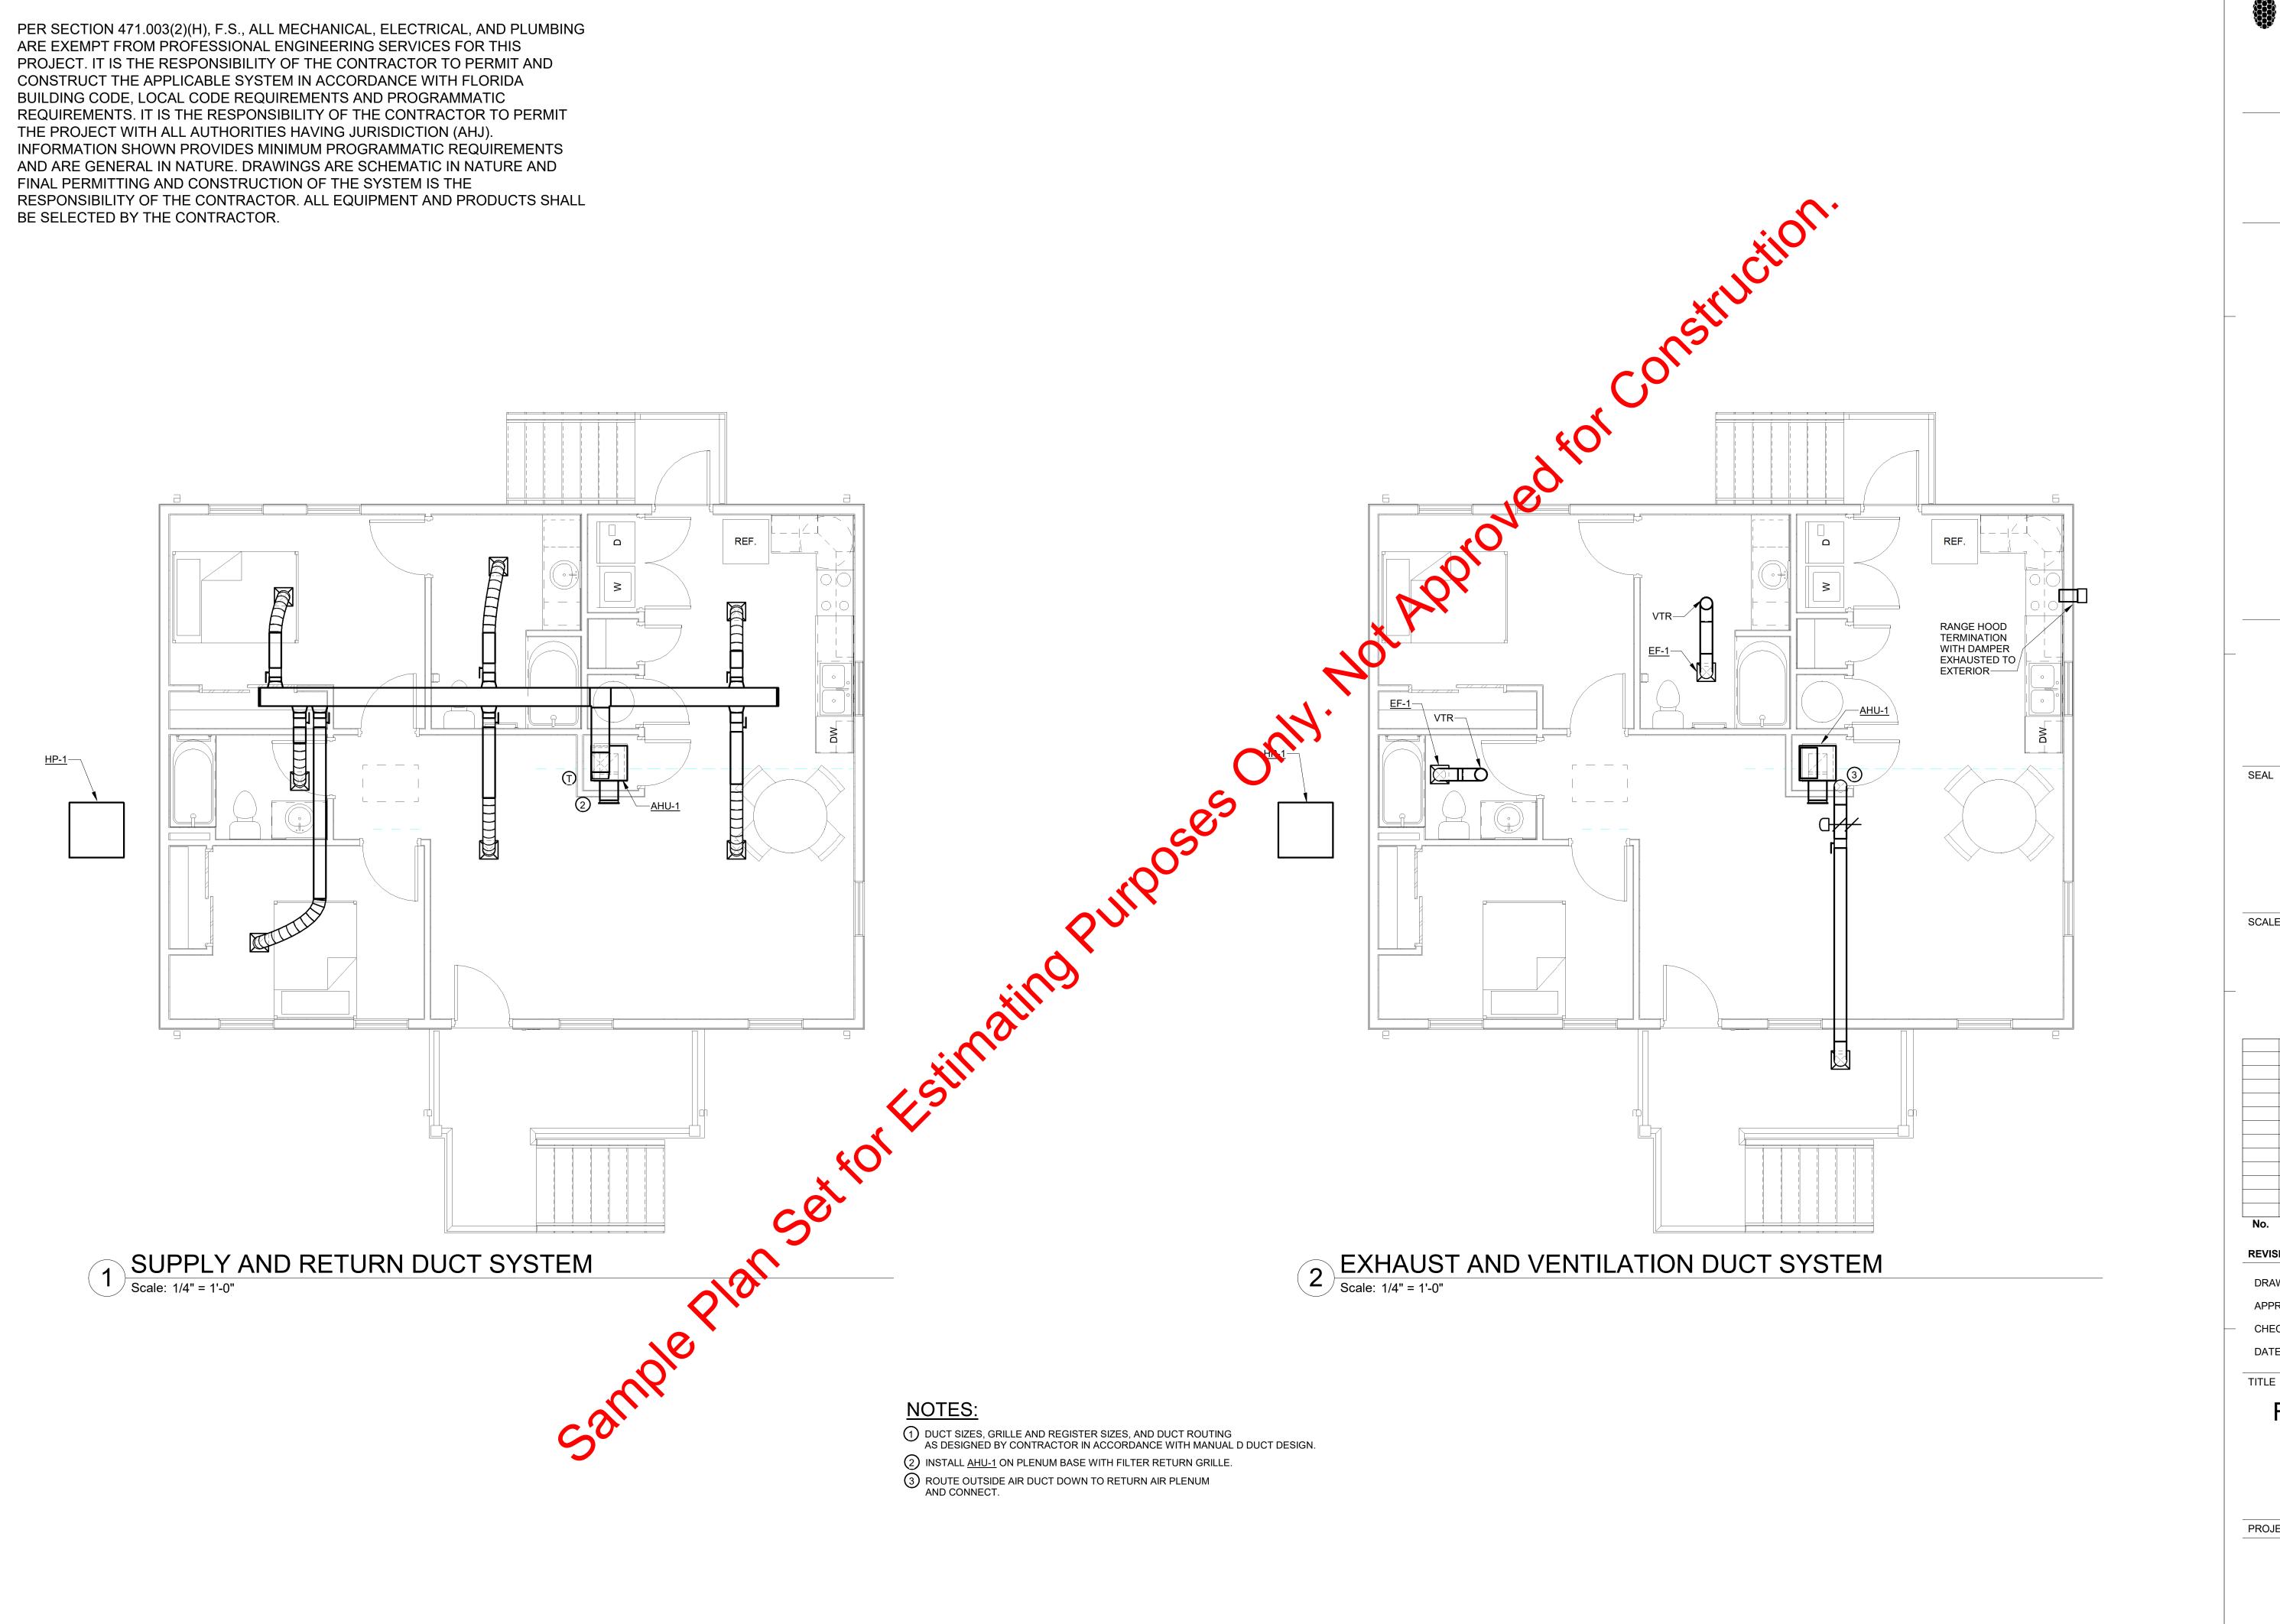

Dewberry Engineers Inc. 877 North County Hwy 393 Santa Rosa Beach, FL 32459 850.267.0759 Phone 850.557.0076 Fax www.dewberry.com

SCALE

1/4" = 1'-0"

Description

REVISIONS DRAWN BY ETO

APPROVED BY CHECKED BY DATE

> FLOOR PLANS 2BR WIDE

50171913 PROJECT NO.

M1.0

SURFACE-MOUNTED KITCHEN FIXTURE, ENERGY STAR QUALIFIED

WET-LISTED, NON-CONDUCTIVE, SHOWER DOWNLIGHT, ENERGY

KICHLER COSTAL, EXTER WALL-MOUNT, WET-LISTED OR EQUAL,

PENDANT, ENERGY STAR QUALIFIED

STAR QUALIFIED

ENERGY STAR QUALIFIED

BATHROOM VANITY, 2', ENERGY STAR QUALIFIED

2' CLOSET LIGHT, ENERGY STAR QUALIFIED

INTEGRATED LED

LED

INTEGRATED LED

INTEGRATED LED

LED

3000K

3000K

3000K

ELECTRICAL LEGEND

NUIT DUNI CONCEALED ADOVE CELLINGS OD IN WALLS	
DUIT RUN CONCEALED ABOVE CEILINGS OR IN WALLS	

 \bigcirc JUNCTION BOX

SAFETY SWITCH, (NEMA 1 INDOORS, NEMA 3R OUTDOORS)

RECEPTACLE, DUPLEX, NEMA 5-20R RECEPTACLE, DUPLEX, NEMA 5-20R, GFI, WP INDICATES WEATHERPROOF, CH INDICATES COUNTER HEIGHT, GD INDICATES UNDER THE SINK FOR

GARBAGE DISPOSAL RECEPTACLE, SPECIAL

SWITCH

SWITCH, 3/W SWITCH, 4/W SWITCH, FAN

SWITCH WITH PILOT LIGHT

LIGHT FIXTURE, WALL MOUNTED

LIGHT FIXTURE, SURFACE MOUNTED OR DOWNLIGHT

CEILING FAN WITH INTEGRAL LIGHT FIXTURE

EXHAUST FAN WITH INTEGRAL LIGHT FIXTURE

SMOKE & CARBON MONOXIDE DETECTOR, CEILING

POWER COMPANY METER — **ELECTRICAL PANEL**

GENERATOR PRE-WIRE DIAGRAM (NOTE 24)

NOTES (SHEET NO. E1.0)

- COMBINATION LIGHT / EXHAUST FAN FIXTURE TO BE ENERGY STAR COMPLIANT. COORDINATE WITH MECHANICAL CONTRACTOR.
- 2. INSTALL (1) 220 DISCONNECT. MAINTAIN A 3 FT CLEARANCE IN FRONT OF DISCONNECT

ELECTRICAL GENERAL NOTES

- ELECTRICAL CONTRACTOR SHALL SIZE SARVICE, CONDUCTORS, FUSES, BREAKERS, AND SWITCHES IN ACCORDANCE WITH LOCAL BUILDING CODE. AN ELECTRICAL LOAD CALCULATION WILL BE REQUIRED FOR SERVICE SIZING.
- PROVIDE SERVICE ENTRANCE GROUNDING IN ACCORDANCE WITH LOCAL BUILDING CODE.
- ELECTRICAL CONTRACTOR SHALL COORDINATE WITH POWER COMPANY TO FULFILL REQUIREMENTS IN CONTRACTOR RESPONSIBLE FOR ALL ASSOCIATED FEES. ESTABLISHING SERVICE.
- ALL WIRING SHAY BE COPPER WITH ONE EXCEPTION ONLY. THE SERVICE ENTERANCE CONDUCTORS MAY USE COPPER OF A LIMINUM (SE OR USE). OTHERWISE, NO ALUMINUM WIRING SHALL BE USED.
- SMOKE DETACTORS SHOWN SHALL BE COMBINATION SMOKE/CARBON MONOXIDE ALARMS. AND BE APPROVED AND LIST D IN ACCORDANCE WITH UL 217 AND 2034. THEY SHALL BE HARD WIRED WITH BATTERY BACK-UP. CORS WITHIN A UNIT SHALL BE INTERCONNECTED SUCH THAT ALL ALARM UPON ACTIVATION OF A
- LLUGHT FIXTURES AND CEILING FANS SHALL BE ENERGY STAR QUALIFIED.

PROVIDE ARC FAULT CIRCUIT INTERRUPTER (AFCI) PROTECTION WHERE REQUIRED BY CODE. PREFERRED COMPLIANCE PATH IS PROTECTION AT THE BRANCH CIRCUIT BREAKER LEVEL

COORDINATION WITH OTHER TRADES: EXECUTE THE WORK IN FULL COOPERATION WITH OTHER CONSTRUCTION TRADES. PRIOR TO STARTING WORK, EXAMINE A COMPLETE SET OF CONSTRUCTION DOCUMENTS FOR ALL TRADES TO VERIFY COORDINATION, CHECK FOR INTERFERENCES, AND DETERMINE POINTS OF CONNECTIONS FOR EQUIPMENT. DUE TO STRUCTURAL CONDITIONS, MECHANICAL DUCT OR PIPING INTERFERENCE, OR OTHER REASONS, THE CONTRACTOR MAY DESIRE TO INSTALL THE WORK IN AN ALTERNATE MANNER FROM THAT SHOWN. SUCH CHANGES SHALL BE PRESENTED TO THE OWNER'S REPRESENTATIVE FOR APPROVAL BEFORE PROCEEDING.

- PROVIDE DATA (CAT-6) AND TELEVISION (RG-6 SHIELDED) RECEPTACLES IN ALL BEDROOMS AND (1) IN LIVING ROOM. PROVIDÈ ALL TERMINATIONS AND COVER PLATES TO MATCH POWER RECEPTACLE COVER PLATES.
- LOCATIONS WHERE CONDUITS PENETRATE FIRE-RATED WALLS, FLOORS, OR CEILINGS SHALL BE FIREPROOFED USING A UL-LISTED METHOD TO MAINTAIN THE EXISTING RATING.
- COORDINATE THE MOUNTING HEIGHT AND LOCATIONS OF THE ELECTRICAL DEVICES WITH ARCHITECTURAL ELEVATIONS AND GENERAL TRADES CONTRACTOR PRIOR TO ROUGH-IN. RECEPTACLES LOCATED WITHIN SIX (6) FEET OF SINK SHALL BE GROUND FAULT CIRCUIT INTERRUPTER (GFCI) TYPE RECEPTACLES. RECEPTACLES NOT READILY ACCESSIBLE THAT REQUIRE GFCI PROTECTION SHALL BE SO AT THE CIRCUIT BREAKER.
- COORDINATE LOCATION OF CONDUITS, OUTLETS AND JUNCTION BOXES WITH MECHANICAL EQUIPMENT SO THAT OUTLETS AND JUNCTION BOXES ARE ACCESSIBLE FOR SERVICING AND HVAC DUCTWORK CAN BE CONNECTED DIRECTLY TO DIFFUSERS.
- PERFORM ALL WORK IN ACCORDANCE WITH 2020 NATIONAL ELECTRICAL CODE (NEC) (OR WHICHEVER IS LATEST FLORIDA-ADOPTED EDITION OF THE NEC) AND ALL APPLICABLE LOCAL CODES.
- FOR RECORD DRAWING REQUIREMENTS, REFER TO THE GENERAL CONDITIONS. MAINTAIN A DEDICATED SET OF DRAWINGS ON THE JOBSITE AND MARK ALL VARIATIONS TAKEN TO THE CONTRACT DRAWINGS. SEE PLANS
- ALL ELECTRICAL EQUIPMENT SHALL BE INSTALLED SUCH THAT PROPER WORKING CLEARANCES ARE
- COORDINATE WITH MECHANICAL TO PROVIDE APPROPRIATE CIRCUITS FOR HVAC AND PLUMBING EQUIPMENT. PROVIDE LOCAL DISCONNECT FOR EACH PIECE OF EQUIPMENT AND ENSURE WORKING CLEARANCE TO DISCONNECT IS MAINTAINED.
- ALL WORK SHALL MEET APPLICABLE REQUIREMENTS OF THE FLORIDA RESIDENTIAL CODE 2023 EDITION (OR MOST RECENT) AND CHAPTER 4 [RE] RESIDENTIAL ENERGY EFFICIENCY OF FBC, ENERGY CONSERVATION 2023
- ALL CONSTRUCTION WORK SHALL BE IN COMPLIANCE WITH ALL LOCAL CITY, COUNTY, STATE OF FLORIDA AND FEDERAL CODES. THE CONTRACTOR SHALL GIVE ALL NOTICES AND COMPLY WITH ALL LAWS, ORDINANCES, RULES, REGULATIONS, AND LAWFUL ORDERS OF ANY PUBLIC AUTHORITY BEARING PERFORMANCE OF THE
- COMBINATION SMOKE /CARBON MONOXIDE DETECTORS SHALL BE PROVIDED IN AND OUTSIDE ALL SLEEPING AREAS. SEE PLANS FOR SUGGESTED LOCATIONS.
- CONTRACTOR TO COORDINATE ALL UTILITIES INSTALLATION AND CONNECTION WITH LOCAL UTILITY COMPANY. AVOID ROUTING CONDUIT THROUGH BUILDING FOOTINGS. WHERE CONFLICTS ARE UNAVOIDABLE, ROUTE CONDUIT AT A MINIMUM OF 12" BELOW FOOTING.
- ALL PENETRATIONS THROUGH FIRE RATED WALLS ARE TO BE SEALED WITH CODE APPROVED FIRESTOPPING
- CONTRACTOR SHALL PROVIDE ALL ELECTRICAL FIXTURES, HARDWARE, AND ACCESSORIES IN A CONSISTENT MATERIAL FINISH.
- CONTRACTOR SHALL PROVIDE ELECTRICAL LOAD CALCULATIONS AND ANY ADDITIONAL ELECTRICAL INFORMATION REQUESTED BY PERMIT DEPARTMENT NOT SHOWN IN DRAWINGS.
- CONTRACTOR SHALL WIRE SERVICE CONDUCTORS THROUGH A JUNCTION BOX. THE INTENT IS THAT IF A FUTURE HOMEOWNER DESIRES TO INSTALL A BACKUP GENERATOR, THEY COULD REPLACE THE BOX WITH A SERVICE ENTRANCE AUTOMATIC TRANSFER SWITCH. PROVIDE CONTINUOUS SERVICE ENTRANCE CONDUCTORS THROUGH THE BOX WITH EXTRA LENGTH TO FACILITATE FUTURE CONNECTION. COORDINATE LOCATION BOX AND METER BASE WITH THE POWER COMPANY.

PER SECTION 471.003(2)(H), F.S., ALL MECHANICAL, ELECTRICAL, AND PLUMBING ARE EXEMPT FROM PROFESSIONAL ENGINEERING SERVICES FOR THIS PROJECT. IT IS THE RESPONSIBILITY OF THE CONTRACTOR TO PERMIT AND CONSTRUCT THE APPLICABLE SYSTEM IN ACCORDANCE WITH FLORIDA BUILDING CODE, LOCAL CODE REQUIREMENTS AND PROGRAMMATIC REQUIREMENTS. IT IS THE RESPONSIBILITY OF THE CONTRACTOR TO PERMIT THE PROJECT WITH ALL AUTHORITIES HAVING JURISDICTION (AHJ). INFORMATION SHOWN PROVIDES MINIMUM PROGRAMMATIC REQUIREMENTS AND ARE GENERAL IN NATURE. DRAWINGS ARE SCHEMATIC IN NATURE AND FINAL PERMITTING AND CONSTRUCTION OF THE SYSTEM IS THE RESPONSIBILITY OF THE CONTRACTOR. ALL EQUIPMENT AND PRODUCTS SHALL BE SELECTED BY THE CONTRACTOR.



Dewberry

850.267.0759 Phone

850.557.0076 Fax

www.dewberry.com

877 North County Hwy 393


Santa Rosa Beach, FL 32459



SEAL

SCALE

As indicated

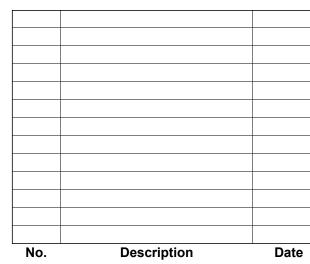

	Description
EVISIONS	
DRAWN BY	
APPROVED B	Υ

JHR/EHF

50171913

DATE

CHECKED BY

TITLE

ELECTRICAL PLAN 2 BR WIDE

PROJECT NO.

